Northeast Metropolitan Regional Vocational High School

100 Hemlock Road, Wakefield, MA 01880 DRA PROJECT NO. 20202



#### NORTHEAST METROPOLITAIN REGIONAL **VOCATIONAL H.S. BUILDING COMMITTEE**

Theodore Nickole, SBC Chair Anthony Caggiano Joseph Capraro Brittany A. Carisella Patricia Cronin Deborah P. Davis David DiBarri Judith M. Dyment Melissa Elam Ward Hamilton James J. Holland Stephen Maio Robert S. McCarthy Larry Means Robert O'Dwyer Joseph Papagni James Picone Peter A. Rossetti Carla Scuzzarella, Ed.D Brant Snyder Michael T. Wall

### MASSACHUSETTS SCHOOL BUILDING AUTHORITY

40 Broad Street, Suite 500 Boston, MA 02109

## NORTHEAST METROPOLITAIN REGIONAL VOCATIONAL SCHOOL DISTRICT

David DiBarri, Superintendent-Director

Dr. Carla A. Scuzzarella, Deputy Director-Principal

### **DISTRICT COMMUNITIES**


Chelsea, Malden, Melrose, North Reading, Reading, Revere, Saugus, Stoneham, Wakefield, Winchester, Winthrop & Woburn

### OWNERS PROJECT MANAGER

PMA Consultants 35 Braintree Hill Office Park, Suite 300 Braintree, MA 02184

## **CONSTRUCTION MANAGER AT RISK**

Gilbane Building Company 10 Channel Center Street, Suite 100 Boston, MA 02210

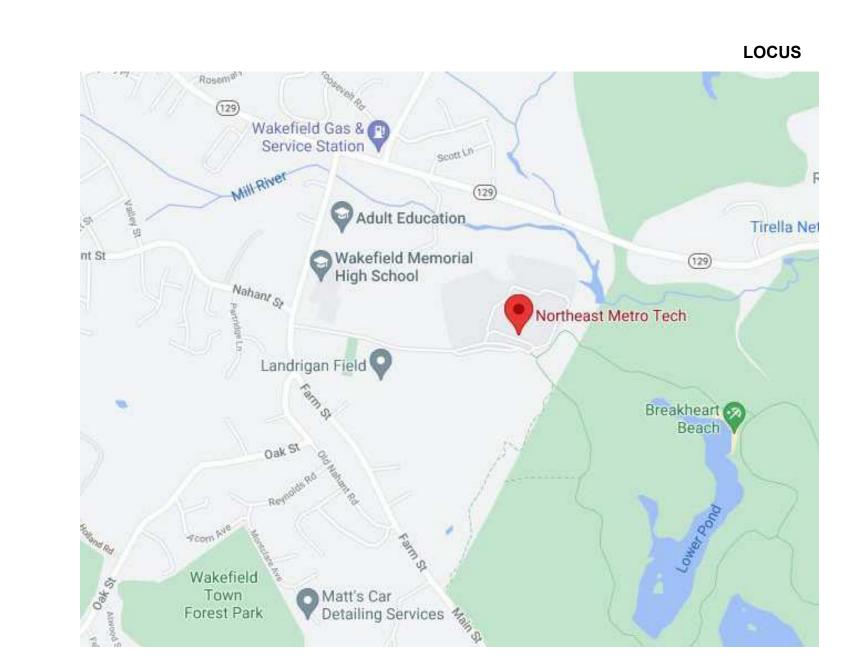

Issue Date: August 4th, 2022

### **ARCHITECT**

Drummey Rosane Anderson 260 Charles Street, Studio 300 Waltham, MA 02453 t: 617.964.1700

### LANDSCAPE ARCHITECT

Warner Larson Lanscape Architects Nitsch Engineering 130 West Broadway Boston, MA 02108 t: 617.464.1440

## **CIVIL ENGINEER**

2 Center Plaze, Suite 430 Boston, MA 02108 t: 617.338.0063

### STRUCTURAL ENGINEER

**Engineers Design Group** 350 Main St., Floor 2 Malden, MA. 02148 t: 781-396-9007

### **MEP-FP ENGINEER**

Bala Consulting Engineers 52 Temple Place Boston, MA 02111 t: 617-357-6060

### **EQUIPMENT CONSULTANT**

Point Line 75 Lowell Street Carlisle, MA 01741 t: (671) 314-7501

### **TECHNOLOGY CONSULTANT**

MSBA DESIGN DEVELOPMENT SUBMISSION

3Si, System Software Support, Inc. 168 Main Street Northfield, MA 01360 t: (413) 498-0069

### FOOD SERVICE CONSULTANT

Crabtree McGrath Associates 161 West Main Street Georgetown, MA 01833 t: (978) 352-8500



# LIST OF DRAWINGS

CIVIL NUMBER	DRAWING NAME	ARCHITE(	CTURAL  DRAWING NAME
C-000 C-100	CIVIL NOTES, LEGENDS AND ABBREVIATIONS KEY PLAN	A3-2-3	WALL SECTIONS
C-100 C-200 C-201	UTILITY DEMO PLAN UTILITY DEMO PLAN	A3-2-4 A3-2-5	WALL SECTIONS WALL SECTIONS
C-202 C-203	UTILITY DEMO PLAN UTILITY DEMO PLAN UTILITY DEMO PLAN	A3-2-6 A3-2-7	WALL SECTIONS WALL SECTIONS
C-204 C-205	UTILITY DEMO PLAN UTILITY DEMO PLAN	A3-2-8	WALL SECTIONS
C-300 C-301	SEDIMENTARY AND EROSION CONTROL PLAN SEDIMENTARY AND EROSION CONTROL PLAN	A3-2-9 A3-2-10	WALL SECTIONS WALL SECTIONS
C-302 C-303	SEDIMENTARY AND EROSION CONTROL PLAN SEDIMENTARY AND EROSION CONTROL PLAN	A3-2-11 A3-2-12	WALL SECTIONS WALL SECTIONS
C-304 C-305	SEDIMENTARY AND EROSION CONTROL PLAN SEDIMENTARY AND EROSION CONTROL PLAN	A3-2-13 A3-2-14	WALL SECTIONS WALL SECTIONS
C-400 C-401	UTILITY SITE PLAN UTILITY SITE PLAN	A3-3-1	VERTICAL DETAILS
C-402 C-403	UTILITY SITE PLAN UTILITY SITE PLAN	A4-1-1 A4-1-2	LOCKER ROOM PLANS TOILET AND LOCKER ROOM PLANS
C-404 C-405	UTILITY SITE PLAN UTILITY SITE PLAN	A4-1-3 A4-1-4	TOILET AND LOCKER ROOM PLANS TOILET AND LOCKER ROOM PLANS
C-406 C-500 C-501	DRAINAGE TABLE CIVIL SITE DETAILS CIVIL SITE DETAILS	A4-1-5	LOCKER ROOM AND TOILET ELEVATIONS
C-501 C-502 C-503	CIVIL SITE DETAILS  CIVIL SITE DETAILS  CIVIL SITE DETAILS	A4-1-6 A4-1-7	LOCKER ROOM AND TOILET ELEVATIONS  LOCKER ROOM AND TOILET ELEVATIONS
C-503 C-504	CIVIL SITE DETAILS CIVIL SITE DETAILS	A5-3-1 A6-2-1	ROOF DETAILS DOOR SCHEDULE
TRAFFIC NUMBER	DRAWING NAME	A6-2-2	DOOR SCHEDULE
TR-001	CONSTRUCTION PLAN	A6-2-3 A6-3-1	DOOR, FRAME & BORROWED LIGHT TYPES WINDOW AND TRANSLUCENT WALL PANEL TYPES
TR-002 TR-003	TRAFFIC SIGNAGE PLAN TRAFFIC SIGNAL DATA PLAN DAVEMENT MARKING AND SIGNAGE DI ANI	A6-3-2 A6-3-3	TRANSLUCENT WALL PANEL AND CURTAIN WALL TYPES CURTAIN WALL TYPES
TR-004 TR-005	PAVEMENT MARKING AND SIGNAGE PLAN SIGN SUMMARY TRAFFIC AND SIGNAL DETAILS	A6-3-4	CURTAIN WALL TYPES
TR-006 TR-007	TRAFFIC AND SIGNAL DETAILS TRAFFIC AND SIGNAL DETAILS	A6-3-5 A6-3-6	INTERIOR CURTAIN WALL TYPES STOREFRONT AND INTERIOR STOREFRONT TYPES
TR-008 TR-009	TRAFFIC AND SIGNAL DETAILS TRAFFIC AND SIGNAL DETAILS	A6-3-7 A7-1-1	INTERIOR STOREFRONT AND BORROWED LIGHT TYPES STAIR PLANS
TR-010 TR-011	TRAFFIC AND SIGNAL DETAILS TRAFFIC AND SIGNAL DETAILS	A7-1-2	STAIR SECTIONS
TR-012 TR-013 TR-014	TRAFFIC AND SIGNAL DETAILS TRAFFIC AND SIGNAL DETAILS TEMPORARY TRAFFIC CONTROL DETAILS	A7-1-3 A7-1-4	STAIR PLANS & SECTIONS STAIR PLANS
TR-014		A7-1-5 A7-1-6	STAIR SECTIONS STAIR PLANS & SECTIONS
NUMBER	DRAWING NAME	A7-1-7	STAIR PLANS & SECTIONS
L000 L101 L102	OVERALL SITE PLAN DEMO AND SITE PREPARATION PLAN - 1 DEMO AND SITE PREPARATION PLAN - 2	A7-1-8 A7-1-9	STAIR & RAMP PLANS & SECTIONS STAIR PLANS & SECTIONS
L102 L103 L104	DEMO AND SITE PREPARATION PLAN - 2 DEMO AND SITE PREPARATION PLAN - 3 DEMO AND SITE PREPARATION PLAN - 4	A7-1-10 A7-1-11	ELEVATOR PLANS & SECTIONS STAIR DETAILS - ELEVATOR DETAILS, SPECIALTY
L104 L105 L301	DEMO AND SITE PREPARATION PLAN - 4 DEMO AND SITE PREPARATION PLAN - 5 LAYOUT AND MATERIAL PLAN - 1		DETAILS
L301 L302 L303	LAYOUT AND MATERIAL PLAN - 1 LAYOUT AND MATERIAL PLAN - 2 LAYOUT AND MATERIAL PLAN - 3	A7-1-12 A8-1-0C	STAIR DETAILS LOWER LEVEL REFLECTED CEILING PLAN - AREA C
L303 L304 L305	LAYOUT AND MATERIAL PLAN - 3 LAYOUT AND MATERIAL PLAN - 4 LAYOUT AND MATERIAL PLAN - 5	A8-1-0D A8-1-0MC	LOWER LEVEL REFLECTED CEILING PLAN - AREA D LOWER LEVEL MEZZANINE REFLECTED CEILING PLAN -
L401 L402	GRADING PLAN - 1 GRADING PLAN - 2	A8-1-0MD	AREA C LOWER LEVEL MEZZANINE REFLECTED CEILING PLAN -
L403 L404	GRADING PLAN - 2 GRADING PLAN - 3 GRADING PLAN - 4		AREA D
L405 L501	GRADING PLAN - 5 PLANTING PLAN - 1	A8-1-1A A8-1-1B	FIRST FLOOR REFLECTED CEILING PLAN - AREA A FIRST FLOOR REFLECTED CEILING PLAN - AREA B
L502 L503	PLANTING PLAN - 2 PLANTING PLAN - 3	A8-1-1C A8-1-1D	FIRST FLOOR REFLECTED CEILING PLAN - AREA C FIRST FLOOR REFLECTED CEILING PLAN - AREA D
L504 L505	PLANTING PLAN - 4 PLANTING PLAN - 5	A8-1-1MA	FIRST FLOOR MEZZANINE REFLECTED CEILING PLAN - AREA A
L601 L602	LANDSCAPE DETAILS - 1 LANDSCAPE DETAILS - 2	A8-1-1MB	FIRST FLOOR MEZZANINE REFLECTED CEILING PLAN -
L603 L604	LANDSCAPE DETAILS - 3 LANDSCAPE DETAILS - 4	A8-1-2A	AREA B SECOND FLOOR REFLECTED CEILING PLAN - AREA A
L605 L606	LANDSCAPE DETAILS - 5 LANDSCAPE DETAILS - 6	A8-1-2B A8-1-2C	SECOND FLOOR REFLECTED CEILING PLAN - AREA B SECOND FLOOR REFLECTED CEILING PLAN - AREA C
ARCHITE	CTURAI	A8-1-2D	SECOND FLOOR REFLECTED CEILING PLAN - AREA D
NUMBER	DRAWING NAME	A8-1-3A A8-1-3B	THIRD FLOOR REFLECTED CEILING PLAN - AREA A THIRD FLOOR REFLECTED CEILING PLAN - AREA B
A0-1-1 A0-1-2	COVER SHEET DRAWING LIST	A8-1-3C A8-1-3D	THIRD FLOOR REFLECTED CEILING PLAN - AREA C THIRD FLOOR REFLECTED CEILING PLAN - AREA D
A1-0-0 A1-0-1	PARTITION TYPES OVERALL LOWER LEVEL & FIRST FLOOR PLANS	A8-1-4A	FOURTH FLOOR REFLECTED CEILING PLAN - AREA A
A1-0-2	OVERALL SECOND FLOOR PLAN	A8-1-4B A8-1-4C	FOURTH FLOOR REFLECTED CEILING PLAN - AREA B FOURTH FLOOR REFLECTED CEILING PLAN - AREA C
A1-0-3 A1-0-4	OVERALL THIRD FLOOR PLAN OVERALL FOURTH FLOOR PLAN	A8-1-4D A9-1-1	FOURTH FLOOR REFLECTED CEILING PLAN - AREA D MISCELLANEOUS DETAILS
A1-0-5 A1-0-6	OVERALL ROOF PLAN EXTERIOR RENDERINGS	A9-1-2	MISCELLANEOUS DETAILS
A1-0-8	LOWER & FIRST FLOOR NET AREA PLANS	AC-1-1	TOILET AND CONCESSION BUILDING PLANS & ELEVATIONS
A1-0-9 A1-0-10	SECOND & THIRD FLOOR NET AREA PLANS FOURTH FLOOR & SATELLITE LOCKERS NET AREA	AC-1-2 AC-1-3	WALL SECTIONS, PLAN & SCHEDULES ENLARGED DETAILS
A1-1-0C	PLANS LOWER LEVEL FLOOR PLAN - AREA C	AL-1-1 AM-1-1	LOCKER BUILDING DRAWINGS MAINTENANCE BUILIDNG DRAWINGS
A1-1-0D	LOWER LEVEL FLOOR PLAN - AREA D	AF1-1-0C	LOWER LEVEL FLOOR FINISHES PLAN- AREA C
A1-1-0MC A1-1-0MD	LOWER LEVEL MEZZANINE PLAN - AREA C LOWER LEVEL MEZZANINE PLAN - AREA D	AF1-1-0D AF1-1-1A	LOWER LEVEL FLOOR FINISHES PLAN - AREA D FIRST LEVEL FLOOR FINISHES PLAN - AREA A
A1-1-1A A1-1-1B	FIRST FLOOR PLAN - AREA A FIRST FLOOR PLAN - AREA B	AF1-1-1B	FIRST LEVEL FLOOR FINISHES PLAN - AREA B FIRST LEVEL FLOOR FINISHES PLAN - AREA C
A1-1-1C	FIRST FLOOR PLAN - AREA C	AF1-1-1C AF1-1-1D	FIRST LEVEL FLOOR FINISHES PLAN - AREA D
A1-1-1D A1-1-1MA	FIRST FLOOR PLAN - AREA D FIRST FLOOR MEZZANINE PLAN - AREA A	AF1-1-2A AF1-1-2B	SECOND LEVEL FLOOR FINISHES PLAN - AREA A SECOND LEVEL FLOOR FINISHES PLAN - AREA B
A1-1-1MB A1-1-2A	FIRST FLOOR MEZZANINE PLAN - AREA B SECOND FLOOR PLAN - AREA A	AF1-1-2C	SECOND LEVEL FLOOR FINISHES PLAN - AREA C
A1-1-2B	SECOND FLOOR PLAN - AREA B	AF1-1-2D AF1-1-3A	SECOND LEVEL FLOOR FINISHES PLAN - AREA D THIRD LEVEL FLOOR FINISHES PLAN - AREA A
A1-1-2C A1-1-2D	SECOND FLOOR PLAN - AREA C SECOND FLOOR PLAN - AREA D	AF1-1-3B AF1-1-3C	THIRD LEVEL FLOOR FINISHES PLAN - AREA B THIRD LEVEL FLOOR FINISHES PLAN - AREA C
A1-1-3A A1-1-3B	THIRD FLOOR PLAN - AREA A THIRD FLOOR PLAN - AREA B	AF1-1-3D	THIRD LEVEL FLOOR FINISHES PLAN - AREA D
A1-1-3C	THIRD FLOOR PLAN - AREA C	AF1-1-4A AF1-1-4B	FOURTH LEVEL FLOOR FINISHES PLAN - AREA A FOURTH LEVEL FLOOR FINISHES PLAN - AREA B
A1-1-3D A1-1-4A	THIRD FLOOR PLAN - AREA D FOURTH FLOOR PLAN - AREA A	AF1-1-4C AF1-1-4D	FOURTH LEVEL FLOOR FINISHES PLAN - AREA C FOURTH LEVEL FLOOR FINISHES PLAN - AREA D
A1-1-4B A1-1-4C	FOURTH FLOOR PLAN - AREA B FOURTH FLOOR PLAN - AREA C	AF1-2-0C	LOWER LEVEL WALL FINISHES PLAN - AREA C
A1-1-4D	FOURTH FLOOR PLAN - AREA D	AF1-2-0D AF1-2-1A	LOWER LEVEL WALL FINISHES PLAN - AREA D FIRST LEVEL WALL FINISHES PLAN - AREA A
A1-2-1A A1-2-1B	ROOF PLAN - AREA A ROOF PLAN - AREA B	AF1-2-1B AF1-2-1C	FIRST LEVEL WALL FINISHES PLAN - AREA B FIRST LEVEL WALL FINISHES PLAN - AREA C
A1-2-1C A1-2-1D	ROOF PLAN - AREA C ROOF PLAN - AREA D	AF1-2-1D	FIRST LEVEL WALL FINISHES PLAN - AREA D
A2-0-1	OVERALL BUILDING ELEVATIONS	AF1-2-2A AF1-2-2B	SECOND LEVEL WALL FINISHES PLAN - AREA A SECOND LEVEL WALL FINISHES PLAN - AREA B
A2-1-1 A2-1-2	BUILDING ELEVATIONS BUILDING ELEVATIONS	AF1-2-2C AF1-2-2D	SECOND LEVEL WALL FINISHES PLAN - AREA C SECOND LEVEL WALL FINISHES PLAN - AREA D
A2-1-3 A2-1-4	BUILDING ELEVATIONS BUILDING ELEVATIONS	AF1-2-3A	THIRD LEVEL WALL FINISHES PLAN - AREA A
A2-1-5	BUILDING ELEVATIONS	AF1-2-3B AF1-2-3C	THIRD LEVEL WALL FINISHES PLAN - AREA B THIRD LEVEL WALL FINISHES PLAN- AREA C
A2-1-6 A2-1-7	BUILDING ELEVATIONS BUILDING ELEVATIONS	AF1-2-3D AF1-2-4A	THIRD LEVEL WALL FINISHES PLAN - AREA D FOURTH LEVEL WALL FINISHES PLAN - AREA A
A2-1-8	BUILDING ELEVATIONS	AF1-2-4B	FOURTH LEVEL WALL FINISHES PLAN - AREA B
A2-2-1 A2-2-2	INTERIOR ELEVATIONS INTERIOR ELEVATIONS	AF1-2-4C AF1-2-4D	FOURTH LEVEL WALL FINISHES PLAN - AREA C FOURTH LEVEL WALL FINISHES PLAN - AREA D
A2-2-3	INTERIOR ELEVATIONS INTERIOR ELEVATIONS	AF1-3-1	TRANSITION DETAILS
A2-2-4	INTERIOR ELEVATIONS	AF1-3-2 AF1-3-3	TRANSITION DETAILS TRANSITION DETAILS
A2-2-5	INTELLICATION AND CONTROL CONTROL	AF1-4-1	BASE DETAILS
A2-2-4 A2-2-5 A2-2-6 A2-2-7	INTERIOR ELEVATIONS INTERIOR ELEVATIONS	AF1-4-2	BASE DETAILS
A2-2-5 A2-2-6 A2-2-7 A2-2-8	INTERIOR ELEVATIONS INTERIOR ELEVATIONS	AF1-4-2 AF1-4-3	BASE DETAILS
A2-2-5 A2-2-6 A2-2-7 A2-2-8 A2-2-9 A2-2-10	INTERIOR ELEVATIONS INTERIOR ELEVATIONS INTERIOR ELEVATIONS INTERIOR ELEVATIONS	AF1-4-2	
A2-2-5 A2-2-6 A2-2-7 A2-2-8 A2-2-9	INTERIOR ELEVATIONS INTERIOR ELEVATIONS INTERIOR ELEVATIONS	AF1-4-2 AF1-4-3 AF1-5-1 AF1-6-1 AF1-7-1	BASE DETAILS DECORATIVE FABRIC METAL DETAILS PHENOLIC RESIN PANEL DETAILS INTERIOR WALL PANEL DETAILS
A2-2-5 A2-2-6 A2-2-7 A2-2-8 A2-2-9 A2-2-10 A2-2-11 A2-2-12 A2-2-13	INTERIOR ELEVATIONS	AF1-4-2 AF1-4-3 AF1-5-1 AF1-6-1	BASE DETAILS DECORATIVE FABRIC METAL DETAILS PHENOLIC RESIN PANEL DETAILS
A2-2-5 A2-2-6 A2-2-7 A2-2-8 A2-2-9 A2-2-10 A2-2-11 A2-2-12	INTERIOR ELEVATIONS INTERIOR ELEVATIONS INTERIOR ELEVATIONS INTERIOR ELEVATIONS INTERIOR ELEVATIONS INTERIOR ELEVATIONS	AF1-4-2 AF1-4-3 AF1-5-1 AF1-6-1 AF1-7-1	BASE DETAILS DECORATIVE FABRIC METAL DETAILS PHENOLIC RESIN PANEL DETAILS INTERIOR WALL PANEL DETAILS

**BUILDING SECTIONS** 

BUILDING SECTIONS

BUILDING SECTIONS

**BUILDING SECTIONS** 

WALL SECTIONS

WALL SECTIONS

A3-1-4

A3-2-2

```
NUMBER DRAWING NAME
         NOTES, SCHEDULES, AND ABBREVIATIONS
         CASEWORK ELEVATIONS
         CASEWORK ELEVATIONS
         CASEWORK ELEVATIONS
         CASEWORK ELEVATIONS
EQ1-1-0C FF&E/CASEWORK LOWER LEVEL AREA C
         FF&E/CASEWORK LOWER LEVEL AREA D
EQ1.1-1A FF&E/CASEWORK FIRST FLOOR AREA A
EQ1.1-1B FF&E/CASEWORK FIRST FLOOR AREA B
EQ1.1-1C FF&E/CASEWORK FIRST FLOOR AREA C
EQ1.1-1D FF&E/CASEWORK FIRST FLOOR AREA D
          FF&E/CASEWORK SECOND FLOOR AREA A
         FF&E/CASEWORK SECOND FLOOR AREA B
          FF&E/CASEWORK SECOND FLOOR AREA C
          FF&E/CASEWORK SECOND FLOOR AREA D
          FF&E/CASEWORK THIRD FLOOR AREA A
EQ1.1-3B FF&E/CASEWORK THIRD FLOOR AREA B
          FF&E/CASEWORK FOURTH FLOOR AREA A
EQ1.1-4B FF&E/CASEWORK FOURTH FLOOR AREA B
          METAL FABRICATION CASEWORK AND EQUIPMENT
EQ2.2
          AUTO COLLISION CASEWORK AND EQUIPMENT
          AUTO TECHNOLOGY CASEWORK AND EQUIPMENT
          HVAC TECH CASEWORK AND EQUIPMENT
EQ2.4
EQ2.5
          CARPENTRY CASEWORK AND EQUIPMENT
          PLUMBING / PIPEFITTING CASEWORK AND EQUIPMENT
          ELECTRICAL TECHNOLOGY CASEWORK AND EQUIPMENT
EQ2.8
          DENTAL ASSISTING CASEWORK AND EQUIPMENT
EQ2.9
          ROBOTICS CASEWORK AND EQUIPMENT
EQ2.10
          DESIGN/VISUAL COM CASEWORK AND EQUIPMENT
          DRAFTING/DESIGN CASEWORK AND EQUIPMENT
          COSMOTOLOGY CASEWORK AND EQUIPMENT
          COSMOTOLOGY CASEWORK AND EQUIPMENT
          MEDICAL ASSIST CASEWORK AND EQUIPMENT
          HEALTH ASSIST CASEWORK AND EQUIPMENT
EQ2.15
          BIOTECH CASEWORK & EQUIPMENT
          BIOTECH CASEWORK & ELEVATIONS
Theatre Equipment
        DRAWING NAME
          THEATRE ELECTRICS POWER RISER
         THEATRE ELECTRICS DATA RISER
          THEATRE ELECTRICS PLACEMENT
          THEATRE RIGGING PLAN, SECTION AND SCHEDULE
         THEATRE RIGGING TRAVELER CURTAINS
FOOD SERVICE
NUMBER DRAWING NAME
FS1-1-1A FOODSERVICE EQUIPMENT OVERALL PLAN
        MAIN KITCHEN FOODSERVIC E EQUIPMENT SCHEDULE
         MAIN KITCHEN FOODSERVICE EQUIPMENT PLAN
        CULINARY KITCHEN FOODSERVICE EQUIPMENT SCHEDULE
         CULINARY KITCHEN FOODSERVICE EQUIPMENT PLAN
NUMBER DRAWING NAME
          GENERAL NOTES
         TYPICAL DETAILS
          TYPICAL DETAILS
          TYPICAL DETAILS
          TYPICAL DETAILS
          TYPICAL DETAILS
         TYPICAL DETAILS
         TYPICAL DETAILS
         LOWER LEVEL FOUNDATION PLAN – AREA C
         LOWER LEVEL FOUNDATION PLAN – AREA D
S1-1-0MC MEZZANINE FLOOR FRAMING PLAN – AREA C
S1-1-0MD MEZZANINE FLOOR FRAMING PLAN – AREA [
S1-1-1A FIRST FLOOR FOUNDATION PLAN – AREA A
        FIRST FLOOR FOUNDATION PLAN – AREA B
        FIRST FLOOR FOUNDATION PLAN – AREA C
S1-1-1D FIRST FLOOR FOUNDATION PLAN – AREA D
S1-1-1MA MEZZANINE FLOOR FRAMING PLAN – AREA A
S1-1-1MB MEZZANINE FLOOR FRAMING PLAN – AREA B
        SECOND FLOOR FRAMING PLAN – AREA A
         SECOND FLOOR FRAMING PLAN – AREA B
        SECOND FLOOR FRAMING PLAN – AREA C
         SECOND FLOOR FRAMING PLAN – AREA D
          THIRD FLOOR FRAMING PLAN – AREA A
        THIRD FLOOR FRAMING PLAN – AREA B
        THIRD FLOOR FRAMING PLAN – AREA C
S1-1-3D
         THIRD FLOOR FRAMING PLAN – AREA D
         FOURTH FLOOR FRAMING PLAN – AREA A
          FOURTH FLOOR FRAMING PLAN – AREA B
         FOURTH FLOOR FRAMING PLAN – AREA C
         FOURTH FLOOR FRAMING PLAN – AREA D
         ROOF FRAMING PLAN – AREA A
         ROOF FRAMING PLAN – AREA B
```

BRACE FRAME ELEVATIONS – AREA A BRACE FRAME ELEVATIONS – AREA A + B BRACE FRAME ELEVATIONS – AREA B BRACE FRAME ELEVATIONS – AREA C + D SHEAR WALLS SHEAR WALLS SHEAR WALLS TRUSS ELEVATIONS JOIST LOADING DIAGRAMS CONCESSION BUILDING PLANS LOCKER BUILDING PLANS MAINTENANCE BUILDING PLANS GEOTECHNICAL NUMBER DRAWING NAME GEOTECHNICAL PLAN EAST GEOTECHNICAL PLAN WEST

ROOF FRAMING PLAN – AREA C

ROOF FRAMING PLAN – AREA D

**PLUMBING** NUMBER DRAWING NAME PLUMBING LEGENDS, ABBREVIATIONS, AND GENERAL NOTES PLUMBING FIRST FLOOR PLAN - AREA A BELOW SLAB PLUMBING FIRST FLOOR PLAN - AREA B BELOW SLAB PLUMBING LOWER LEVEL FLOOR PLAN - AREA C BELOW SLAB PLUMBING LOWER LEVEL FLOOR PLAN - AREA D BELOW SLAB PLUMBING LOWER LEVEL FLOOR PLAN - AREA C PLUMBING LOWER LEVEL FLOOR PLAN - AREA D PLUMBING FIRST FLOOR PLAN - AREA A PLUMBING FIRST FLOOR PLAN - AREA B PLUMBING FIRST FLOOR PLAN - AREA C PLUMBING FIRST FLOOR PLAN - AREA D PLUMBING SECOND FLOOR PLAN - AREA A PLUMBING SECOND FLOOR PLAN - AREA B PLUMBING SECOND FLOOR PLAN - AREA C PLUMBING SECOND FLOOR PLAN - AREA D PLUMBING THIRD FLOOR PLAN - AREA A PLUMBING THIRD FLOOR PLAN - AREA B

PLUMBING THIRD FLOOR PLAN - AREA C PLUMBING THIRD FLOOR PLAN - AREA D PLUMBING FOURTH FLOOR PLAN - AREA A PLUMBING FOURTH FLOOR PLAN - AREA B PLUMBING FOURTH FLOOR PLAN - AREA C PLUMBING FOURTH FLOOR PLAN - AREA D PLUMBING ROOF PLAN - AREA A P1-2-1B PLUMBING ROOF PLAN - AREA B PLUMBING ROOF PLAN - AREA C PLUMBING ROOF PLAN - AREA D PLUMBING DETAILS SHEET PLUMBING SCHEDULES SHEET PLUMBING - CONCESSIONS FLOOR LEVEL PLAN PLUMBING LOCKER BUILDING PLAN PLUMBING MAINTENANCE BUILDING PLAN

**FIRE PROTECTION** NUMBER DRAWING NAME FIRE PROTECTION COVER SHEET FP1-1-0C FIRE PROTECTION LOWER LEVEL FLOOR PLAN - AREA C FP1-1-0D FIRE PROTECTION LOWER LEVEL FLOOR PLAN - AREA D FP1-1-MC FIRE PROTECTION LOWER LEVEL MEZZANINE PLAN – AREA C FP1-1-1A FIRE PROTECTION FIRST FLOOR PLAN - AREA A FP1-1-1B FIRE PROTECTION FIRST FLOOR PLAN - AREA B FP1-1-1C FIRE PROTECTION FIRST FLOOR PLAN - AREA C FIRE PROTECTION FIRST FLOOR PLAN - AREA D FP1-1-2A FIRE PROTECTION SECOND FLOOR PLAN - AREA A FP1-1-2B FIRE PROTECTION SECOND FLOOR PLAN - AREA B FP1-1-2C FIRE PROTECTION SECOND FLOOR PLAN - AREA C FP1-1-2D FIRE PROTECTION SECOND FLOOR PLAN - AREA D FP1-1-3A FIRE PROTECTION THIRD FLOOR PLAN - AREA A FP1-1-3B FIRE PROTECTION THIRD FLOOR PLAN - AREA B FP1-1-3C FIRE PROTECTION THIRD FLOOR PLAN - AREA C FP1-1-3D FIRE PROTECTION THIRD FLOOR PLAN - AREA D FIRE PROTECTION FOURTH FLOOR PLAN - AREA A FP1-1-4B FIRE PROTECTION FOURTH FLOOR PLAN - AREA B FP1-1-4C FIRE PROTECTION FOURTH FLOOR PLAN - AREA C FP1-1-4D FIRE PROTECTION FOURTH FLOOR PLAN - AREA D FP1-1-MC FIRE PROTECTION LOWER LEVEL MEZZANINE PLAN – AREA C FP1-2-1-A FIRE PROTECTION ROOF PLAN - AREA A FP1-2-1-B FIRE PROTECTION ROOF PLAN - AREA B FP1-2-1-C FIRE PROTECTION ROOF PLAN - AREA C FP1-2-1-D FIRE PROTECTION ROOF PLAN - AREA D FIRE PROTECTION RISER DIAGARAM FIRE PROTECTION DETAILS **MECHANICAL** DRAWING NAME MECHANICAL LEGENDS AND ABBREVIATIONS MECHANICAL GENERAL NOTES MECHANICAL ZONING PLAN MECHANICAL ZONING PLAN MECHANICAL LOWER LEVEL FLOOR PLAN - AREA C MECHANICAL LOWER LEVEL FLOOR PLAN - AREA D MECHANICAL FIRST FLOOR PLAN - AREA A MECHANICAL FIRST FLOOR PLAN - AREA B MECHANICAL FIRST FLOOR PLAN - AREA C MECHANICAL FIRST FLOOR PLAN - AREA D MECHANICAL SECOND FLOOR PLAN - AREA A MECHANICAL SECOND FLOOR PLAN - AREA B MECHANICAL SECOND FLOOR PLAN - AREA C MECHANICAL SECOND FLOOR PLAN - AREA D MECHANICAL THIRD FLOOR PLAN - AREA A M1-1-3B MECHANICAL THIRD FLOOR PLAN - AREA B MECHANICAL THIRD FLOOR PLAN - AREA C MECHANICAL THIRD FLOOR PLAN - AREA D MECHANICAL FOURTH FLOOR PLAN - AREA A MECHANICAL FOURTH FLOOR PLAN - AREA B MECHANICAL CONCESSION BUILDING PLAN MECHANICAL LOCKER BUILDING PLAN MECHANICAL MAINTENANCE BUILDING PLAN MECHANICAL ROOF PLAN - AREA A MECHANICAL ROOF PLAN - AREA B MECHANICAL ROOF PLAN - AREA C MECHANICAL ROOF PLAN - AREA D MECHANICAL VRF SYSTEM DIAGRAMS SHEET #1 MECHANICAL VRF SYSTEM DIAGRAMS SHEET #2 MECHANICAL VRF SYSTEM DIAGRAMS SHEET #3 MECHANICAL AIR RISER DIAGRAMS MECHANICAL DETAILS SHEET #1 MECHANICAL DETAILS SHEET #2 MECHANICAL SCHEDULES SHEET #1 MECHANICAL SCHEDULES SHEET #2 NUMBER DRAWING NAME LT1-1-1 LIGHTING OVERALL FIRST FLOOR PLAN LT1-1-1A LIGHTING FIRST FLOOR PLAN - AREA A LT1-1-1C LIGHTING FIRST FLOOR PLAN - AREA C LT1-1-1D LIGHTING FIRST FLOOR PLAN - AREA D LT1-1-2 LIGHTING OVERALL SECOND FLOOR PLAN LT1-1-2A LIGHTING SECOND FLOOR PLAN - AREA A LT1-1-3 LIGHTING OVERALL THIRD FLOOR PLAN LT1-1-3A LIGHTING THIRD FLOOR PLAN - AREA A LT1-1-3B LIGHTING THIRD FLOOR PLAN - AREA B LIGHTING OVERALL FOURTH FLOOR PLAN LT1-1-4A LIGHTING FOURTH FLOOR PLAN - AREA A LT1-1-4B LIGHTING FOURTH FLOOR PLAN - AREA B LIGHTING OVERALL LOWER LEVEL REFLECTED CEILING PLAN LIGHTING LOWER LEVEL REFLECTED CEILING PLAN - AREA C LT1-2-0D LIGHTING LOWER LEVEL REFLECTED CEILING PLAN - AREA D LIGHTING OVERALL FIRST REFLECTED CEILING PLAN PLAN LT-1-2-1.5 LIGHTING OVERALL FIRST FLOOR MEZZANINE REFLECTED CEILING PLAN LT1-2-1A LIGHTING FIRST FLOOR REFLECTED CEILING PLAN - AREA A LT1-2-1B LIGHTING FIRST FLOOR REFLECTED CEILING PLAN - AREA B LT1-2-1C LIGHTING FIRST FLOOR REFLECTED CEILING PLAN - AREA C LT1-2-1D LIGHTING FIRST FLOOR REFLECTED CEILING PLAN - AREA D LT1-2-2 LIGHTING OVERALL SECOND REFLECTED CEILING PLAN LT1-2-2A LIGHTING SECOND FLOOR REFLECTED CEILING PLAN - AREA A LT1-2-2B LIGHTING SECOND FLOOR REFLECTED CEILING PLAN - AREA B LIGHTING SECOND FLOOR REFLECTED CEILING PLAN - AREA C LT1-2-2D LIGHTING SECOND FLOOR REFLECTED CEILING PLAN - AREA D LT1-2-3 LIGHTING OVERALL THIRD FLOOR REFLECTED CEILING PLAN LIGHTING THIRD FLOOR REFLECTED CEILING PLAN - AREA A LT1-2-3B LIGHTING THIRD FLOOR REFLECTED CEILING PLAN - AREA B LT1-2-3C LIGHTING THIRD FLOOR REFLECTED CEILING PLAN - AREA C LIGHTING THIRD FLOOR REFLECTED CEILING PLAN - AREA D

LIGHTING OVERALL FOURTH REFLECTED CEILING PLAN LT1-2-4A LIGHTING FOURTH REFLECTED CEILING PLAN - AREA A LT1-2-4B LIGHTING FOURTH REFLECTED CEILING PLAN - AREA B LT1-2-4C LIGHTING FOURTH REFLECTED CEILING PLAN - AREA C LT1-2-4D LIGHTING FOURTH REFLECTED CEILING PLAN - AREA D LT3-1-1-0 TYPICAL AUTO SHOP LT3-1-2-1 TYPICAL SHOP AND SHOP CLASSROOM LT3-1-3-2 TYPICAL CLASSROOM AND CLASSROOM STORAGE LT3-1-4-2 TYPICAL TEACHER PLANNING LT3-1-5-2 TYPICAL COMPUTER LAB LT3-1-6-2 TYPICAL OFFICE LT3-1-7-2 TYPICAL SCIENCE LAB LT3-1-8-2 TYPICAL RESTROOMS LT3-1-9-2 TYPICAL TOILETS AND STAIR LT3-1-10-2 TYPICAL SMALL GROUP LT3-1-11-2 TYPICAL CORRIDOR LT3-1-12-2 TYPICAL COLLAB AREA LT3-1-13-2 TYPICAL STUDIO LT7-1-1 CONTROL MATRIX LT8-1-1 FIXTURE SCHEDULE LT8-1-2 FIXTURE SCHEDULE

FIRE ALARM NUMBER DRAWING NAME FIRE ALARM LEGENDS, ABBREVIATIONS, AND GENERAL NOTES FA1-1-0C FIRE ALARM LOWER LEVEL FLOOR PLAN - AREA C FA1-1-0D FIRE ALARM LOWER LEVEL FLOOR PLAN - AREA D FA1-1-1A FIRE ALARM FIRST FLOOR PLAN - AREA A FA1-1-1B FIRE ALARM FIRST FLOOR PLAN - AREA B FA1-1-1C FIREALARM FIRST FLOOR PLAN - AREA C FA1-1-1D FIRE ALARM FIRST FLOOR PLAN - AREA D FA1-1-1MA FIRE ALARM FIRST FLOOR MEZZANINE PLAN - AREA A FA1-1-2A FIRE ALARM SECOND FLOOR PLAN - AREA A FA1-1-2B FIRE ALARM SECOND FLOOR PLAN - AREA B FA1-1-2C FIRE ALARM SECOND FLOOR PLAN - AREA C FA1-1-2D FIRE ALARM SECOND FLOOR PLAN - AREA D FA1-1-3A FIRE ALARM THIRD FLOOR PLAN - AREA A FA1-1-3B FIRE ALARM THIRD FLOOR PLAN - AREA B FA1-1-3C FIRE ALARM THIRD FLOOR PLAN - AREA C FA1-1-3D FIRE ALARM THIRD FLOOR PLAN - AREA D FA1-1-4A FIRE ALARM FOURTH FLOOR PLAN - AREA A FA1-1-4B FIRE ALARM FOURTH FLOOR PLAN - AREA B FA1-1-4C FIRE ALARM FOURTH FLOOR PLAN - AREA C FA1-1-4D FIRE ALARM FOURTH FLOOR PLAN - AREA D FA1-1-CB FIRE ALARM CONCESSION BUILDING PLAN FA1-1-LB FIRE ALARM LOCKER BUILDING PLAN FA1-1-MB FIRE ALARM MAINTENANANCE BUILDING PLAN FA1-1-MC FIRE ALARM LOWER LEVEL MEZZANINE PLAN - AREA C

FIRE ALARM HIGH SCHOOL BUILDING RISER DIAGRAM

FA1-2-1A FIRE ALARM ROOF PLAN - AREA A

FA1-2-1B FIRE ALARM ROOF PLAN - AREA B

FA1-2-1C FIRE ALARM ROOF PLAN - AREA C

FA1-2-1D FIRE ALARM ROOF PLAN - AREA D

FIRE ALARM RISER DIAGRAMS

NUMBER DRAWING NAME ELECTRICAL TITLE SHEET (NOTES & DWG LIST) ELECTRICAL LEGENDS AND ABBREVIATIONS ELECTRICAL SCOPE OF WORK ELECTRICAL SITE PLAN ELECTRICAL SITE PLAN ELECTRICAL SITE PLAN SITE DETAILS SITE DETAILS TYPICAL EVSE DETAILS TYPICAL SPORTS LIGHTING DETAILS ELECTRICAL LOWER FLOOR PLAN - OVERALL PLAN ELECTRICAL POWER LOWER LEVEL FLOOR PLAN - AREA C ELECTRICAL POWER LOWER LEVEL FLOOR PLAN - AREA D ELECTRICAL POWER LOWER LEVEL MEZZANINE PLAN - AREA C ELECTRICAL POWER LOWER LEVEL MEZZANINE PLAN - AREA D ELECTRICAL FIRST FLOOR PLAN - OVERALL PLAN ELECTRICAL POWER FIRST FLOOR PLAN - AREA A ELECTRICAL POWER FIRST FLOOR PLAN - AREA B ELECTRICAL POWER FIRST FLOOR PLAN - AREA C ELECTRICAL POWER FIRST FLOOR PLAN - AREA D ELECTRICAL POWER FIRST FLOOR MEZZANINE PLAN - AREA A E1-1-1MB ELECTRICAL POWER FIRST FLOOR MEZZANINE PLAN - AREA B ELECTRICAL SECOND FLOOR PLAN - OVERALL PLAN ELECTRICAL POWER SECOND FLOOR PLAN - AREA A ELECTRICAL POWER SECOND FLOOR PLAN - AREA B ELECTRICAL POWER SECOND FLOOR PLAN - AREA C ELECTRICAL POWER SECOND FLOOR PLAN - AREA D ELECTRICAL THIRD FLOOR PLAN - OVERALL PLAN ELECTRICAL POWER THIRD FLOOR PLAN - AREA A ELECTRICAL POWER THIRD FLOOR PLAN - AREA B ELECTRICAL POWER THIRD FLOOR PLAN - AREA C ELECTRICAL POWER THIRD FLOOR PLAN - AREA D ELECTRICAL FOURTH FLOOR PLAN - OVERALL PLAN ELECTRICAL POWER FOURTH FLOOR PLAN - AREA A ELECTRICAL POWER FOURTH FLOOR PLAN - AREA B ELECTRICAL POWER FOURTH FLOOR PLAN - AREA C ELECTRICAL POWER FOURTH FLOOR PLAN - AREA D ELECTRICAL POWER ROOF PLAN - OVERALL PLAN ELECTRICAL POWER ROOF PLAN - AREA A ELECTRICAL POWER ROOF PLAN - AREA B ELECTRICAL POWER ROOF PLAN - AREA C ELECTRICAL POWER ROOF PLAN - AREA D ELECTRICAL POWER CONCESSION BUILDING PLAN ELECTRICAL POWER LOCKER BUILDING PLAN ELECTRICAL POWER MAINTENANCE BUILDING PLAN ELECTRICAL ROOMS POWER PART PLANS ELECTRICAL LIGHTING LOWER LEVEL FLOOR PLAN - AREA C ELECTRICAL LIGHTING LOWER LEVEL FLOOR PLAN - AREA D ELECTRICAL LIGHTING FIRST FLOOR PLAN - AREA A ELECTRICAL LIGHTING FIRST FLOOR PLAN - AREA I ELECTRICAL LIGHTING FIRST FLOOR PLAN - AREA ( ELECTRICAL LIGHTING FIRST FLOOR PLAN - AREA D ELECTRICAL LIGHTING SECOND FLOOR PLAN - AREA A ELECTRICAL LIGHTING SECOND FLOOR PLAN - AREA B ELECTRICAL LIGHTING SECOND FLOOR PLAN - AREA C ELECTRICAL LIGHTING SECOND FLOOR PLAN - AREA D ELECTRICAL LIGHTING THIRD FLOOR PLAN - AREA A ELECTRICAL LIGHTING THIRD FLOOR PLAN - AREA B ELECTRICAL LIGHTING THIRD FLOOR PLAN - AREA O ELECTRICAL LIGHTING THIRD FLOOR PLAN - AREA D ELECTRICAL LIGHTING FOURTH FLOOR PLAN - AREA A ELECTRICAL LIGHTING FOURTH FLOOR PLAN - AREA B ELECTRICAL LIGHTING FOURTH FLOOR PLAN - AREA C ELECTRICAL LIGHTING FOURTH FLOOR PLAN - AREA D ELECTRICAL LIGHTING ROOF PLAN - AREA A ELECTRICAL LIGHTING ROOF PLAN - AREA B ELECTRICAL LIGHTING ROOF PLAN - AREA C ELECTRICAL LIGHTING ROOF PLAN - AREA D ELECTRICAL LIGHTING CONCESSION BUILDING PLAN ELECTRICAL LIGHTING LOCKER BUILDING PLAN ELECTRICAL LIGHTING MAINTENANCE BUILDING PLAN LIGHTNING PROTECTION PLAN - ROOFTOP LAYOUT LIGHTNING PROTECTION PLAN - UNDERSLAB LAYOUT ELECTRICAL SINGLE LINE DIAGRAM SHEET 1 ELECTRICAL SINGLE LINE DIAGRAM SHEET 2 ELECTRICAL SINGLE LINE DIAGRAM SHEET 3 GROUNDING RISER DIAGRAM ELECTRICAL POWER SCHEDULES ELECTRICAL SCHEDULES SHEET ELECTRICAL SCHEDULES SHEET 2 ELECTRICAL SCHEDULES SHEET 3 ELECTRICAL SCHEDULES SHEET 4 ELECTRICAL SCHEDULES SHEET 5 ELECTRICAL SCHEDULES SHEET 6 ELECTRICAL SCHEDULES SHEET ELECTRICAL SCHEDULES SHEET 8 ELECTRICAL SCHEDULES SHEET 9 ELECTRICAL SCHEDULES SHEET 10 ELECTRICAL SCHEDULES SHEET 11 ELECTRICAL DETAIL SHEET ELECTRICAL DETAIL SHEET 2 ELECTRICAL DETAIL SHEET 3 ELECTRICAL DETAIL SHEET 4 LIGHTING CONTROL ONE LINE DIAGRAM GROUNDING DETAILS

**TECHNOLOGY** 

**ELECTRICAL** 

NUMBER DRAWING NAME TECHNOLOGY, SECURITY & AUDIOVISUAL SYMBOL LIST TECHNOLOGY AND SECURITY SITE PLAN LOWER LEVEL TECHNOLOGY & SECURITY PLAN - AREA C LOWER LEVEL TECHNOLOGY & SECURITY PLAN - AREA D FIRST FLOOR TECHNOLOGY AND SECURITY PLAN - AREA A FIRST FLOOR TECHNOLOGY & SECURITY PLAN - AREA B FIRST FLOOR TECHNOLOGY & SECURITY PLAN - AREA C FIRST FLOOR TECHNOLOGY & SECURITY PLAN - AREA D SECOND FLOOR TECHNOLOGY & SECURITY PLAN - AREA A SECOND FLOOR TECHNOLOGY & SECURITY PLAN - AREA B SECOND FLOOR TECHNOLOGY & SECURITY PLAN - AREA SECOND FLOOR TECHNOLOGY & SECURITY PLAN - AREA D THIRD FLOOR TECHNOLOGY & SECURITY PLAN - AREA A T1-1-3B THIRD FLOOR TECHNOLOGY & SECURITY PLAN - AREA B THIRD FLOOR TECHNOLOGY & SECURITY PLAN - AREA C THIRD FLOOR TECHNOLOGY & SECURITY PLAN - AREA D FOURTH FLOOR TECHNOLOGY & SECURITY PLAN - AREA A FOURTH FLOOR TECHNOLOGY & SECURITY PLAN - AREA B FOURTH FLOOR TECHNOLOGY & SECURITY PLAN - AREA C FOURTH FLOOR TECHNOLOGY & SECURITY PLAN - AREA D CONCESSION BUILDING TECHNOLOGY & SECURITY PLAN LOCKER BUILDING TECHNOLOGY & SECURITY PLAN

MAINTENANCE BUILDING TECHNOLOGY & SECURITY PLAN




South Windsor, CT Waltham, MA 06074 Planning | Architecture | Interior Design Tel: 617.964.1700 www.draws.com

Northeast Metropolitan Regional **Vocational High** School


100 Hemlock Road Wakefield, MA 01880

> MSBA DESIGN **DEVELOPMEN** SUBMISSION

August 4th, 2022

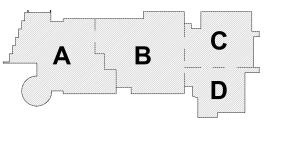

KEY PLAN MAGNETIC NORTH

 



**DRAWING LIST** 

Scale: 1/4" = 1'-0" Job No.: 20202 Drawn By: Date: August 4th, 2022