

ABBREVIATIONS	
(E)	EXISTING ITEM
(ED)	EXISTING ITEM TO BE DEMOLISHED
(F)	FUTURE
(N)	NEW
(RL)	RELOCATED ITEM
AV	AUTOMATIC AIR VENT
AC	AIR CONDITIONING UNIT
ACC	AIR COOLED CONDENSER
ACCU	AIR COOLED CONDENSING UNIT
ACD	AUTOMATIC CONTROL DAMPER
AGLC	AIR COOLED LIQUID CHILLER
AD	ACCESS DOOR
AF	AIR FILTER
ADF	ABOVE FINISHED FLOOR
AHU	AIR HANDLING UNIT
AP	ACCESS PANEL
ARCH	ARCHITECT
ID	INSIDE DIAMETER
AS	AIR SEPARATOR
ASC	APPLICABLE SECTION CONTRACTOR
ATC	AUTOMATIC TEMPERATURE CONTROL
B	BOILER
BDD	BLOCKDRIFT DAMPER
BE	BATHROOM EXHAUST
BMS	BUILDING MANAGEMENT SYSTEM
BS	BOTTOM OF DUCT
BOP	BOTTOM OF PIPE
BOS	BOTTOM OF STEEL
BTU	BTU/HOUR THERMAL UNIT
BTUH	BTU PER HOUR
BVC	BOILER VENT AND COMBUSTION AIR
CA	COMBUSTION AIR
CAP	CAPACITY
CC	COOLING COIL
CD	CEILING DIFFUSER
CFM	CUBIC FEET PER MINUTE
CH	CHILLER
CM	CONSTRUCTION MANAGER
CO	CLEAN OUT
CONN	CONNECT
CP	CONDENSATE PUMP
CT	COOLING TOWER
CUH	CONDENSING UNIT
CUH	CABINET UNIT HEATER
CV	CONNECTOR
CVB	CONSTANT VOLUME BOX
D	CONDENSATE DRAIN
DB	DRY BULB
DDC	DIRECT DIGITAL CONTROL
DE	DRYER EXHAUST
DF	DESTRATIFICATION FAN
DHW	DOMESTIC HOT WATER
Ø	DIAMETER
DN	DOWN
DP	DIFFERENTIAL PRESSURE
DWG	DRAWING
EA	EXHAUST AIR
EAT	ENTERING AIR TEMPERATURE
EC	ELECTRICAL CONTRACTOR
ECU	EVAPORATIVE CONDENSING UNIT
EDH	ELECTRIC DUCT HEATER
EF	EXHAUST FAN
EG	EXHAUST GRILLE
EMS	EMERGENCY MANAGEMENT SYSTEM
ER	EXHAUST REGISTER
ERV	EXHAUST ROOF VENT
ESP	EXTERNAL STATIC PRESSURE
ET	EXPANSION TANK
EXT	EXTENDING WATER TEMPERATURE
EXH	EXHAUST
F	FAN
F&T	FLOAT & THERMOSTATIC TRAP
FA	FREE AREA
FCU	FAN COIL UNIT
FD	FIRE DAMPER
FLA	FULL LOAD AMPS
FLR	FLOOR
FM	FLOW METER
FMS	FLOW MEASURING STATION
FO	FUEL OIL
FOB	FLAT ON BOTTOM
UF	UNDER FLOOR
UH	UNIT HEATER
FP	FAN POWERED
FPB	FAN POWERED BOX
FPM	FPS PER INCH
FPM	FEET PER MINUTE
FSD	FIRE SMOKE DAMPER
FT	FEET
FTR	FIN-TUBE RADIATION
FTU	FAN TERMINAL UNIT

ABBREVIATIONS	
GAL	GALLONS
GC	GENERAL CONTRACTOR
GE	GENERAL EXHAUST
GPM	GALLONS PER MINUTE
H	HUMIDIFIER
HC	HEATING COIL
HV	HOOD EXHAUST
HC	HEPA FILTER
HP	HORSE POWER
HP	HEAT PUMP
HQ	HEAT RECOVERY BOX
HRC	HEAT RECOVERY COIL
HV	HEATING AND VENTILATING UNIT
HVAC	HEATING VENTILATION AND AIR CONDITIONING
HX	HEAT EXCHANGER
HZ	HERTZ
ID	INSIDE DIAMETER
IN	INCHES
IRV	INTAKE ROOF VENT
KE	KITCHEN EXHAUST
KW	KILOWATTS
LAT	LEAVING AIR TEMPERATURE
LBG	LINEAR BAR GRILLE
LD	LINEAR DIFFUSER, LOUVERED DOOR
LS	LOOSE STARTER
LWT	LEAVING WATER TEMPERATURE
MAT	MIXED AIR TEMPERATURE
MBH	THOUSAND BTUS PER HOUR
MC	MECHANICAL CONTRACTOR
MD	MOTORIZED DAMPER
MECH	MECHANICAL
MER	MECHANICAL EQUIPMENT ROOM
MOD	MOTOR OPERATED DAMPER
MUA	MAKEUP AIR
MUAJ	MAKE-UP AIR UNIT
NC	NORMALLY CLOSED
NC	NOT IN CONTRACT
NO	NORMALLY OPEN
NO	NOT TO SCALE
OA	OUTSIDE AIR
OAT	OUTSIDE AIR TEMPERATURE
OBD	OPPOSED BLADE DAMPER
OC	ON CENTER
OD	OUTSIDE DIAMETER
P	PUMP
PC	PLUMBING CONTRACTOR
PD	PRESSURE DROP
PRV	PRESSURE REDUCING VALVE
PS	PACKAGE STARTER
PSI	POUNDS PER SQUARE INCH
PSG	POUNDS PER SQUARE INCH GAUGE
RA	RETURN AIR
RD	RETURN DIFFUSER
RF	RETURN FAN
RG	RETURN GRILLE
RC	RETURN IN COVER
RPM	REVOLUTIONS PER MINUTE
RTU	ROOF TOP UNIT
SA	SUPPLY AIR
SAT	SUPPLY AIR TEMPERATURE
SCT	SATURATED CONDENSING TEMPERATURE
SD	SMOKE DAMPER
SDA	SOUND ATTENUATOR
SF	SQUARE FEET
SF	SUPPLY AIR FAN
SG	SUPPLY GRILLE
SP	STATIC PRESSURE
SPD	SPEED
SR	SUPPLY REGISTER
SST	STATIC SUCTION TEMPERATURE
TA	TRANSFER AIR
TE	TOILET EXHAUST
TF	TRANSFER FAN
TG	TRANSFER GRILLE
TOS	TOP OF STEEL
TSP	TOTAL STATIC PRESSURE
UC	UNDERCUT DOOR
UF	UNDER FLOOR
UH	UNIT HEATER
UON	UNLESS OTHERWISE NOTED
UV	UNIT VENTILATOR
VAV	VARIABLE AIR VOLUME
VD	VOLUME DAMPER
VFD	VARIABLE FREQUENCY DRIVE
VI	VIBRATION ISOLATOR
VF	VERIFY IN FIELD
VRF	VARIABLE REFRIGERANT FLOW
WBS	WET BULB TEMPERATURE
WMS	WIRE MESH SCREEN
WSHP	WATER SOURCE HEAT PUMP

MECHANICAL VALVES AND ACCESSORIES	
	ISOLATION VALVE SEE SPECIFICATIONS FOR TYPE
	2-WAY CONTROL VALVE (DDC OR PNEUMATIC)
	3-WAY CONTROL VALVE (DDC OR PNEUMATIC)
	3-WAY CONTROL VALVE (MOTORIZED)
	THERMOSTATIC CONTROL VALVE
	SOLENOID VALVE
	DIFFERENTIAL PRESSURE VALVE
	GATE VALVE
	GLOBE VALVE
	OSY VALVE
	PRESSURE REDUCING VALVE
	SAFETY RELIEF VALVE
	ANGLE VALVE
	BALL VALVE
	BALL VALVE WITH MEMORY STOP
	BUTTERFLY VALVE
	CHECK VALVE WITH TEST PORTS
	CHECK VALVE (Left & Right)
	PRESSURE GAUGE
	PRESSURE GAUGE WITH COOK
	PRESSURE GAUGE WITH SYPHON AND COOK
	PRESSURE TEMPERATURE GAUGE PORT
	FLOAT & THERMOSTATIC TRAP
	THERMOSTATIC TRAP
	STEAM TRAP SEE SPECIFICATION FOR TYPE
	SITE GLASS
	THERMOMETER
	THERMOMETER WITH WELL
	CONCENTRIC PIPE REDUCER
	ECCENTRIC PIPE REDUCER
	AUTOMATIC AIR VENT
	MANUAL AIR VENT
	THERMOSTATIC AIR VENT
	VACUUM BREAKER
	PIPE CAP
	CONCENTRIC PIPE REDUCER
	PIPE RISIN / OR RISING AND DROPPING
	PIPE CONNECTION TOP OF MAIN
	PIPE TURNING DOWN
	TEE CONNECTION
	UNION
	PIPE CONNECTION BOTTOM OF MAIN
	FLANGED CONNECTION
	PIPE UP TO RADIATION
	STRAINER
	STRAINER AND DRAIN VALVE W HOSE END CONN AND CAP
	FLEXIBLE CONNECTOR
	DIRECTION OF FLOW
	FLOW MEASURING DEVICE
	EXPANSION COMPENSATOR
	PIPE HEAT TRACE ELEMENT

MECHANICAL PIPING LEGEND	
	(B0) BLOW DOWN
	(BF) BOILER FEED
	(CA) COMPRESSED AIR
	(CD) CONDENSATE DRAIN
	(CF) CHEMICAL FEED
	(CHWR) CHILLED WATER RETURN
	(CHWS) CHILLED WATER SUPPLY
	(CLO) CONDUIT TANK LEAK
	(COND) CONDENSATE
	(CTR) COOLING TOWER RETURN
	(CTS) COOLING TOWER SUPPLY
	(CW) COLD WATER CITY WATER MAKE UP
	(CWR) CONDENSER WATER RETURN
	(CWS) CONDENSER WATER SUPPLY
	(D) DRAIN
	(DTR) DUAL TEMP RETURN
	(DTS) DUAL TEMP SUPPLY
	(E) EXISTING PIPING
	(FOG) FUEL OIL GAUGE
	(FOR) FUEL OIL RETURN
	(FOS) FUEL OIL SUPPLY
	(FOV) FUEL OIL VENT
	(GR) GLYCOL WATER RETURN
	(GS) GLYCOL WATER SUPPLY
	(LPR) LOW PRESS COND RETURN
	(HPS) HIGH PRESS STEAM COND RETURN
	(HPWR) HEAT PUMP WATER RETURN
	(HPWS) HEAT PUMP WATER SUPPLY
	(HWR) HOT WATER RETURN
	(HWS) HOT WATER SUPPLY
	(LPS) LOW PRESS COND RETURN
	(LPS) LOW PRESS STEAM SUPPLY
	(MPR) MED PRESS COND RETURN
	(MPS) MED PRESS STEAM SUPPLY
	(NPW) NON POTABLE WATER
	(PC) PUMPED CONDENSATE
	(PSC) PUMPED STEAM CONDENSATE
	(PHWR) PRIMARY HOT WATER RETURN
	(PHWS) PRIMARY HOT WATER SUPPLY
	(RL) REFRIG LIQUID
	(RS) REFRIG SUCTION
	(SCHWR) SECONDARY CHILLED WATER RETURN
	(SCHWS) SECONDARY CHILLED WATER SUPPLY
	(SHWR) SECONDARY HOT WATER RETURN
	(SHWS) SECONDARY HOT WATER SUPPLY
	(TSTAT) THERMOSTAT
	(V) VENT

DUCTWORK SYMBOLS DOUBLE LINE	
	RECTANGULAR DUCTWORK - FIRST DIMENSION IS SIZE SHOWN (IN)
	ROUND DUCTWORK DIAMETER (IN)
	FLAT OVAL DUCT
	CAPPED DUCT
	EXISTING DUCTWORK
	EXISTING DUCTWORK TO BE REMOVED
	CAPPED ACOUSTICALLY LINED DUCTWORK
	DOUBLE-WALL DUCTWORK
	SUPPLY/OUTSIDE AIR DUCTWORK UP
	SUPPLY/OUTSIDE AIR DUCTWORK DOWN
	RETURN AIR DUCTWORK UP
	RETURN AIR DUCTWORK DOWN
	EXHAUST AIR DUCTWORK UP
	EXHAUST AIR DUCTWORK DOWN
	FLEXIBLE EQUIPMENT CONNECTION
	FLEXIBLE DUCT
	CHANGE OF ELEVATION IN DIRECTION OF AIR FLOW R-RISE & D-DROP
	RECTANGULAR TO RECTANGULAR TRANSITION
	RECTANGULAR TO ROUND TRANSITION
	MITERED ELBOW WITH TURNING VANES
	MITERED ELBOW
	RADIUS ELBOW
	SPIN COLLAR
	90° SPLIT TEE WITH TURNING VANES
	BELL MOUTH BRANCH DUCT TAKE OFF
	BELL MOUTH BRANCH DUCT TAKE OFF WITH DAMPER
	BRANCH DUCT TAKE OFF
	BACK DRAFT DAMPER
	COMBINATION FIRE SMOKE DAMPER WITH SMOKE DETECTOR
	FIRE DAMPER
	MOTORIZED DAMPER
	SMOKE DAMPER WITH SMOKE DETECTOR
	VOLUME DAMPER
	DUCT MOUNTED SMOKE DETECTOR
	SIDE WALL MOUNTED SUPPLY REGISTER
	SIDE WALL MOUNTED RETURN / EXHAUST REGISTER / GRILLE
	ELEVATION VIEW SIDE WALL MOUNTED EXHAUST REGISTER / GRILLE
	ELEVATION VIEW SIDE WALL MOUNTED RETURN REGISTER / GRILLE
	ELEVATION VIEW SIDE WALL MOUNTED SUPPLY REGISTER
	TRANSFER DUCT WITH ACOUSTICAL LINING
	SUPPLY / INTAKE OR DOOR UNDERCUT PRESSURIZATION
	EXHAUST / RETURN / TRANSFER
	LOUVERED DOOR PRESSURIZATION
	SUPPLY DIFFUSER 4 - WAY THROW
	SUPPLY DIFFUSER 3 - WAY THROW
	SUPPLY DIFFUSER 2 - WAY THROW
	SUPPLY DIFFUSER 1 - WAY THROW
	RETURN REGISTER / GRILLE
	EXHAUST REGISTER / GRILLE
	SUPPLY AIR DIFFUSER BELOW DUCT
	RETURN AIR DIFFUSER BELOW DUCT
	EXHAUST AIR DIFFUSER BELOW DUCT
	LINEAR DIFFUSER
	ACCESS DOOR IN CEILING
	DUCT MOUNTED ACCESS DOOR - ACCESS PANEL

INSTRUMENTATION SYMBOLS	
	CARBON DIOXIDE SENSOR
	CARBON DIOXIDE SENSOR DUCT MOUNTED
	CARBON MONOXIDE SENSOR
	CARBON MONOXIDE SENSOR DUCT MOUNTED
	COMBINATION TEMPERATURE AND CARBON DIOXIDE SENSOR
	VRF MANUFACTURER TEMPERATURE SENSOR/CONTROLLER
	CURRENT SENSOR
	FLOW SENSOR
	FREEZE STAT
	LEAK DETECTOR
	HUMIDITY SENSOR
	HUMIDITY SENSOR DUCT MOUNTED
	HYDROGEN SENSOR
	REFRIGERANT LEAK SENSOR
	REFRIGERANT LEAK SENSOR DUCT MOUNTED
	SMOKE DETECTOR
	SMOKE DETECTOR DUCT MOUNTED
	STATIC PRESSURE SENSOR
	TEMPERATURE SENSOR
	TEMPERATURE SENSOR DUCT MOUNTED
	COMBINATION TEMPERATURE RELATIVE HUMIDITY SENSOR
	COMBINATION TEMPERATURE RELATIVE HUMIDITY SENSOR DUCT MOUNTED
	EMERGENCY POWER REQUIRED
	SWITCH
	PACKAGED STARTER BY MECHANICAL
	LOOSE STARTER BY ELECTRICAL
	VARIABLE FREQUENCY DRIVE
	FLOW MEASURING STATION
MISC. LEGEND / TAGS	
	DIFFUSER, REGISTER, GRILLE DESIGNATION
	NECK SIZE OR LENGTH IF LINEAR DIFFUSER
	AIR QUANTITY - CFM
	SCHEDULED EQUIPMENT TYPE (WITHOUT MOTOR)
	SCHEDULED REFERENCE NUMBER
	SCHEDULED EQUIPMENT TYPE (WITH MOTOR)
	SCHEDULED REFERENCE NUMBER
	EQUIPMENT TYPE
	EQUIPMENT LENGTH
	EQUIPMENT CAPACITY - MBH/KW
	SECTION SYMBOL
	SECTION DESCRIPTION
	DRAWING NUMBER LOCATION
	DETAIL NUMBER
	DRAWING NUMBER LOCATION
	POWERED DAMPER
	DAMPER TYPE (FSD OR SD)
	ASSOCIATED FAN SYSTEM
	NORMAL DAMPER (NON-ENERGIZED) POSITION
	CONNECT NEW TO EXISTING
	LIMIT OF REMOVAL
	DISTANCE TO FINISH FLOOR (FEET & INCHES) FROM BOTTOM OF DUCT OR PIPE
	RISER DESIGNATION TYPE NUMBER
	DEMOLITION SHEET NUMBER X
	NEW WORK SHEET NUMBER X
	REVISION NUMBER X

DESIGN CONDITIONS	
TEMPERATURES AND HUMIDITIES	TEMPERATURES AND HUMIDITIES
WINTER: OUTDOOR AIR TEMPERATURE: 9°F (9.6%) INDOOR AIR TEMPERATURES: 70° GENERAL SPACES 65° EXTERIOR STORAGE/MECHANICAL SPACES	CITY: STATE BOSTON, MA SUB-LOCATION _____ ELEVATION, AMSL _____
SUMMER: OUTDOOR AIR TEMPERATURE: 91°F (33.3%) INDOOR AIR TEMPERATURES: 75°F (23.9%) GENERAL SPACES	
* MEAN CONCOMITANT WET BULB FUNDAMENTALS HANDBOOK, CHAPTER 14, APPENDIX AND IECC 2018, CLIMATE ZONE 5A	WEATHER DATA BASED ON 2017 ASHRAE FUNDAMENTALS HANDBOOK, CHAPTER 14, APPENDIX AND IECC 2018, CLIMATE ZONE 5A

DRA

Drumme Rosane Anderson, Inc.
225 Oakland Road
Studio 205
South Windsor, CT 06074
Tel: 817.984.1702
www.dra.com

260 Charles Street
Studio 300
Waltham, MA 02453

Northeast Metropolitan Regional Vocational High School

Wakefield, MA 01880

PROJECT NORTH

MAGNETIC NORTH

MECHANICAL LEGENDS AND ABBREVIATIONS

Scale: NTS
Job No.: 20202
Drawn By: DRA
Date: January 13, 2023

M0-0-1

DRAWING LIST - MECHANICAL	
REVISION LEGEND	NEW ISSUE REVISED ISSUE REVISED, NOT ISSUED REMOVED FROM DRAWING SET ISSUED, NOT REVISED
DRAWING NUMBER	DRAWING TITLE
M0-0-1	MECHANICAL LEGENDS AND ABBREVIATIONS
M0-0-2	MECHANICAL GENERAL NOTES
M0-0-3	MECHANICAL SCOPE OF WORK
M0-1-0C	MECHANICAL DUCTWORK LOWER LEVEL FLOOR PLAN - AREA C
M0-1-0D	MECHANICAL DUCTWORK LOWER LEVEL FLOOR PLAN - AREA D
M0-1-1A	MECHANICAL DUCTWORK FIRST FLOOR PLAN - AREA A
M0-1-1B	MECHANICAL DUCTWORK FIRST FLOOR PLAN - AREA B
M0-1-1C	MECHANICAL DUCTWORK FIRST FLOOR PLAN - AREA C
M0-1-1D	MECHANICAL DUCTWORK FIRST FLOOR PLAN - AREA D
M0-1-2A	MECHANICAL DUCTWORK SECOND FLOOR PLAN - AREA A
M0-1-2B	MECHANICAL DUCTWORK SECOND FLOOR PLAN - AREA B
M0-1-2C	MECHANICAL DUCTWORK SECOND FLOOR PLAN - AREA C
M0-1-2D	MECHANICAL DUCTWORK SECOND FLOOR PLAN - AREA D
M0-1-3A	MECHANICAL DUCTWORK THIRD FLOOR PLAN - AREA A
M0-1-3B	MECHANICAL DUCTWORK THIRD FLOOR PLAN - AREA B
M0-1-3C	MECHANICAL DUCTWORK THIRD FLOOR PLAN - AREA C
M0-1-3D	MECHANICAL DUCTWORK THIRD FLOOR PLAN - AREA D
M0-1-4A	MECHANICAL DUCTWORK FOURTH FLOOR PLAN - AREA A
M0-1-4B	MECHANICAL DUCTWORK FOURTH FLOOR PLAN - AREA B
M0-1-4C	MECHANICAL CONVECTION BUILDING PLAN
M0-1-4D	MECHANICAL LOCKER BUILDING PLAN
M0-1-4E	MECHANICAL MAINTENANCE BUILDING PLAN
M0-1-4F	MECHANICAL ROOF PLAN - AREA A
M0-1-4G	MECHANICAL ROOF PLAN - AREA B
M0-1-4H	MECHANICAL ROOF PLAN - AREA C
M0-1-4I	MECHANICAL ROOF PLAN - AREA D
M0-1-4J	MECHANICAL PIPING LOWER LEVEL FLOOR PLAN - AREA C
M0-1-4K	MECHANICAL PIPING LOWER LEVEL FLOOR PLAN - AREA D
M0-1-4L	MECHANICAL PIPING FIRST FLOOR PLAN - AREA A
M0-1-4M	MECHANICAL PIPING FIRST FLOOR PLAN - AREA B
M0-1-4N	MECHANICAL PIPING FIRST FLOOR PLAN - AREA C
M0-1-4O	MECHANICAL PIPING FIRST FLOOR PLAN - AREA D
M0-1-4P	MECHANICAL PIPING SECOND FLOOR PLAN - AREA A
M0-1-4Q	MECHANICAL PIPING SECOND FLOOR PLAN - AREA B
M0-1-4R	MECHANICAL PIPING SECOND FLOOR PLAN - AREA C
M0-1-4S	MECHANICAL PIPING SECOND FLOOR PLAN - AREA D
M0-1-4T	MECHANICAL PIPING THIRD FLOOR PLAN - AREA A
M0-1-4U	MECHANICAL PIPING THIRD FLOOR PLAN - AREA B
M0-1-4V	MECHANICAL PIPING THIRD FLOOR PLAN - AREA C
M0-1-4W	MECHANICAL PIPING THIRD FLOOR PLAN - AREA D
M0-1-4X	MECHANICAL PIPING FOURTH FLOOR PLAN - AREA A
M0-1-4Y	MECHANICAL PIPING FOURTH FLOOR PLAN - AREA B
M0-0-1	MECHANICAL ENLARGED PLANS
M0-0-2	MECHANICAL ENLARGED PLANS
M0-0-3	MECHANICAL ENLARGED PLANS
M0-0-1	MECHANICAL VRF SYSTEM DIAGRAMS SHEET #1
M0-0-2	MECHANICAL VRF SYSTEM DIAGRAMS SHEET #2
M0-0-3	MECHANICAL VRF SYSTEM DIAGRAMS SHEET #3
M0-0-4	MECHANICAL AIR RISER DIAGRAMS
M0-0-1	MECHANICAL DETAILS SHEET #1
M0-0-2	MECHANICAL DETAILS SHEET #2
M0-0-3	MECHANICAL DETAILS SHEET #3
M0-0-1	MECHANICAL SCHEDULES SHEET #1
M0-0-2	MECHANICAL SCHEDULES SHEET #2
M0-0-3	MECHANICAL SCHEDULES SHEET #3

GENERAL NOTES	MECHANICAL GENERAL NOTES	MECHANICAL GENERAL NOTES
1. THE WORK TO BE DONE UNDER THESE SPECIFICATIONS AND THE DRAWINGS CONSISTS OF PROVIDING ALL EQUIPMENT, MATERIALS, LABOR AND SERVICES AND PERFORMING ALL OPERATIONS TO COMPLETE THE CONSTRUCTION WORK FOR THIS PROJECT. ANY WORK NOT SPECIFICALLY COVERED BY THESE SPECIFICATIONS OR INDICATED ON THE CONTRACT DRAWINGS, BUT NECESSARY TO COMPLETE OR PERFECT ANY PART OF THIS INSTALLATION IN A SUBSTANTIAL MANNER, SHALL BE PROVIDED WITHOUT EXTRA COST TO THE OWNER. 2. THE WORK SHALL CONFORM TO THE MORE STRINGENT OF ALL APPLICABLE CODES & REGULATIONS, UL [AND FM] GUIDELINES, (USED REQUIREMENTS), MANUFACTURER'S LITERATURE AND RECOMMENDATIONS, (BUILDING OPERATOR'S REQUIREMENTS), AND TO THE REQUIREMENTS OF FEDERAL, STATE AND LOCAL REGULATORY AGENCIES AND AUTHORITIES HAVING JURISDICTION. 3. THE DRAWINGS ARE DIAGRAMMATIC IN NATURE AND INDICATE THE EXTENT, GENERAL CHARACTER, LOCATION AND ARRANGEMENT OF THE WORK UNDER THIS CONTRACT. EXACT LOCATIONS OF ALL COMPONENTS ARE TO BE DETERMINED IN THE FIELD AND BY THE ACTUAL BUILDING CONDITIONS, WHERE JOB CONDITIONS REQUIRE MINOR CHANGES OR ADJUSTMENTS IN THE INDICATED LOCATIONS OR ARRANGEMENT OF THE WORK. SUCH CHANGES SHALL BE PROVIDED WITHOUT EXTRA COST. THE CONTRACTOR SHALL RE-INSTALL EQUIPMENT THAT HAS INADEQUATE OR UNSAFE ACCESSIBILITY. 4. INSTALLATION OF WORK SHALL PROVIDE REASONABLE ACCESSIBILITY FOR OPERATION, INSPECTION AND MAINTENANCE OF EQUIPMENT AND ACCESSORIES. PROVIDE CLEARANCES REQUIRED BY MANUFACTURERS AND APPLICABLE CODES. ALL CEILING MOUNTED EQUIPMENT SHALL BE INSTALLED IN SUCH A MANNER THAT LIGHTS, PIPING, AND DUCTWORK DO NOT BLOCK ACCESS TO EQUIPMENT AND RELATED ACCESSORIES. 5. THE TERM "FURNISH" SHALL MEAN TO OBTAIN AND SUPPLY TO THE JOB SITE. THE TERM "INSTALL" SHALL MEAN TO FIX IN POSITION AND CONNECT FOR USE. THE TERM "PROVIDE" SHALL MEAN TO FURNISH AND INSTALL. THE TERM "MECHANICAL WORK," "ELECTRICAL WORK," "PLUMBING WORK," ETC. SHALL MEAN ALL LABOR, MATERIAL, EQUIPMENT, SCAFFOLDING, RIGGING, TOOLS, SUPERVISION, SERVICES AND OTHER INCIDENTALS NECESSARY FOR COMPLETE AND OPERABLE INSTALLATION. 6. THE CM/SG SHALL MAKE SETS OF THE BID DOCUMENTS CONSISTING OF COMPLETE SETS OF DRAWINGS AND SPECIFICATIONS, AND ISSUE THEM TO EACH OF THE PRIME AND SUB-CONTRACTORS. EVERY PRIME AND SUB-CONTRACTOR ON EACH BIDDING TEAM SHALL RECEIVE COMPLETE SETS OF DRAWINGS AND SPECIFICATIONS. THERE ARE NOTES AND CROSS REFERENCES FOR VARIOUS TRADE CONTRACTORS IN MULTIPLE TRADE OR DISCIPLINE DRAWINGS AND SPECIFICATIONS. THIS REQUIRES EACH CONTRACTOR IS TO RECEIVE COMPLETE SETS OF THE BID DOCUMENTS. IT IS THE CONTRACTOR'S RESPONSIBILITY TO OBTAIN THESE DRAWINGS FROM CM/SG. EACH CONTRACTOR IS RESPONSIBLE FOR THEIR WORK AS NOTED ON THE OTHER DISCIPLINE DOCUMENTS. BIDDERS ARE RESPONSIBLE FOR ALL COSTS FOR EACH SET OF BID DOCUMENTS REQUESTED. 7. CONTRACTOR IS RESPONSIBLE FOR PROVIDING A FULL COORDINATION EFFORT IN ORDER TO CREATE A FINALIZED COORDINATED LAYOUT OF ALL EQUIPMENT, SYSTEMS, DUCTWORK, PIPING AND ALL OTHER ITEMS WITHIN THEIR RESPECTIVE SCOPE. THE CONTRACTORS COORDINATION EFFORT SHALL INCLUDE COORDINATED INFORMATION FROM ALL OTHER TRADE CONTRACTORS INVOLVED IN THE PROJECT SCOPE IN ORDER TO PROVIDE COORDINATION BETWEEN TRADES AND ALL EXISTING CONDITIONS. ALL ERRORS MADE AS A RESULT OF A LACK OF COORDINATION SHALL BE THE RESPONSIBILITY OF THE CONTRACTOR AND CORRECTED AT NO ADDITIONAL COST TO THE PROJECT. MINOR RELOCATIONS AND SHIFTS OF EQUIPMENT, DUCTWORK, AND PIPING WHICH DO NOT CHANGE THE DESIGN INTENT INDICATED ON THE CONTRACT DOCUMENTS, REQUIRED TO ACCOMMODATE FIELD CONDITIONS ARE AT THE CONTRACTORS DISCRETION AND DO NOT REQUIRE ENGINEER APPROVAL. 8. CONTRACTOR SHALL ARRANGE AND OBTAIN ALL PERMITS, INSPECTIONS AND APPROVALS, AND PAY ALL RELATED FEES. 9. THE DRAWINGS INDICATE APPROXIMATE LOCATIONS BASED UPON INFORMATION OBTAINED WITHOUT REMOVING CEILING, TILES OR WALLS. THEREFORE, THE CONTRACTOR SHALL INCLUDE IN THEIR BID CONTINGENCY COSTS TO ADDRESS CONFLICTS BETWEEN DESIGN AND EXISTING CONDITIONS. ANY CHANGES AND/OR MODIFICATIONS MUST BE REVIEWED AND APPROVED BY THE ENGINEER AND/OR OWNER'S REPRESENTATIVE PRIOR TO CONSTRUCTION. 10. FOR ANY DISCREPANCY BETWEEN DRAWINGS AND/OR SPECIFICATIONS, THE CONTRACTOR SHALL BASE THEIR BID UPON THE MOST STRINGENT REQUIREMENT (QUALITY, QUANTITY, SIZE, ETC.). THE CONTRACTOR SHALL IDENTIFY DISCREPANCIES AS PART OF THEIR BID. 11. PRIOR TO DEMOLITION, THE CONTRACTOR SHALL LOG ALL EXISTING EQUIPMENT AND TRACE ELECTRICAL, FIRE ALARM, AND CONTROL CIRCUITS THAT SERVE SUCH EQUIPMENT. 12. ALL SERVICES TO EXISTING BUILDINGS SHALL BE MAINTAINED DURING CONSTRUCTION UNLESS OTHERWISE INDICATED. CONTRACTOR SHALL COORDINATE ALL SYSTEM SHUT DOWNS AND TIMING WITH OWNER. 13. THE CONTRACTOR SHALL EFFECTIVELY PROTECT ALL MATERIALS AND EQUIPMENT FROM ENVIRONMENTAL AND PHYSICAL DAMAGE UNTIL FINAL ACCEPTANCE. CLOSE AND PROTECT ALL OPENINGS DURING CONSTRUCTION. PROVIDE NEW MATERIALS AND EQUIPMENT TO REPLACE ITEMS DAMAGED. 14. EXISTING EQUIPMENT THAT INTERFERES WITH NEW ARRANGEMENT SHALL BE REMOVED, REINSTALLED, RELOCATED, REROUTED, EXTENDED OR ABANDONED AS REQUIRED, TO SUIT THE NEW ARRANGEMENT. 15. WHERE BEAMS ARE INDICATED TO BE PENETRATED WITH DUCTWORK AND/OR PIPING, CAREFULLY COORDINATE SIZES AND LOCATIONS OF THE ELEMENTS BEFORE FABRICATION. COORDINATE WITH FINAL LOCATION OF BEAM PENETRATIONS AND SHEAR WALL PENETRATIONS. 16. CONTRACTOR SHALL COORDINATE LOCATION OF ALL WALL, FLOOR AND ROOF OPENINGS WITH STRUCTURAL AND OTHER TRADES. 17. PROVIDE CUTTING AND PATCHING AS REQUIRED AND WHERE NECESSARY TO ACCOMMODATE NEW WORK AND THE REPAIR OF EXISTING WORK. 18. WHEN WORK INVOLVES CONTACT WITH MATERIALS CONTAINING ASBESTOS, PCB, OR OTHER TOXIC MATERIALS, NOTIFY OWNER, WHO WILL ESTABLISH PROCEDURES FOR REMEDIATION AND REMOVAL. 19. CONTRACTOR SHALL SCHEDULE THE WORK UNDER THIS CONTRACT WITH WORK OF OTHER TRADES AS NOT TO DELAY THE OVERALL PROGRESS OF THE PROJECT. 20. CONTRACTOR SHALL NOTIFY ARCHITECT/ENGINEER OF ANY CONFLICTS PRIOR TO PURCHASING EQUIPMENT AND PRIOR TO CUTTING OPENINGS. 21. CONTRACTOR SHALL PROVIDE SHOP DRAWINGS PER SPECIFICATIONS PRIOR TO PURCHASING OR INSTALLING EQUIPMENT AND SYSTEMS INDICATED ON CONTRACT DOCUMENTS. PRIOR TO SUBMITTAL, CONTRACTOR SHALL VERIFY THAT ADEQUATE SPACE EXISTS FOR THE SUBMITTED EQUIPMENT. SHOP DRAWINGS MUST BE REVIEWED BY ARCHITECT/ENGINEER. 22. CONTRACTOR SHALL BE RESPONSIBLE FOR ALL COSTS INCURRED BY OTHER TRADES DUE TO SUBSTITUTION OF OTHER THAN SCHEDULED EQUIPMENT. WHEN EQUIPMENT FURNISHED IS DIFFERENT THAN INDICATED, THE COST OF ADDITIONAL ELECTRICAL SERVICE, STRUCTURAL, AND RELATED WORK SHALL BE PAID BY THIS CONTRACTOR. 23. ALL WORK SHALL BE EXECUTED IN A NEAT AND WORKMANLIKE MANNER AND SHALL BE DONE IN ACCORDANCE WITH GOOD TRADE PRACTICE AND IN CONFORMANCE WITH APPLICABLE MANUFACTURER'S RECOMMENDATIONS. 24. CONTRACTOR SHALL REMOVE ALL TRASH, DEBRIS AND DEMOLITION MATERIAL FROM PREMISES AT THE END OF EACH DAY. 25. RESTORE ALL SURFACES (WALLS, CEILINGS, FLOORS AND ROOFS) THAT ARE DAMAGED BY THE WORK OF THIS CONTRACT TO THEIR ORIGINAL CONDITION AT NO EXTRA COST TO THE OWNER. 26. PRIOR TO EQUIPMENT STARTUP, CONTRACTOR SHALL PERFORM THE SPECIFIED STARTUP AND COMMISSIONING PROCEDURES. 27. IN THE ABSENCE OF OTHER SPECIFIC INSTRUCTIONS, ALL WORK AND MATERIALS SUPPLIED SHALL BE GUARANTEED FOR A PERIOD OF ONE (1) YEAR FROM THE DATE OF THEIR ACCEPTANCE BY THE OWNER. 28. BALA CONSULTING ENGINEERS, INC. (BALA) WILL PROVIDE CONTRACTOR WITH ELECTRONIC CAD FILES OF THE ENGINEERING DESIGNS, AT A COST OF \$88.00 PER DRAWING SHEET/FILE, FOR THE SOLE USE IN EXPEDITING SHOP DRAWINGS. BALA'S FILES SHALL NOT BE DIRECTLY COPIED AND ISSUED AS SHOP DRAWINGS. THE CONTRACTOR SHALL BE RESPONSIBLE FOR ALL FIELD COORDINATION, DIMENSIONING AND ADHERENCE TO THE SHOP DRAWING REQUIREMENTS AS NOTED IN THE SPECIFICATIONS. SHOULD THE SHOP DRAWINGS SUBMITTED PROVE TO BE A DIRECT COPY OF OUR FILES WITHOUT THE NECESSARY FIELD COORDINATION, DIMENSIONING AND ADHERENCE TO THE SHOP DRAWING REQUIREMENTS AS NOTED IN THE SPECIFICATIONS, THESE SHOP DRAWINGS WILL BE RETURNED AS REJECTED. BALA CONSULTING ENGINEERS, INC. (BALA) WILL PROVIDE CONTRACTOR WITH ELECTRONIC CAD FILES OF THE ENGINEERING DESIGNS, AT A COST OF \$88.00 PER DRAWING SHEET/FILE, FOR THE SOLE USE IN EXPEDITING SHOP DRAWINGS. BALA'S FILES SHALL NOT BE DIRECTLY COPIED AND ISSUED AS SHOP DRAWINGS. THE CONTRACTOR SHALL BE RESPONSIBLE FOR ALL FIELD COORDINATION, DIMENSIONING AND ADHERENCE TO THE SHOP DRAWING REQUIREMENTS AS NOTED IN THE SPECIFICATIONS. SHOULD THE SHOP DRAWINGS SUBMITTED PROVE TO BE A DIRECT COPY OF OUR FILES WITHOUT THE NECESSARY FIELD COORDINATION, DIMENSIONING AND ADHERENCE TO THE SHOP DRAWING REQUIREMENTS AS NOTED IN THE SPECIFICATIONS, THESE SHOP DRAWINGS WILL BE RETURNED AS REJECTED. BALA'S ELECTRONIC FILES ARE SAVED IN VERSION (REVIT, AUTOCAD) [2016, 2017, 2018] AND ARE COMPATIBLE WITH ALL VERSIONS AFTER THAT. BALA MAKES NO REPRESENTATION AS TO THE COMPATIBILITY OF THESE FILES WITH THE CONTRACTOR'S HARDWARE OR THEIR SOFTWARE. DATA CONTAINED ON THESE ELECTRONIC FILES ARE PART OF BALA'S "INSTRUMENTS OF SERVICE" AND ARE COPYRIGHTED. CONTRACTOR'S USE OF FILES IS FOR THE SOLE PURPOSE AS A CONVENIENCE IN THE PREPARATION OF DRAWINGS FOR THE REFERENCED PROJECT. ANY OTHER USE OR REUSE BY CONTRACTOR IS UNLAWFUL.	1. MECHANICAL CONTRACTOR SHALL EXAMINE THE DRAWINGS OF ALL TRADES AND COORDINATE THEIR WORK PRIOR TO ANY INSTALLATIONS TO AVOID INTERFERENCE WITH STRUCTURE, AND ALL EQUIPMENT ABOVE AND BELOW THE CEILING. THE MECHANICAL CONTRACTOR SHALL VERIFY ALL DIMENSIONS AND FIELD CONDITIONS AT THE SITE PRIOR TO BID AND PURCHASE OF EQUIPMENT/MATERIALS. THE CONTRACTOR SHALL PROVIDE VALUE FOR SAME IN THEIR BID. IT SHALL BE THE RESPONSIBILITY OF THE CONTRACTOR TO VERIFY FIELD CONDITIONS AT THE SITE AND NOTIFY THE OWNER, ARCHITECT AND ENGINEER OF ANY DISCREPANCIES PRIOR TO COMMENCING WITH THE WORK. 2. FOR ANY DISCREPANCY BETWEEN DRAWINGS AND/OR SPECIFICATIONS, THE MECHANICAL CONTRACTOR SHALL BASE THEIR BID UPON THE MOST STRINGENT REQUIREMENT (QUALITY, QUANTITY, SIZE, ETC.). THE CONTRACTOR SHALL IDENTIFY DISCREPANCIES AS PART OF THEIR BID. 3. THE MECHANICAL CONTRACTOR SHALL PERFORM ALL CUTTING AND PATCHING OF EXISTING CONSTRUCTION REQUIRED BY THEIR WORK. ALL FINISHES SHALL MATCH EXISTING. STRUCTURAL MEMBERS SHALL NOT BE CUT UNLESS APPROVED BY OWNER'S REPRESENTATIVE. PAINTING SHALL BE BY GENERAL CONTRACTOR. WHERE EQUIPMENT IS REMOVED, CONTRACTOR TO REFRESH AREA TO MATCH EXISTING. CONTRACTOR SHALL BE RESPONSIBLE FOR MAINTAINING INTEGRITY OF ALL STRUCTURAL ELEMENTS. 4. THE MECHANICAL CONTRACTOR SHALL EFFECTIVELY PROTECT ALL MATERIALS AND EQUIPMENT FROM ENVIRONMENTAL AND PHYSICAL DAMAGE UNTIL FINAL ACCEPTANCE. CLOSE AND PROTECT ALL OPENINGS DURING CONSTRUCTION. PROVIDE NEW MATERIALS AND EQUIPMENT TO REPLACE ITEMS DAMAGED. 5. EXISTING MECHANICAL EQUIPMENT THAT INTERFERES WITH NEW ARRANGEMENT SHALL BE REMOVED, REINSTALLED, RELOCATED, REROUTED, EXTENDED OR ABANDONED AS REQUIRED, TO SUIT THE NEW ARRANGEMENT. 6. ALL MATERIALS, EQUIPMENT AND INSTALLATIONS SHALL BE IN STRICT ACCORDANCE WITH SMACNA AND ASHRAE GUIDELINES, UNLESS OTHERWISE NOTED. 7. EQUIPMENT INDICATED ON THE DRAWINGS, TOGETHER WITH ITS BASE AND/OR SUPPORT, DUCTWORK CONNECTIONS, SERVICE CLEARANCES, WALL, FLOOR AND ROOF PENETRATIONS, AND ELECTRICAL REQUIREMENTS IS BASED ON THE MODEL INDICATED IN THE SCHEDULES. IF CONTRACTOR FURNISHES AN EQUIVALENT SUBSTITUTION, THE CONTRACTOR SHALL MAKE THE REQUIRED MODIFICATIONS IN THE WORK WITHOUT CHANGE IN CONTRACT AMOUNT. 8. THE CONTRACTOR SHALL INCLUDE IN HIS BID ALL COSTS RELATED TO REMOVING AND REPLACING ALL CEILING AS REQUIRED FOR THE MECHANICAL WORK ON THIS PROJECT. PROVIDE SELECTIVE CEILING DEMOLITION TO PLACE NEW DUCTWORK AND DIFFUSERS. REPLACE DAMAGED CEILING TILES AND GRIDS RESULTING FROM DEMOLITION. NEW CEILING TILES SHALL MATCH WITH EXISTING. 9. COORDINATE MECHANICAL SYSTEM INSTALLATION WITH EXISTING CONDITIONS. VISIT SITE PRIOR TO BID AND INVESTIGATE REQUIREMENTS FOR MECHANICAL SYSTEM INSTALLATION. SEE THE SPECIFICATIONS FOR ADDITIONAL REQUIREMENTS. 10. COORDINATE LOCATION OF ALL WALL, FLOOR AND ROOF OPENINGS WITH STRUCTURAL AND OTHER TRADES. 11. COORDINATE LOCATION OF NEW DUCTWORK, AIR DEVICES AND EQUIPMENT WITH LIGHT FIXTURES, SPRINKLER PIPING AND HYDRONIC PIPING. 12. COORDINATE THE LOCATIONS OF ALL EQUIPMENT AND REGISTERS WITH THE LATEST ARCHITECTURAL DRAWINGS PRIOR TO PERFORMING AND ROUGH-IN WORK FOR THE UTILITIES. 13. COORDINATE THERMOSTATS WITH FINAL DIFFUSER LOCATIONS. THERMOSTATS SHALL NOT BE MOUNTED IN THE THROU PATH OF DIFFUSERS. 14. FIELD VERIFY THE ACTUAL LOCATIONS AND EXACT DIMENSIONS OF ALL EQUIPMENT, CASEWORK, DEVICES, FIXTURES, SWITCHES, SENSORS, STRUCTURAL ELEMENTS, ETC. DURING FIELD VISITS AND PRIOR TO PERFORMING ANY ROUGH-IN WORK FOR DUCTWORK, PIPING AND OTHER AND UTILITIES/SCOPE. MINOR CHANGES TO EQUIPMENT LOCATIONS OR DUCTWORK AND PIPING ROUTING AND DUCTWORK ASPECT RATIO, BASED ON THE FINAL COORDINATION EFFORT, ARE TO BE COMPLETED BY THE CONTRACTOR. REPORT DISCREPANCIES IMMEDIATELY TO ARCHITECT AND/OR ENGINEER. 15. PROVIDE TEMPORARY CONSTRUCTION FILTERS ON ALL RECIRCULATING HVAC EQUIPMENT USED FOR HEATING, COOLING, EXHAUST OR VENTILATION DURING CONSTRUCTION. PROVIDE REGULARLY SCHEDULED FILTER CHANGES DURING CONSTRUCTION. PROVIDE FRESH FILTERS PRIOR TO BALANCING. PRIOR TO TURN OVER TO OWNER, PROVIDE FRESH FILTERS IN ALL EQUIPMENT. 16. EFFECTIVELY PROTECT ALL MATERIALS AND EQUIPMENT FROM DUST, DIRT AND DAMAGE UNTIL FINAL ACCEPTANCE. CLOSE ALL DUCT AND EQUIPMENT OPENINGS DURING CONSTRUCTION WITH SUITABLE PROTECTIVE COVERING BEFORE, DURING AND FOLLOWING INSTALLATION. 17. UNLESS OTHERWISE NOTED, INSTALL DUCTWORK AND PIPING OVERHEAD, TIGHT TO UNDERSIDE OF STRUCTURE OR SLAB, WITH ADEQUATE SPACE FOR INSULATION AND GAP TO PREVENT TRANSMISSION OF VIBRATION TO STRUCTURE. 18. WHERE CONNECTING TO EXISTING DUCTWORK AND PIPING SYSTEMS, INSPECT FOR DEFECTS. NOTIFY OWNER IF EXISTING DUCTWORK, PIPING AND INSULATION IS FOUND TO HAVE DAMAGE/DEFECTS AND TO DETERMINE IF REPLACEMENT IS REQUIRED. 19. MECHANICAL WORK THAT IS TO REMAIN WHEN STRUCTURE ON WHICH IT IS INSTALLED IS TO BE MODIFIED OR REMOVED SHALL BE PROPERLY SUBMITTED IN PLACE UNTIL WORK OF ALL TRADES IS COMPLETED. REINSTALL MECHANICAL WORK ON NEW STRUCTURE. 20. ALL MATERIALS AND EQUIPMENT INSTALLED IN RETURN AIR PLENUMS SHALL BE NON-COMBUSTIBLE AND UL APPROVED FOR USE IN A RETURN AIR PLENUM SPACE. ALL WIRING SHALL BE NON-COMBUSTIBLE OR SHALL BE ENCLOSED IN METAL CONDUIT OR PROTECTED BY A SHEET METAL COVER SECURED WITH METAL FASTENERS. 21. PROVIDE ALL OFFSETS, FITTINGS, DOUBLE ELBOWS, RISES, DROPS, DUCTWORK, PIPING, INSULATION AND ALL DUCTWORK OR PIPING AROUND EXISTING CONDITIONS. DUCTWORK, PIPING, EXISTING STEEL, NEW CONSTRUCTION AND ALL OTHER TRADE WORK. COORDINATE WORK WITH ALL OTHER WORK AND ALL OTHER TRADE CONTRACTORS TO VERIFY LOCATIONS REQUIRING CHANGES IN ELEVATION. 22. VERIFY ALL EQUIPMENT CONNECTIONS WITH MANUFACTURER'S CERTIFIED DRAWINGS. VERIFY AND PROVIDE DUCT AND PIPE TRANSITIONS TO FURNISHED EQUIPMENT. FIELD VERIFY AND COORDINATE ALL DIMENSIONS BEFORE FABRICATION. 23. INSTALL PIPING SUCH THAT ALL VALVES, STRAINERS, UNIONS, TRAPS, AND OTHER ACCESSORIES ARE ACCESSIBLE. 24. PROVIDE ACCESS PANELS AS REQUIRED FOR ALL VALVES, DAMPERS, CONTROLS, OR OTHER EQUIPMENT. PROVIDE ACCESS PANELS IN NON-FRAY-IN-CEILING FOR SERVICE AND MAINTENANCE OF ALL CONCEALED EQUIPMENT AND DEVICES, SUCH AS HEAT PUMPS, ELECTRIC DUCT HEATERS, COILS, SMOKE DETECTORS, BALANCING DAMPERS AND FIRE DAMPERS. 25. [CLEAN EXISTING AND RELOCATED AIR DEVICES THOROUGHLY WITH WARM SOAPY WATER. REPAIR AND RE-PAINT ALL DAMAGED AIR DEVICES TO BE REUSED. CLEAN ALL AIR DEVICES AFTER CONSTRUCTION IS COMPLETED.] 26. CONTRACTOR SHALL NOT CONCEAL ANY WORK UNTIL INSPECTED BY MECHANICAL INSPECTOR AND/OR ARCHITECT/ENGINEER. CONTRACTOR SHALL NOTIFY A/E OF A SCHEDULED INSPECTION TIME WITHIN 72 HOURS. GENERAL CONTRACTOR SHALL NOT CONCEAL WORK UNTIL APPROVED, REGARDLESS OF SCHEDULE. 27. REMOVE ALL TRASH, DEBRIS AND DEMOLITION MATERIAL FROM PREMISES AT THE END OF EACH DAY. 28. PROVIDE ALL ROOFING OPENINGS, FLASHING, CURBS, COUNTER FLASHING, ETC. REQUIRED FOR THE INSTALLATION OF ROOF MOUNTED EQUIPMENT OR CURBS. COORDINATE OPENING WITH ROOFING CONTRACTOR AND CM/SG. ALL ROOFING WORK SHALL BE PERFORMED BY AUTHORIZED ROOFING CONTRACTOR TO MAINTAIN ROOF WARRANTY. 29. ALL DUCT DIMENSIONS ARE INSIDE CIRCLE DIMENSIONS. 30. SHEET/METAL FITTINGS SHOWN SHALL BE PROVIDED. NO SUBSTITUTES WILL BE ALLOWED WITHOUT PRIOR CONSENT FROM ENGINEER. 31. PROVIDE BALANCING DAMPERS IN ALL DUCT BRANCHES AND TO AIR DEVICES. 32. PROVIDE COMBINATION FIRE/SMOKE DAMPERS AND SMOKE DAMPERS IN DUCTS PASSING THROUGH FIRE OR SMOKE RATED ASSEMBLIES AS INDICATED ON THE ARCHITECTURAL DRAWINGS. 33. DUCTWORK SHALL NOT BE ROUTED ABOVE ELECTRICAL PANELS. COORDINATE WITH ELECTRICAL CONTRACTOR. DUCTWORK SHALL NOT COVER OR LIMIT ACCESS TO EXISTING CABOES. 34. PROVIDE HEAVY DUTY FLEXIBLE CONNECTIONS AT ALL FANS INLET AND OUTLET CONNECTIONS.	36. PROVIDE ACOUSTICALLY LINED DUCTWORK: 16 FEET DOWNSTREAM OF ALL FANS, FAN COIL UNITS, FAN POWERED BOXES AND VAV BOXES. [PROVIDE DOUBLE WALLED DUCTWORK 20 FEET DOWNSTREAM OF ALL AIR HANDLING UNITS.] 37. MECHANICAL CONTRACTOR SHALL BLANK OFF ALL UNUSED SECTIONS OF LOUVER AREA WITH 16 GAUGE GALVANIZED STEEL PANELS AND INSULATE WITH 1" THICK FIBERGLASS BOARD INSULATION.] 38. [PROVIDE MINIMUM 2" HIGH DRAIN IN EACH OUTSIDE AIR INTAKE PLENUM. PITCH BOTTOM OF PLENUM TOWARDS DRAIN. ROUTE DRAIN TO NEAREST FLOOR DRAIN.] 39. ALL OPEN-ENDED DUCTS IN CEILING PLENUMS OR EXPOSED SHALL BE UNINSTRUCTED FOR A MINIMUM DISTANCE OF 24 INCHES FROM THE OPENING TO ALLOW FREE FLOW OF AIR. UNLESS OTHERWISE NOTED, EACH OPENING SHALL TERMINATE WITH 1/2" WIRE MESH SCREEN. 40. LOCATE CEILING DIFFUSERS, GRILLES AND REGISTERS AS SHOWN ON THE ARCHITECTURAL REFLECTED CEILING PLANS. 41. UNLESS OTHERWISE NOTED, ALL HYDRONIC PIPING RUNOUTS AND CONDENSATE DRAIN PIPING SHALL BE 1/2" ALL STEAM AND STEAM CONDENSATE PIPING RUNOUTS SHALL BE 1/2". 42. PROVIDE ISOLATION VALVES AT EACH FLOOR TAKEOFF AND EACH TERMINAL EQUIPMENT FOR HYDRONIC, STEAM AND STEAM CONDENSATE PIPING. PROVIDE SHUTOFF VALVE ON HYDRONIC SUPPLY, STEAM AND STEAM CONDENSATE PIPING. PROVIDE COMBINATION BALANCING AND SHUTOFF VALVE ON HYDRONIC RETURN PIPING. 43. [PRIOR TO OPENING NATURAL GAS PIPING SYSTEM, THE ENTIRE SECTION OF NATURAL GAS PIPING SYSTEM AFFECTED BY SCOPE SHALL BE ISOLATED AND PURGED IN ACCORDANCE WITH THE APPLICABLE FUEL GAS CODE. UPON COMPLETION OF NATURAL GAS PIPING SYSTEM SCOPE WORK, PLACE SYSTEM INTO OPERATION IN ACCORDANCE WITH APPLICABLE FUEL GAS CODE.] 44. CONTRACTOR SHALL PROVIDE FIRE STOPPING WHERE EQUIPMENT, DUCTWORK AND PIPING PENETRATE FIRE AND SMOKE RATED BARRIERS/PARTITIONS. INSTALL FIRE STOPPING IN ACCORDANCE WITH UL RATED ASSEMBLY REQUIREMENTS AFTER EQUIPMENT, DUCTWORK AND PIPING HAVE BEEN INSTALLED. 45. PROVIDE ALL MISCELLANEOUS STEEL, THREADED RODS, REINFORCEMENT, VIBRATION ISOLATORS, TURNBUCKLES, ETC. TO SUPPORT MECHANICAL EQUIPMENT ON OR FROM BUILDING STRUCTURE. ALL SUPPORTS AND ASSOCIATED ANCHORS SHALL BE SIZED BASED ON THE WEIGHT OF THE RESPECTIVE EQUIPMENT BEING SUPPORTED. 46. SUPPORT ALL EQUIPMENT, PIPING AND DUCTWORK FROM BUILDING STRUCTURE TO PROVIDE A VIBRATION FREE INSTALLATION. OTHERWISE ADHERE TO THE DETAILS IN THE CONTRACT DOCUMENTS. NOTIFY ARCHITECT AND/OR STRUCTURAL ENGINEER OF ALL WEIGHTS AND METHODS OF SUPPORT. PROVIDE DETAILS TO COORDINATE CONCRETE PADS AND STEEL PLATFORMS REQUIRED FOR MECHANICAL WORK. 47. PROVIDE VIBRATION ISOLATION FOR ROTATING, REVOLVING OR RECIPROCATING EQUIPMENT, INCLUDING DUCTWORK CONNECTIONS TO THE EQUIPMENT TO PREVENT TRANSMISSION OF NOISE AND VIBRATION TO BUILDING STRUCTURE AND OCCUPIED SPACES. VIBRATION ISOLATION DEVICES SHALL INCLUDE SPRING, VIBRATION ISOLATORS, NEOPRENE PADDING AND DUCT PIPE FLEXIBLE CONNECTIONS. 48. CONTROL WIRE AND CONDUIT SHALL COMPLY WITH NEC, INTERNATIONAL BUILDING CODES AND ELECTRICAL SPECIFICATIONS. PLENUM RATED CABLE SHALL BE PROVIDED IN ALL PLENUM CEILING. CONTRACTOR TO COORDINATE LOCATION OF ALL PLENUM CEILING. 49. ALL WALL MOUNTED CONTROL DEVICES SHOWN ON DRAWINGS ARE DIAGRAMMATIC IN LOCATION AND SHOWN FOR GENERAL WIRING PURPOSES ONLY. ALL DEVICES SHALL BE MOUNTED 4" ABOVE FINISHED FLOOR. DEVICES INDICATED TO BE INSTALLED IN THE SAME LOCATIONS WITH DIFFERENT ELEVATIONS SHALL BE ALIGNED VERTICALLY AND HORIZONTALLY. REFER TO ARCHITECTURAL DRAWINGS FOR MOUNTING DETAILS OF SWITCHES, OUTLETS, FIRE ALARM STROBES, AUDIBLE AND VISUAL DEVICES, FIRE ALARM PULL STATION, CLOCKS, SECURITY DEVICES, CARD READERS, THERMOSTATS, SENSORS, ETC. COORDINATE FINAL LOCATIONS WITH EQUIPMENT, FURNITURE, TENANT, AND ARCHITECT PRIOR TO INSTALLATION. 50. REMOVE TEMPORARY AIR FILTERS AND PROVIDE NEW FILTERS IN ALL AIR CONDITIONING EQUIPMENT WITHIN THE SCOPE OF WORK UPON COMPLETION OF CONSTRUCTION AND BEFORE BALANCING.

© COPYRIGHT 2021 DRUMMEY ROSANE ANDERSON, INC.

DRA

Drummeey Rosane Anderson, Inc.

225 Oakland Road
Studio 205
South Windsor, CT
06074

260 Charles Street
Studio 300
Waltham, MA
02453

Planning | Architecture | Interior Design

Tel: 817.984.1702
www.dra-inc.com

Northeast
Metropolitan
Regional
Vocational High
School
Wakefield, MA 01880

BALA
ENGINEERS

BALA CONSULTING ENGINEERS, INC.
200 WILSON ST., SUITE 200
WILSON, MA 01890
TEL: 978-255-1400 FAX: 978-255-1405
WWW.BALA-ENG.COM

REGISTERED PROFESSIONAL ENGINEERS
MECHANICAL, ELECTRICAL, PLUMBING, AND HVAC
LICENSE NO. 00000000000000000000000000000000

MSBA 60% CD
SUBMISSION
January 13, 2023

PROJECT NORTH

MAGNETIC NORTH

MECHANICAL
GENERAL
NOTES

Scale: 1/2" = 1'-0"
Job No.: 20022
Drawn By: DRA
Date: January 13, 2023

M0-0-2

MECHANICAL SCOPE OF WORK	
SCOPE OF WORK	SCOPE OF WORK INCLUDED BUT NOT SHOWN, OR UNRESOLVED ISSUES
GENERAL: DESIGN AND INSTALLATION OF THE MECHANICAL SYSTEMS SHALL BE GOVERNED BY AND COMPLY WITH THE REQUIREMENTS OF THE MASSACHUSETTS STATE BUILDING CODE 9TH EDITION, 2020 MASSACHUSETTS ENERGY CODE, LEED RATING SYSTEM, AMERICANS WITH DISABILITIES ACT (ADA), AND ALL LOCAL LAWS HAVING JURISDICTION. REFER TO ARCHITECTURAL DRAWING'S CODE COMPLIANCE SHEETS FOR ALL APPLICABLE CODES.	
AIR HANDLING UNITS (ROOFTOP AND INDOOR): 1. REFER TO PLANS, NARRATIVE, AND SPECIFICATIONS FOR AIR HANDLING UNIT REQUIREMENTS AND LOCATIONS.	1. RETURN AIR DUCT SMOKE DETECTORS REMAIN TO BE INDICATED ON PLANS AND WILL BE INCLUDED FOR EACH AIR HANDLING UNIT IN A FUTURE SUBMISSION. 2. DUCT STATIC PRESSURE SENSORS REMAIN TO BE INDICATED ON THE PLANS FOR MULTI-ZONE VAV AIR HANDLING UNITS AND WILL BE INCLUDED FOR EACH MULTI-ZONE AIRHANDLING UNIT IN A FUTURE SUBMISSION.
TERMINAL UNITS: 1. REFER TO PLANS, NARRATIVE, AND SPECIFICATIONS FOR TERMINAL UNIT REQUIREMENTS AND LOCATIONS.	1. EACH VRF FAN COIL UNIT AND SPLIT AC UNIT SHALL BE PROVIDED WITH MANUFACTURER'S WIRED THERMOSTAT/CONTROLLER. ALL THERMOSTATS HAVE YET TO BE INDICATED ON THE FLOOR PLANS. ALL THERMOSTATS WILL BE INDICATED ON THE PALNS IN THE NEXT SUBMISSION. 2. EACH SUPPLY VAV TERMINAL UNIT SERVING SPACES SERVED BY VRF FAN COIL UNITS SHALL BE PROVIDED WITH A DDC SPACE CO2 SENSOR FOR VENTILATION AIRFLOW CONTROL. ALL CO2 SENSORS HAVE YET TO BE INDICATED ON THE FLOOR PLANS. ALL CO2 SENSORS WILL BE INDICATED ON THE PLANS IN THE NEXT SUBMISSION. 3. EACH SUPPLY VAV TERMINAL UNIT SERVICE SPACES NOT ALSO SERVED BY VRF FAN COIL UNITS SHALL BE PROVIDED WITH A DDC SPACE CO2 AND TEMPERATURE SENSOR.
PIPING: 1. REFRIGERANT PIPING SHALL BE PROVIDED BEWTEEN INDOOR AND OUTDOOR VRF UNITS AND SPLIT AC UNITS AND BEVTEEN AIR HANDLING UNITS AND THEIR CORRESPONDING CONDENSING UNITS. 2. CONDENSATE DRAIN PIPING SHALL BE PROVIDED FROM EACH INDOOR AIR HANDLER, VRF FAN COIL UNIT, AND SPLIT AC AND ROUTED TO THE NEAREST CONDENSATE RECEPTOR.	1. VRF SYSTEM REFRIGERANT PIPING IS NOT YET SHOWN ON THE FLOOR PLANS. REFER TO VRF DIAGRAMS FOR ESTIMATED REFRIGERANT PIPE LENGTHS AND SIZES FOR THE VRF SYSTEMS. REFRIGERANT PIPING WILL BE SHOWN IN THE 60%CD MSBA SUBMISSION. 2. SPLIT AC REFRIGERANT PIPING IS NOT YET SHOWN ON THE FLOOR PLANS. REFRIGERANT PIPING SHALL BE PROVIDED BETWEEN OUTDOOR UNITS AND THE ASSOCIATED INDOOR UNITS. REFRIGERANT PIPING WILL BE SHOWN IN THE 60%CD MSBA SUBMISSION. 3. CONDENSATE DRAIN PIPING IS INDICATED AT A 60% LEVEL. CONDENSATE DRAIN PIPING SHALL BE PROVIDED FROM ALL VRF FAN COIL UNITS, SPLIT AC UNITS, AND INDOOR AIR HANDLING UNITS TO THE NEAREST CONDENSATE DRAIN PIPE OR RECEPTOR. CONDENSATE PUMPS SHALL BE PROVIDED AT EACH PIECE OF EQUIPMENT. 4. CONDENSATE DRAIN PIPING SHALL BE PROVIED FROM ALL ROOFTOP HRUS AND RTUS TO THE NEAREST ROOF DRAIN.
DUCTWORK: 1. PROVIDE DUCTWORK THROUGHOUT THE BUILDING AS INDICATED ON THE PLANS. REFER TO SPECIFICATIONS FOR REQUIREMENTS.	1. COMBINATION FIRE SMOKE DAMPERS HAVE YET TO BE SHOWN ON THE FLOOR PLANS. PROVIDE AT EACH SHAFT PENETRATION. COMBINATION FIRE SMOKE DAMPERS WILL BE INDICATED IN THE 60%CD MSBA SUBMISSION. 2. VOLUME DAMPERS ARE INDICATED AT A 60% LEVEL. PROVIDE VOLUME DAMPERS ON ALL BRANCH DUCTWORK. 3. SOUND ATTENUATORS REMAIN TO BE SHOWN ON THE DISCHARGE AND INLET OF ALL AIR HANDLING UNITS (HRUS, RTUS, AND AHUS). 5'-0" SOUND ATTENUATORS WILL BE INDICATED IN THE 90%CD PRICING SUBMISSION.
CONTROLS: 1. REFER TO SPECIFICATIONS FOR DDC CONTROL SYSTEM REQUIREMENTS.	1. SENSORS AND CONTROLS ARE HAVE YET TO BE SHOWN THROUGHOUT. EACH SPACE SERVED BY A VRF FAN COIL UNIT SHALL BE PROVIDED WITH A VRF MANUFACTURER TEMPERATURE SENSOR/CONTROLLER AND A DDC CO2 SENSOR. PROVIDE DDC SPACE TEMPERATURE AND CO2 SENSORS IN EACH ZONE FOR SINGLE ZONE AND MULTIZONE AIR HANDLING UNITS. FUTURE SUBMISSIONS WILL INCLUDE ALL SENSORS, SEQUENCES OF OPERATION, AND CONTROL DIAGRAMS. 2. SPECIFIC SEQUENCES FOR VOCATIONAL SHOP AIR HANDLING UNITS AND EQUIPMENT HAVE YET TO BE PROVIDED AND WILL BE PROVIDED IN THE 90% CD SET.




Drumme­y Rosane Anderson, Inc.
225 Oakland Road Studio 205 South Windsor, CT 06074
260 Charles Street Studio 300 Waltham, MA 02453
Tel: 617.984.1700
www.dra­an.com
Planning | Architecture | Interior Design

Northeast Metropolitan Regional Vocational High School

Wakefield, MA 01880



MSBA 60% CD SUBMISSION
January 13, 2023

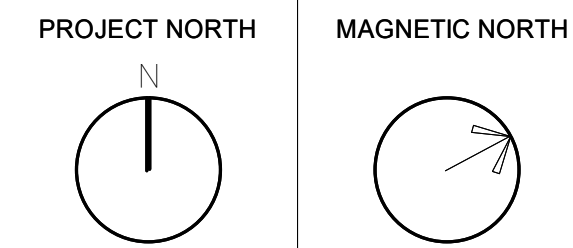

MECHANICAL SCOPE OF WORK

Scale: 1/2" = 1'-0"
Job No.: 20202
Drawn By: DRA
Date: January 13, 2023
M0-0-3

© COPYRIGHT 2021 DRUMMEY ROSANE ANDERSON, INC.

HVAC DRAWING NOTES

1. REFER TO VRF PIPING DIAGRAMS ON THE M2 SERIES DRAWINGS FOR REFRIGERANT PIPING DISTRIBUTION. PROVIDE A CONDENSATE DRAIN FROM THE FAN COIL UNIT TO THE NEAREST CONDENSATE RECEPTOR. CONDENSATE RECEPTOR BY DIV. 22.
2. PROVIDE AN EXHAUST TERMINAL UNIT TO SERVE SPACE(S). PROVIDE AN EXHAUST GRILLE IN SPACE(S) WITH DUCT DISTRIBUTION FROM TERMINAL UNIT. PROVIDE MEDIUM PRESSURE DUCTWORK FROM TERMINAL UNIT TO HRV-4 EXHAUST MAIN.
3. PROVIDE EXHAUST DUCT FROM FAN UP TO GRAVITY EXHAUST VENT ON ROOF. NEAR LOCATED NEAR F-6 EXHAUST DUCT FROM FAN DISCHARGE CONNECTION SHALL BE EQUIVALENT IN SIZE TO DUCT ON INLET SIDE OF FAN.


DRA


Drumme Rosane Anderson, Inc.
225 Oakland Road
Studio 205
South Windsor, CT 06074
Tel: 817.984.1700
www.draan.com

280 Charles Street
Studio 300
Waltham, MA 02453
Planning | Architecture | Interior Design

Northeast
Metropolitan
Regional
Vocational High
School

Wakefield, MA 01880

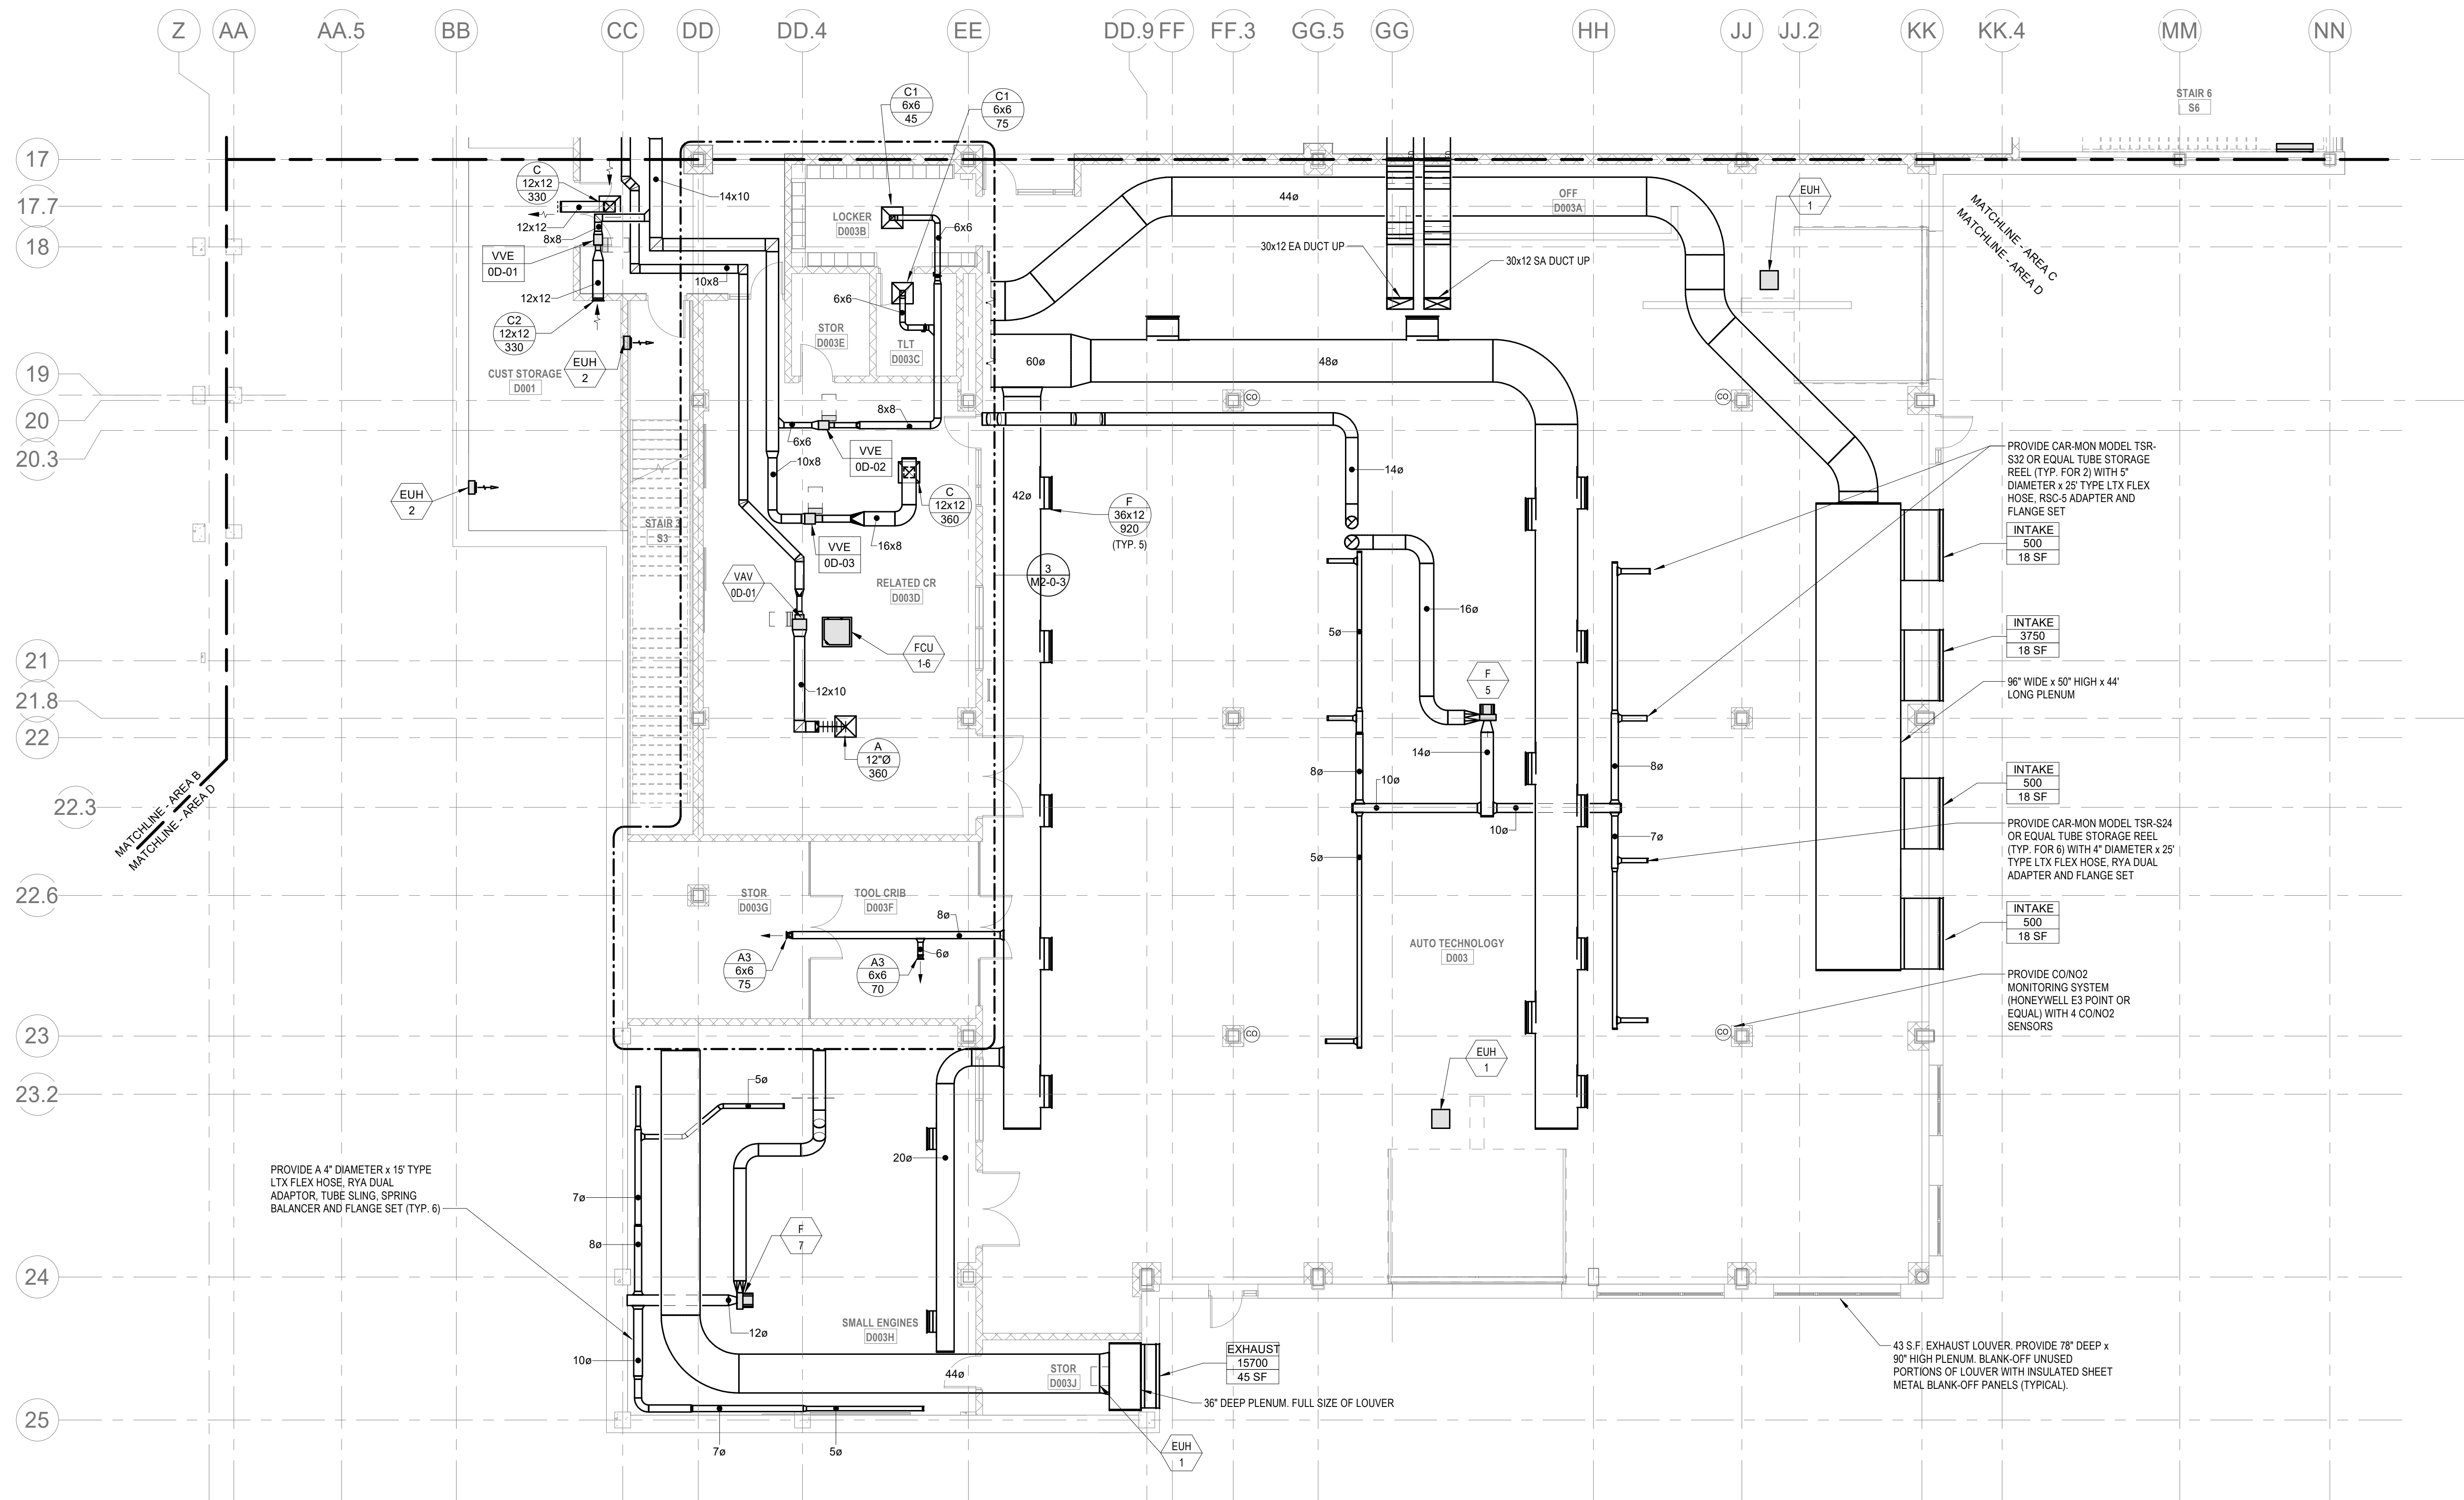

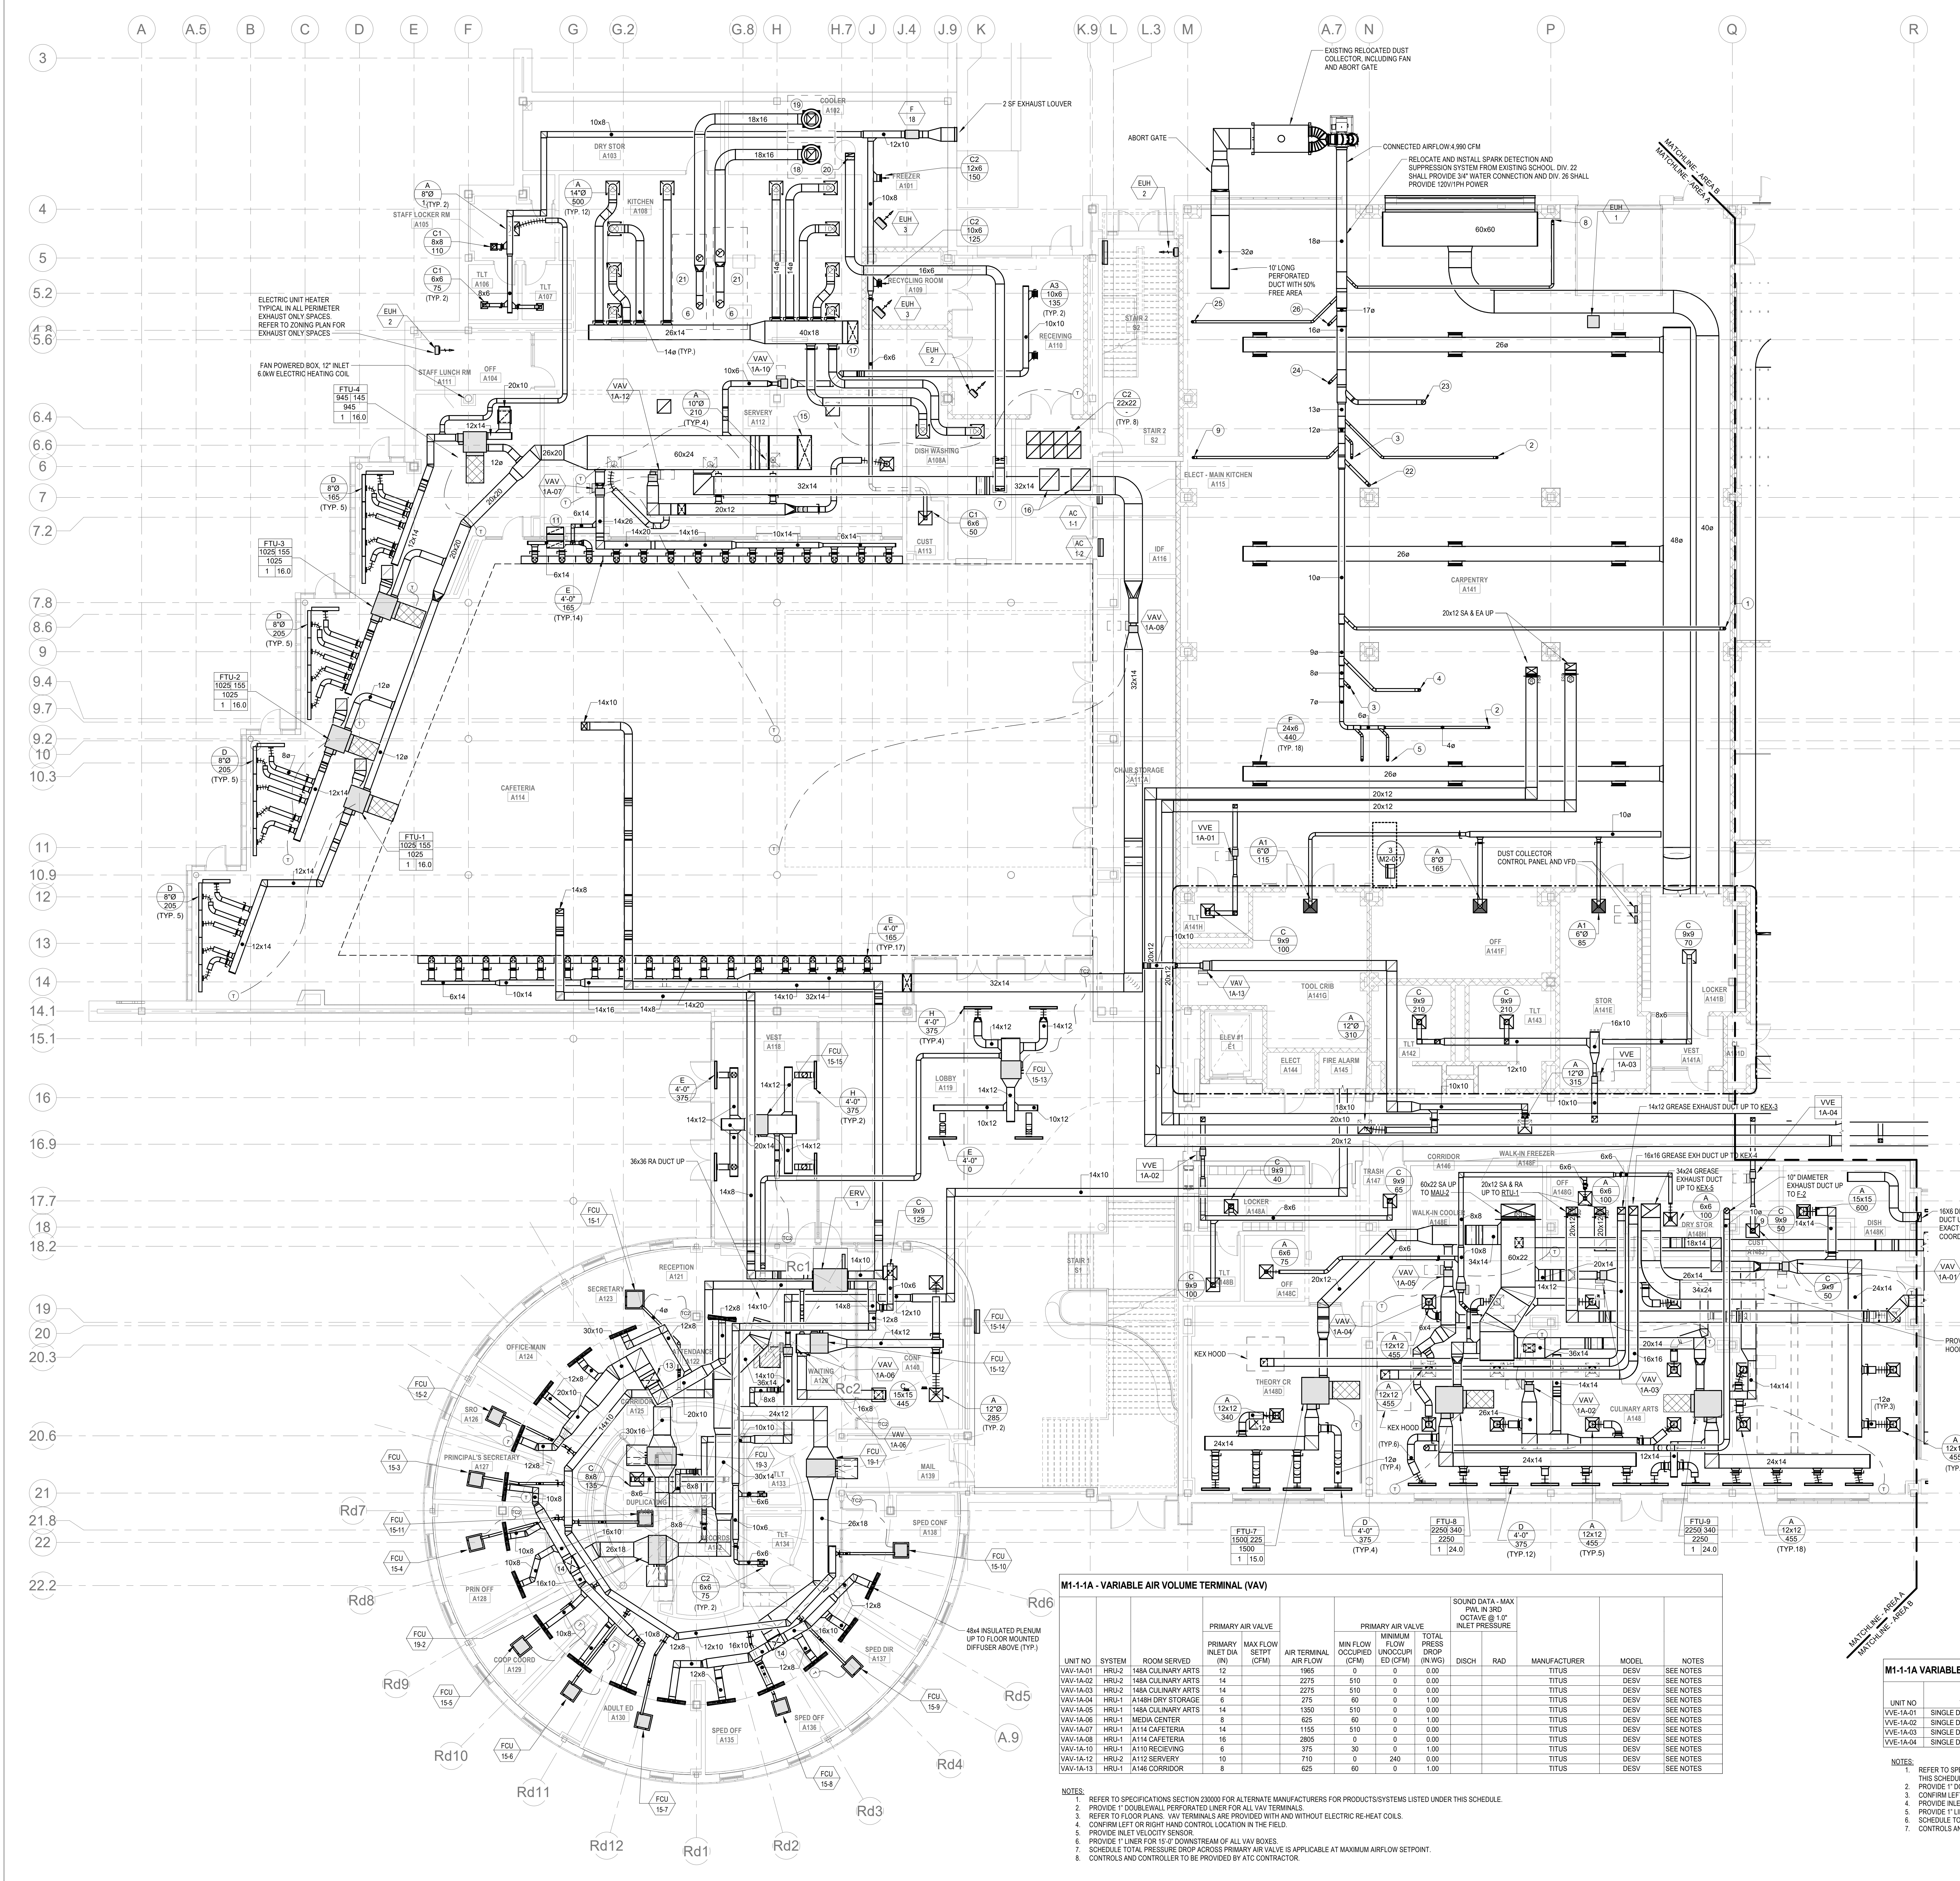

HVAC DRAWING NOTES

- 5" DIAMETER DUCT DOWN TO PANEL SAW (CPM) DUCT CONNECTION (350 CFM). PROVIDE REDUCTION TO 4" DIAMETER DUCT AT CONNECTION TO EQUIPMENT.
- 4" DIAMETER DUCT DOWN TO CABINET SAW (CPM) DUCT CONNECTION (350 CFM).
- 4" DIAMETER DUCT DOWN TO JITTER (CPM) DUCT CONNECTION (350 CFM).
- 5" DIAMETER DUCT DOWN TO TABLE SAW (CPM) DUCT CONNECTION (350 CFM).
- 10" DIAMETER DUCT DOWN TO PLANNER (CPM) DUCT CONNECTION (350 CFM).
- 18" KITCHEN EXHAUST TO KITCHEN EXHAUST HOOD.
- 18" KITCHEN EXHAUST TO DISHWASHER.
- 4" DIAMETER DUCT DOWN TO INVERTED ROUTER (CPM) DUCT CONNECTION (350 CFM).
- 4" DIAMETER DUCTS DOWN TO VERTICAL BAND SAW (CPM) DUCT CONNECTION (350 CFM).
- 42" ACoustically LINED TRANSFER DUCT.
- 30" ACoustically LINED TRANSFER DUCT.
- 12" ACoustically LINED TRANSFER DUCT.
- 30" SA DUCT UP INTO INTERSTITIAL SPACE. PROVIDE FIRE DAMPER IN VERTICAL WHERE DUCT PENETRATES SLAB.
- 26" SA DUCT UP INTO INTERSTITIAL SPACE. PROVIDE FIRE DAMPER IN VERTICAL WHERE DUCT PENETRATES SLAB.
- 60" SA SUPPLY UP TO AHJ-8 ON SECOND FLOOR.
- 36" SA OPENING UP TO AHJ-8 ON SECOND FLOOR. PROVIDE W/ WMS OPENING.
- 40" SA SUPPLY UP TO AHJ-1.
- 18" KITCHEN EXHAUST UP TO KEF-2.
- 18" KITCHEN EXHAUST UP TO KEF-1.
- 16" KITCHEN EXHAUST UP TO F-1 ON THE ROOF.
- KITCHEN EXHAUST HOOD.
- 5" DIAMETER DUCT DOWN TO FLOOR SWEEP (350 CFM).
- 8" DIAMETER DUCT DOWN TO PLANNER (CPM) DUCT CONNECTION (350 CFM).
- 4" DIAMETER DUCT DOWN TO DRUM SANDER (CPM) DUCT CONNECTION (350 CFM).
- 4" DIAMETER DUCT DOWN TO LARGE CNC (CPM) DUCT CONNECTION (350 CFM).
- 4" DIAMETER DUCT DOWN TO OSCILLATING UNIVERSAL EDGE SANDER (CPM) DUCT CONNECTIONS (350 CFM).

DRA

Drummet Rosane Anderson, Inc.

225 Oakland Road
Studio 205
South Windsor, CT 06074

260 Charles Street
Studio 300
Waltham, MA 02453

Planning | Architecture | Interior Design

Tel: 817.984.1702
www.dra.com

Northeast
Metropolitan
Regional
Vocational High
School

Wakefield, MA 01880

MSBA 60% CD
SUBMISSION

January 13, 2023

KEY PLAN

PROJECT NORTH
MAGNETIC NORTH

MECHANICAL
DUCTWORK
FIRST FLOOR
PLAN - AREA A

Scale: 1/8" = 1'-0"

Job No.: 20022

Drawn By: DRA

Date: January 13, 2023

M1-1-1A

M1-1-1A - VARIABLE AIR VOLUME TERMINAL (VAV)									
UNIT NO.	SYSTEM	ROOM SERVED	PRIMARY AIR VALVE		PRIMARY AIR VALVE		SOUND DATA: MAX PWL IN 3RD OCTAVE @ 1' 0" INLET PRESSURE		NOTES
			PRIMARY INLET DIA. (IN)	MAX FLOW SETPOINT (CFM)	AIR TERMINAL AIR FLOW (CFM)	MIN FLOW (CFM)	MINIMUM FLOW (UNOCCUPIED) (CFM)	TOTAL PRESSURE DROP (IN WG)	
VAV-1A-01	HRU-2	148A CULINARY ARTS	12	275	510	0	0.00	0.00	SEE NOTES
VAV-1A-02	HRU-2	148A CULINARY ARTS	14	275	510	0	0.00	0.00	SEE NOTES
VAV-1A-03	HRU-2	148A CULINARY ARTS	14	275	510	0	0.00	0.00	SEE NOTES
VAV-1A-04	HRU-1	1414H DRY STORAGE	6	275	60	0	1.00	0.00	SEE NOTES
VAV-1A-05	HRU-1	148A CULINARY ARTS	14	1350	510	0	0.00	0.00	SEE NOTES
VAV-1A-06	HRU-1	MEDIA CENTER	8	625	60	0	1.00	0.00	SEE NOTES
VAV-1A-07	HRU-1	1414 CAFETERIA	14	1155	510	0	0.00	0.00	SEE NOTES
VAV-1A-08	HRU-1	1414 CAFETERIA	16	2865	0	0	0.00	0.00	SEE NOTES
VAV-1A-10	HRU-1	1410 RECEIVING	6	375	30	0	1.00	0.00	SEE NOTES
VAV-1A-12	HRU-2	1412 RECEPTION	10	710	0	240	0.00	0.00	SEE NOTES
VAV-1A-13	HRU-1	1416H CORRIDOR	8	625	60	0	1.00	0.00	SEE NOTES


NOTES:

- REFER TO SPECIFICATIONS SECTION 230000 FOR ALTERNATE MANUFACTURERS FOR PRODUCTS/SYSTEMS LISTED UNDER THIS SCHEDULE.
- PROVIDE 1" DOUBLER WALL PERFORATED LINER FOR ALL VAV TERMINALS.
- REFER TO FLOOR PLANS. VAV TERMINALS ARE PROVIDED WITH AND WITHOUT ELECTRIC RE-HEAT COILS.
- CONFIRM LEFT OR RIGHT HAND CONTROL LOCATION IN THE FIELD.
- PROVIDE INLET VELOCITY SENSOR.
- PROVIDE 1" LINER FOR 15'-0" DOWNSTREAM OF ALL VAV BOXES.
- SCHEDULE TOTAL PRESSURE DROP ACROSS PRIMARY AIR VALVE IS APPLICABLE AT MAXIMUM AIRFLOW SETPOINT.
- CONTROLS AND CONTROLLER TO BE PROVIDED BY ATC CONTRACTOR.

M1-1-1A VARIABLE AIR VOLUME EXHAUST AIR TERMINAL SCHEDULE (VVE)									
UNIT NO.	TYPE	INLET DIAMETER (IN)	MAX AIRFLOW (CFM)	MIN TURNDOWN (CFM)	MANUFACTURER	MODEL	DESIGN	REMARKS	
VVE-1A-01	SINGLE DUCT EXHAUST	6	15	15	TITUS	DESIGN	SEE NOTES		
VVE-1A-02	SINGLE DUCT EXHAUST	6	205	205	TITUS	DESIGN	SEE NOTES		
VVE-1A-03	SINGLE DUCT EXHAUST	6	480	480	TITUS	DESIGN	SEE NOTES		
VVE-1A-04	SINGLE DUCT EXHAUST	6	50	50	TITUS	DESIGN	SEE NOTES		

NOTES:

- REFER TO SPECIFICATIONS SECTION 230000 FOR ALTERNATE MANUFACTURERS FOR PRODUCTS/SYSTEMS LISTED UNDER THIS SCHEDULE.
- PROVIDE 1 DOUBLER WALL PERFORATED LINER FOR ALL VAV TERMINALS.
- CONFIRM LEFT OR RIGHT HAND CONTROL LOCATION IN THE FIELD.
- PROVIDE INLET VELOCITY SENSOR.
- PROVIDE 1" LINER FOR 15'-0" DOWNSTREAM OF ALL VAV BOXES.
- SCHEDULE TOTAL PRESSURE DROP ACROSS PRIMARY AIR VALVE IS APPLICABLE AT MAXIMUM AIRFLOW SETPOINT.
- CONTROLS AND CONTROLLER TO BE PROVIDED BY ATC CONTRACTOR.

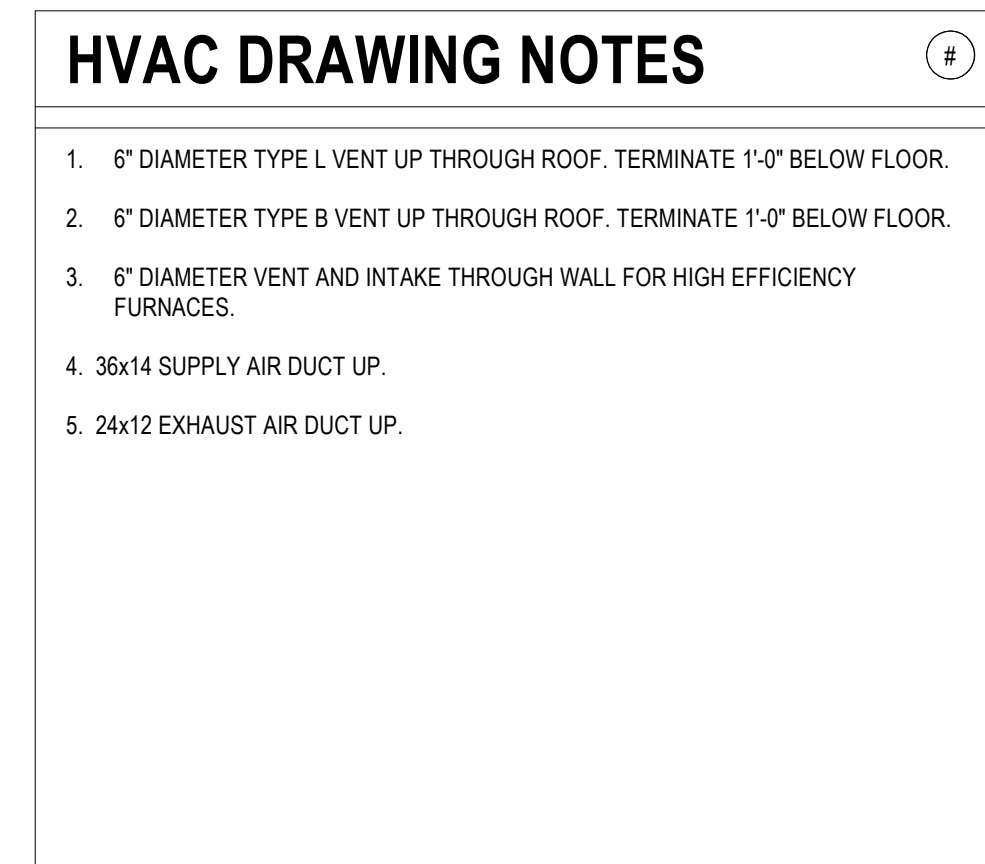

**Northeast
Metropolitan
Regional
Vocational High
School**

Wakefield, MA 01880

Scale: 1/8" = 1'-0"
Job No.: 20202
Drawn By: DRA
Date: January 13, 2023


M1-1-B - VARIABLE AIR VOLUME SUPPLY TERMINAL (VAV)										SOUND DATA - MAX PWL IN 3RD OCTAVE @ 10" INLET PRESSURE			
			PRIMARY AIR VALVE	AIR TERMINAL FLOW	PRIMARY AIR VALVE								
UNIT NO	SYSTEM	ROOM SERVED	PRIMARY INLET DIA (IN)	MIN FLOW OCCUPIED (CFM)	MINIMUM FLOW UNOCCUPIED (CFM)	TOTAL PRESS DROP (IN WG)	DISCH	RAD	MANUFACTURER	MODEL	NOTES		
VAV-19-01	HRU-1	A1HIC RELATED CR	6	180	30	0	1.00		TITUS	DESV	SEE NOTES		
VAV-19-03	HRU-1	B10IE RELATED CR	8	375	60	0	1.00		TITUS	DESV	SEE NOTES		
VAV-19-05	HRU-1	B10IE RELATED CR	8	375	60	0	1.00		TITUS	DESV	SEE NOTES		
VAV-19-07	HRU-1	B10IE RELATED CR	8	400	60	0	1.00		TITUS	DESV	SEE NOTES		
VAV-19-11	HRU-1	B10IE RELATED CR	6	375	30	0	1.00		TITUS	DESV	SEE NOTES		
VAV-19-13	HRU-1	B10IE RELATED CR	6	210	30	0	1.00		TITUS	DESV	SEE NOTES		
VAV-19-14	HRU-1	B10IE RELATED CR	8	455	60	0	1.00		TITUS	DESV	SEE NOTES		
VAV-19-20	HRU-1	B10IE RELATED CR	8	375	60	0	1.00		TITUS	DESV	SEE NOTES		

NOTES:

- REFER TO SPECIFICATIONS SECTION 230000 FOR ALTERNATE MANUFACTURERS FOR PRODUCTS/SYSTEMS LISTED UNDER THIS SCHEDULE.
- PROVIDE 1" MINIMUM REPORTED LINEUP FOR ALL VAV TERMINALS.
- REFER TO FLOOR PLANS. VAV TERMINALS ARE PROVIDED WITH AND WITHOUT ELECTRIC RE-HEAT COILS.
- CONFIRM LEFT OR RIGHT HAND CONTROL LOCATION IN THE FIELD.
- PROVIDE INLET VELOCITY SENSOR.
- PROVIDE 1" LINEUP FOR 15' DOWNSTREAM OF ALL VAV BOXES.
- SCHEDULE 40 PRESSURE DROP ACROSS PRIMARY AIR VALVE IS APPLICABLE AT MAXIMUM AIRFLOW SETPOINT.
- CONTROLS AND CONTROLLER TO BE PROVIDED BY A/C CONTRACTOR.

HVAC DRAWING NOTES



1.

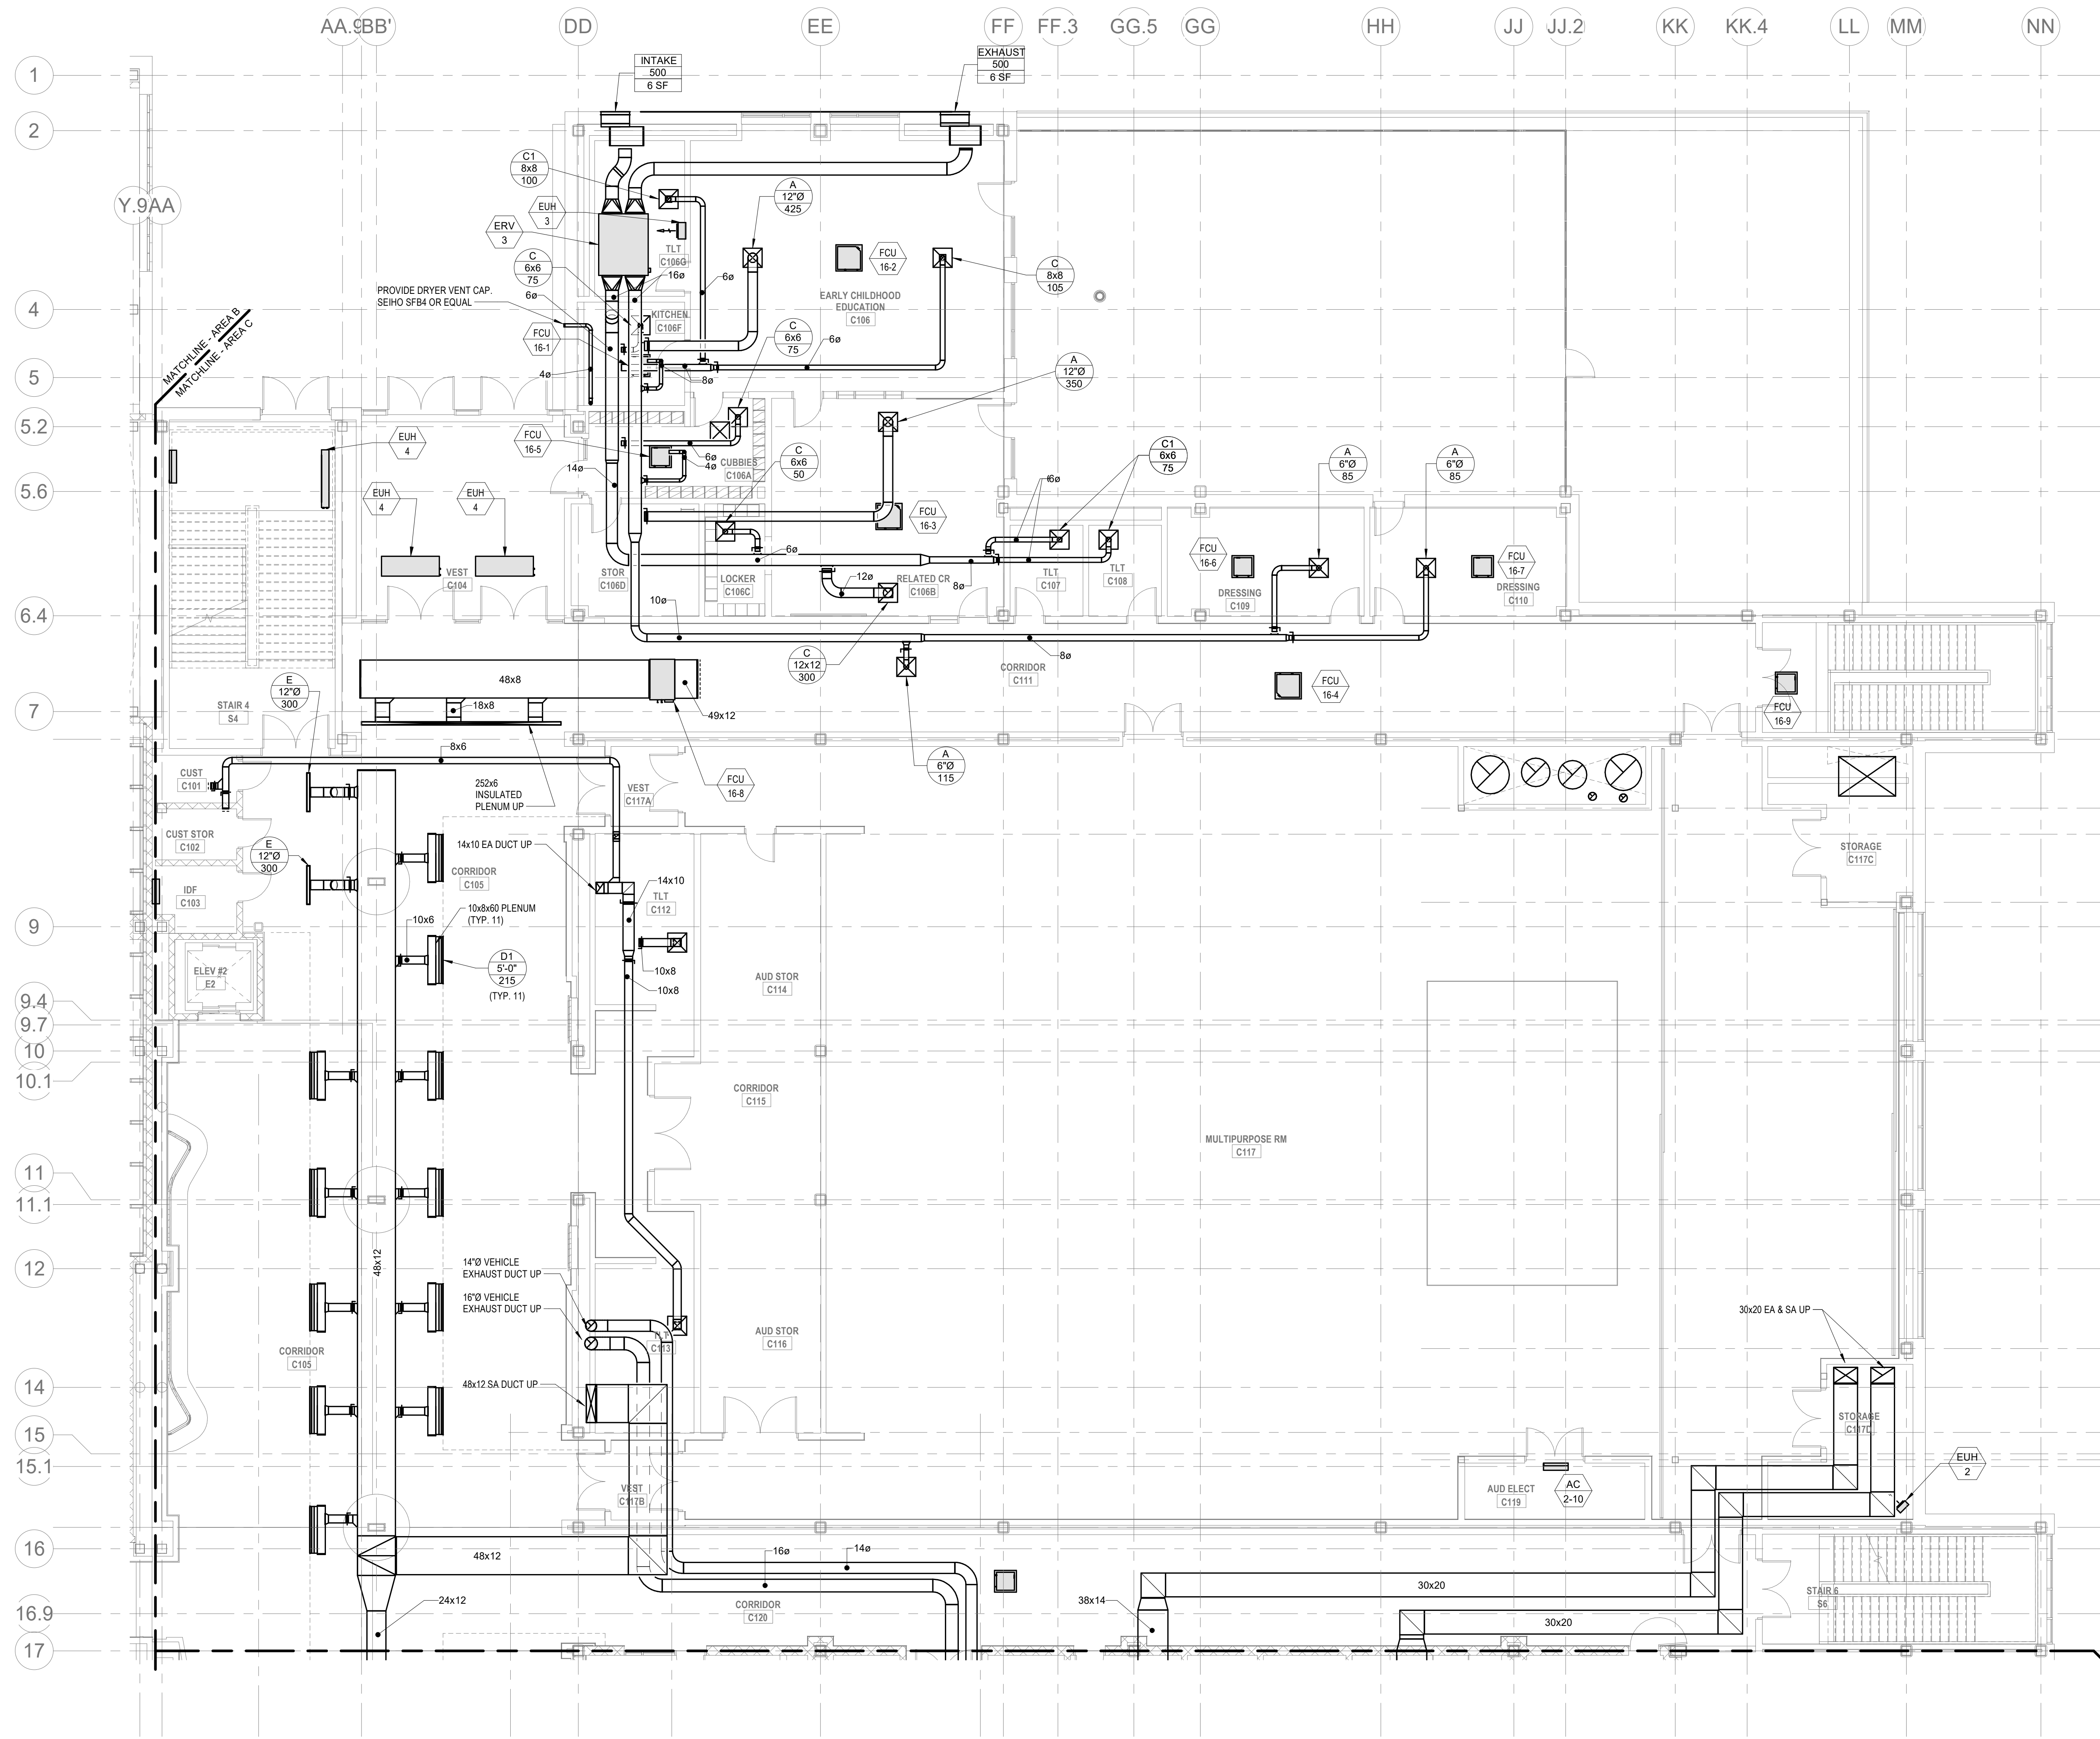

© COPYRIGHT 2021 DRUMMEY ROSANE ANDERSON, INC.

BALA
ENGINEERS
BALA CONSULTING ENGINEERS, INC.
300 WILSON ST. SUITE 200
WILSON, MA 01890
TEL: 978-261-1111 FAX: 978-261-1112
WWW.BALA-ENG.COM

MSBA 60% CD
SUBMISSION
January 13, 2023

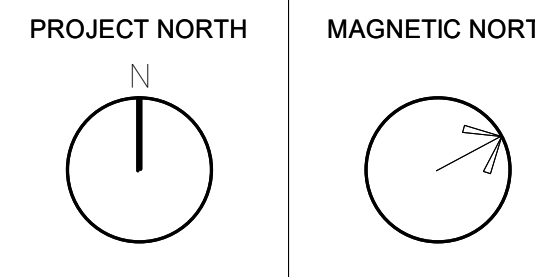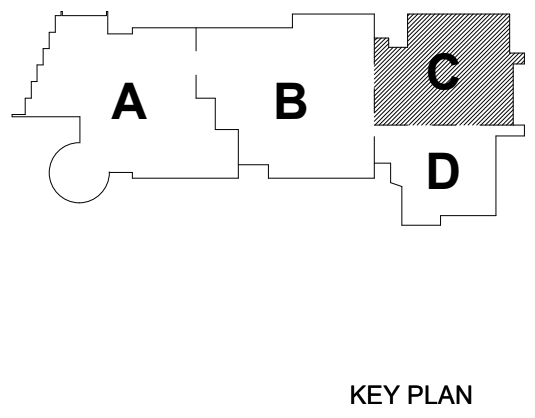

**MECHANICAL
DUCTWORK
FIRST FLOOR
PLAN - AREA C**

Scale: 1/8" = 1'-0"
Job No.: 20202
Drawn By: DRA
Date: January 13, 2023

M1-1-1C

④

- DRA**
- Drummezy Rosane Anderson, Inc.**
- | | |
|-------------------|--------------------|
| 225 Oakland Road | 260 Charles Street |
| Studio 205 | Studio 300 |
| South Windsor, CT | Walham, MA |
| 06074 | 02453 |
- Planning | Architecture | Interior Design**
- Tel: 617.964.1700
www.drausa.com


Wakefield, MA 01880



M1-1-1D

NOTES:

1. REFER TO SPECIFICATIONS SECTION 230000 FOR ALTERNATE MANUFACTURERS FOR PRODUCTS/SYSTEMS LISTED UNDER THIS SCHEDULE.
2. PROVIDE 1" DOUBLEWALL PERFORATED LINER FOR ALL VAV TERMINALS.
3. REFER TO FLOOR PLANS. VAV TERMINALS ARE PROVIDED WITH AND WITHOUT ELECTRIC RE-HEAT COILS.
4. CONFIRM LEFT OR RIGHT HAND CONTROL LOCATION IN THE FIELD.
5. PROVIDE INLET VELOCITY SENSOR.
6. PROVIDE 1" LINER FOR 15'-0" DOWNSTREAM OF ALL VAV BOXES.
7. SCHEDULE TOTAL PRESSURE DROP ACROSS PRIMARY AIR VALVE IS APPLICABLE AT MAXIMUM AIRFLOW SETPOINT.
8. CONTROLS AND CONTROLLER TO BE PROVIDED BY ATC CONTRACTOR.

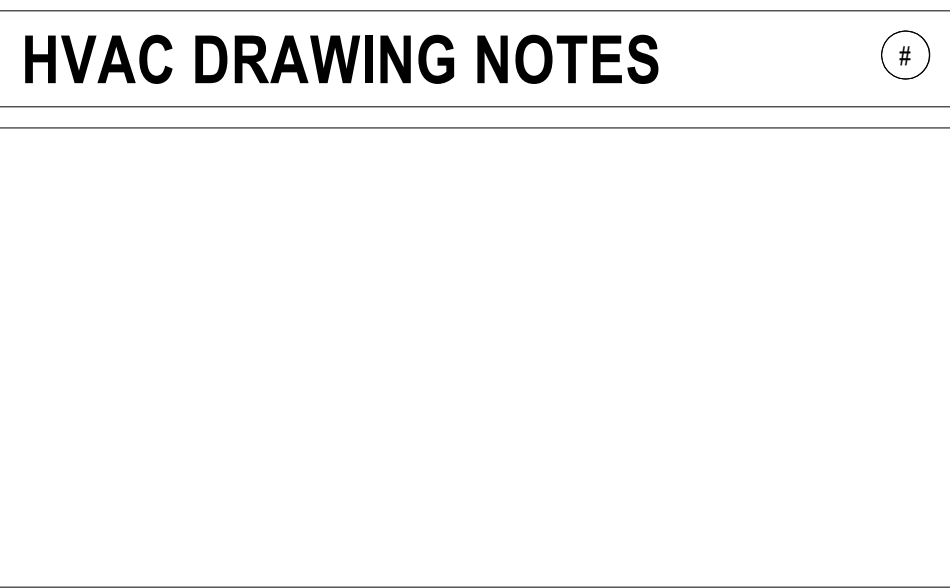

**Northeast
Metropolitan
Regional
Vocational High
School**

Wakefield, MA 01880

M1-1-2A VARIABLE AIR VOLUME EXHAUST AIR TERMINAL SCHEDULE (VE)							
UNIT NO	TYPE	INLET DIAMETER (IN)	MAX AIRFLOW (CFM)	MIN TURNDOWN (IN)	MANUFACTURER	MODEL	REMARKS
VE-2A-01	SINGLE DUCT EXHAUST	6	0	125	TIUS	DESV	
VE-2A-02	SINGLE DUCT EXHAUST	6	0	125	TIUS	DESV	
VE-2A-03	SINGLE DUCT EXHAUST	6	0	125	TIUS	DESV	
VE-2A-04	SINGLE DUCT EXHAUST	6	370	370	TIUS	DESV	
VE-2A-05	SINGLE DUCT EXHAUST	6	370	370	TIUS	DESV	
VE-2A-06	SINGLE DUCT EXHAUST	6	380	380	TIUS	DESV	
VE-2A-07	SINGLE DUCT EXHAUST	12	1500	1500	TIUS	DESV	
VE-2A-08	SINGLE DUCT EXHAUST	12	1500	1500	TIUS	DESV	
VE-2A-09	SINGLE DUCT EXHAUST	10	0	240	TIUS	DESV	
VE-2A-10	SINGLE DUCT EXHAUST	10	0	240	TIUS	DESV	
VE-2A-11	SINGLE DUCT EXHAUST	10	0	400	TIUS	DESV	
VE-2A-12	SINGLE DUCT EXHAUST	6	0	30	TIUS	DESV	
VE-2A-13	SINGLE DUCT EXHAUST	6	0	30	TIUS	DESV	
VE-2A-14	SINGLE DUCT EXHAUST	6	0	30	TIUS	DESV	

NOTES

1. REFER TO SPECIFICATIONS SECTION 230000 FOR ALTERNATE MANUFACTURERS FOR PRODUCTS/SYSTEMS LISTED UNDER THIS SCHEDULE.
2. PROVIDE 1" DOUBLEWALL PERFORATED LINER FOR ALL VAV TERMINALS.
3. CONFIRM LEFT OR RIGHT HAND CONTROL LOCATION IN THE FIELD.
4. PROVIDE INLET VACUITY SENSOR.
5. PROVIDE 1" LINER FOR 15'-0" DOWNSTREAM OF ALL VAV BOXES.
6. SCHEDULE TOTAL PRESSURE DROP ACROSS PRIMARY AIR VALVE IS APPLICABLE AT MAXIMUM AIRFLOW SETPOINT.
7. CONTROLS AND CONTROLLER TO BE PROVIDED BY ACT CONTRACTOR.

KEY PLAN

PROJECT NORTH	MAGNETIC NORTH
100°	100°
110°	110°
120°	120°
130°	130°
140°	140°
150°	150°
160°	160°
170°	170°
180°	180°
190°	190°
200°	200°
210°	210°
220°	220°
230°	230°
240°	240°
250°	250°
260°	260°
270°	270°
280°	280°
290°	290°
300°	300°
310°	310°
320°	320°
330°	330°
340°	340°
350°	350°
360°	360°

**MECHANICAL
DUCTWORK
SECOND FLOOR
PLAN - AREA A**

Scale: 1/8" = 1'-0"
 Job No.: 20202
 Drawn By: DRA
 Date: January 13, 2023

M1-1-2A

M1-1-2B - VARIABLE AIR VOLUME TERMINAL (VAV)

UNIT NO	SYSTEM	ROOM SERVED	PRIMARY AIR VALVE INLET (IN) / FLOW	Air Terminal Flow	MIN FLOW OCCUPIED (CFM)	MINIMUM FLOW (UNOCCUPIED) (CFM)	TOTAL PRESS (IN WG)	DISCH	RAD	MANUFACTURER	MODEL	NOTES
VAV-2B-01	HRU-2	B234B HUDDLE	8	370	125	0	0.00			TITUS	DESV	SEE NOTES
VAV-2B-02	HRU-2	B230 COLLAB	8	200	0	0	0.00					
VAV-2B-03	HRU-2	B234A TEACHERS PLAN	4	200	35	35	1.00			TITUS	DESV	SEE NOTES
VAV-2B-04	HRU-2	B234B HUDDLE	4	35	35	35	1.00			TITUS	DESV	SEE NOTES
VAV-2B-05	HRU-2	B225 CR	8	370	125	0	1.00			TITUS	DESV	SEE NOTES
VAV-2B-06	HRU-2	B238 CR	8	370	125	0	1.00			TITUS	DESV	SEE NOTES
VAV-2B-07	HRU-2	B237 CR	8	370	125	0	1.00			TITUS	DESV	SEE NOTES
VAV-2B-08	HRU-2	B238 CR	8	370	125	0	1.00			TITUS	DESV	SEE NOTES
VAV-2B-09	HRU-2	B238 CR	8	370	125	0	1.00			TITUS	DESV	SEE NOTES
VAV-2B-10	HRU-2	B213 SPED	8	370	125	0	1.00			TITUS	DESV	SEE NOTES
VAV-2B-11	HRU-2	B212 CR	8	370	125	0	0.00			TITUS	DESV	SEE NOTES
VAV-2B-12	HRU-2	B211 CR	8	370	125	0	0.00			TITUS	DESV	SEE NOTES
VAV-2B-13	HRU-2	B215 SPED	4	160	35	160	1.00			TITUS	DESV	SEE NOTES
VAV-2B-14	HRU-2	B216 SUSPEN	4	140	35	140	1.00			TITUS	DESV	SEE NOTES
VAV-2B-15	HRU-2	A307 SPED	6	210	0	0	0.00			TITUS	DESV	SEE NOTES
VAV-2B-16	HRU-1	B231 CORRIDOR	8	375	60	0	1.00			TITUS	DESV	SEE NOTES
VAV-2B-17	HRU-2	B203B RELATED CR	8	535	125	0	1.00			TITUS	DESV	SEE NOTES
VAV-2B-18	HRU-2	B203 MARKETING	8	360	125	0	1.00			TITUS	DESV	SEE NOTES
VAV-2B-19	HRU-2	B202A RELATED CR	8	540	125	0	1.00			TITUS	DESV	SEE NOTES
VAV-2B-20	HRU-2	B202 BUS OFFICE TECH	8	540	125	0	1.00			TITUS	DESV	SEE NOTES
VAV-2B-21	HRU-2	B201B COMP LAB	8	370	125	0	1.00			TITUS	DESV	SEE NOTES
VAV-2B-22	HRU-2	B201 DRAFTING AND DESIGN	10	810	0	275	0.00			TITUS	DESV	SEE NOTES
VAV-2B-23	HRU-2	B201G COMP LAB	10	700	0	235	0.00			TITUS	DESV	SEE NOTES
VAV-2B-24	HRU-2	A206B COMP LAB	10	710	0	240	0.00			TITUS	DESV	SEE NOTES
VAV-2B-25	HRU-2	A307 SPED	10	280	0	0	0.00			TITUS	DESV	SEE NOTES

- NOTES:
- REFER TO SPECIFICATIONS SECTION 230000 FOR ALTERNATE MANUFACTURERS FOR PRODUCTS/SYSTEMS LISTED UNDER THIS SCHEDULE.
 - PROVIDE 1" DOUBLEWALL PERFORATED LINER FOR ALL VAV TERMINALS.
 - REFER TO FLOOR PLANS. VAV TERMINALS ARE PROVIDED WITH AND WITHOUT ELECTRIC RE-HEAT COILS.
 - CONFIRM LEFT OR RIGHT HAND CONTROL LOCATION IN THE FIELD.
 - PROVIDE INLET VELOCITY SENSOR.
 - PROVIDE 1" INER FOR 12" DOWNSTREAM OF ALL VAV BOXES.
 - SCHEDULE TOTAL PRESSURE DROP ACROSS PRIMARY AIR VALVE IS APPLICABLE AT MAXIMUM AIRFLOW SETPOINT.
 - CONTROLS AND CONTROLLER TO BE PROVIDED BY ATC CONTRACTOR.

M1-1-2B VARIABLE AIR VOLUME EXHAUST AIR TERMINAL SCHEDULE (VVE)

UNIT NO	TYPE	INLET DIAMETER (IN)	MAX AIRFLOW (CFM)	MIN TURNDOWN (CFM)	MANUFACTURER	MODEL	REMARKS
VVE-2B-01	SINGLE DUCT EXHAUST	6	370	370	TITUS	DESV	
VVE-2B-02	SINGLE DUCT EXHAUST	4	0	75	TITUS	DESV	
VVE-2B-03	SINGLE DUCT EXHAUST	5	0	125	TITUS	DESV	
VVE-2B-04	SINGLE DUCT EXHAUST	6	370	370	TITUS	DESV	
VVE-2B-05	SINGLE DUCT EXHAUST	6	370	370	TITUS	DESV	
VVE-2B-06	SINGLE DUCT EXHAUST	6	370	370	TITUS	DESV	
VVE-2B-07	SINGLE DUCT EXHAUST	6	370	370	TITUS	DESV	
VVE-2B-08	SINGLE DUCT EXHAUST	6	370	370	TITUS	DESV	
VVE-2B-09	SINGLE DUCT EXHAUST	6	370	370	TITUS	DESV	
VVE-2B-10	SINGLE DUCT EXHAUST	6	370	370	TITUS	DESV	
VVE-2B-11	SINGLE DUCT EXHAUST	6	370	370	TITUS	DESV	
VVE-2B-12	SINGLE DUCT EXHAUST	5	0	125	TITUS	DESV	
VVE-2B-13	SINGLE DUCT EXHAUST	4	140	140	TITUS	DESV	
VVE-2B-14	SINGLE DUCT EXHAUST	9	800	800	TITUS	DESV	
VVE-2B-15	SINGLE DUCT EXHAUST	8	0	80	TITUS	DESV	
VVE-2B-16	SINGLE DUCT EXHAUST	8	0	80	TITUS	DESV	
VVE-2B-17	SINGLE DUCT EXHAUST	8	0	80	TITUS	DESV	
VVE-2B-18	SINGLE DUCT EXHAUST	8	0	80	TITUS	DESV	
VVE-2B-19	SINGLE DUCT EXHAUST	8	0	80	TITUS	DESV	
VVE-2B-20	SINGLE DUCT EXHAUST	10	0	240	TITUS	DESV	
VVE-2B-21	SINGLE DUCT EXHAUST	8	0	80	TITUS	DESV	
VVE-2B-22	SINGLE DUCT EXHAUST	10	0	240	TITUS	DESV	
VVE-2B-23	SINGLE DUCT EXHAUST	4	150	150	TITUS	DESV	
VVE-2B-24	SINGLE DUCT EXHAUST	9	0	600	TITUS	DESV	

- NOTES:
- REFER TO SPECIFICATIONS SECTION 230000 FOR ALTERNATE MANUFACTURERS FOR PRODUCTS/SYSTEMS LISTED UNDER THIS SCHEDULE.
 - PROVIDE 1" DOUBLEWALL PERFORATED LINER FOR ALL VAV TERMINALS.
 - CONFIRM LEFT OR RIGHT HAND CONTROL LOCATION IN THE FIELD.
 - PROVIDE INLET VELOCITY SENSOR.
 - PROVIDE 1" INER FOR 12" DOWNSTREAM OF ALL VAV BOXES.
 - SCHEDULE TOTAL PRESSURE DROP ACROSS PRIMARY AIR VALVE IS APPLICABLE AT MAXIMUM AIRFLOW SETPOINT.
 - CONTROLS AND CONTROLLER TO BE PROVIDED BY ATC CONTRACTOR.

HVAC DRAWING NOTES

DRA


Drumrey Rosane Anderson, Inc.
225 Oakland Road
Studio 205
South Windsor, CT
06094

260 Charles Street
Studio 300
Waltham, MA
02453

Planning | Architecture | Interior Design
Tel: 817.984.1700
www.dra.com

Northeast
Metropolitan
Regional
Vocational High
School

Wakefield, MA 01880

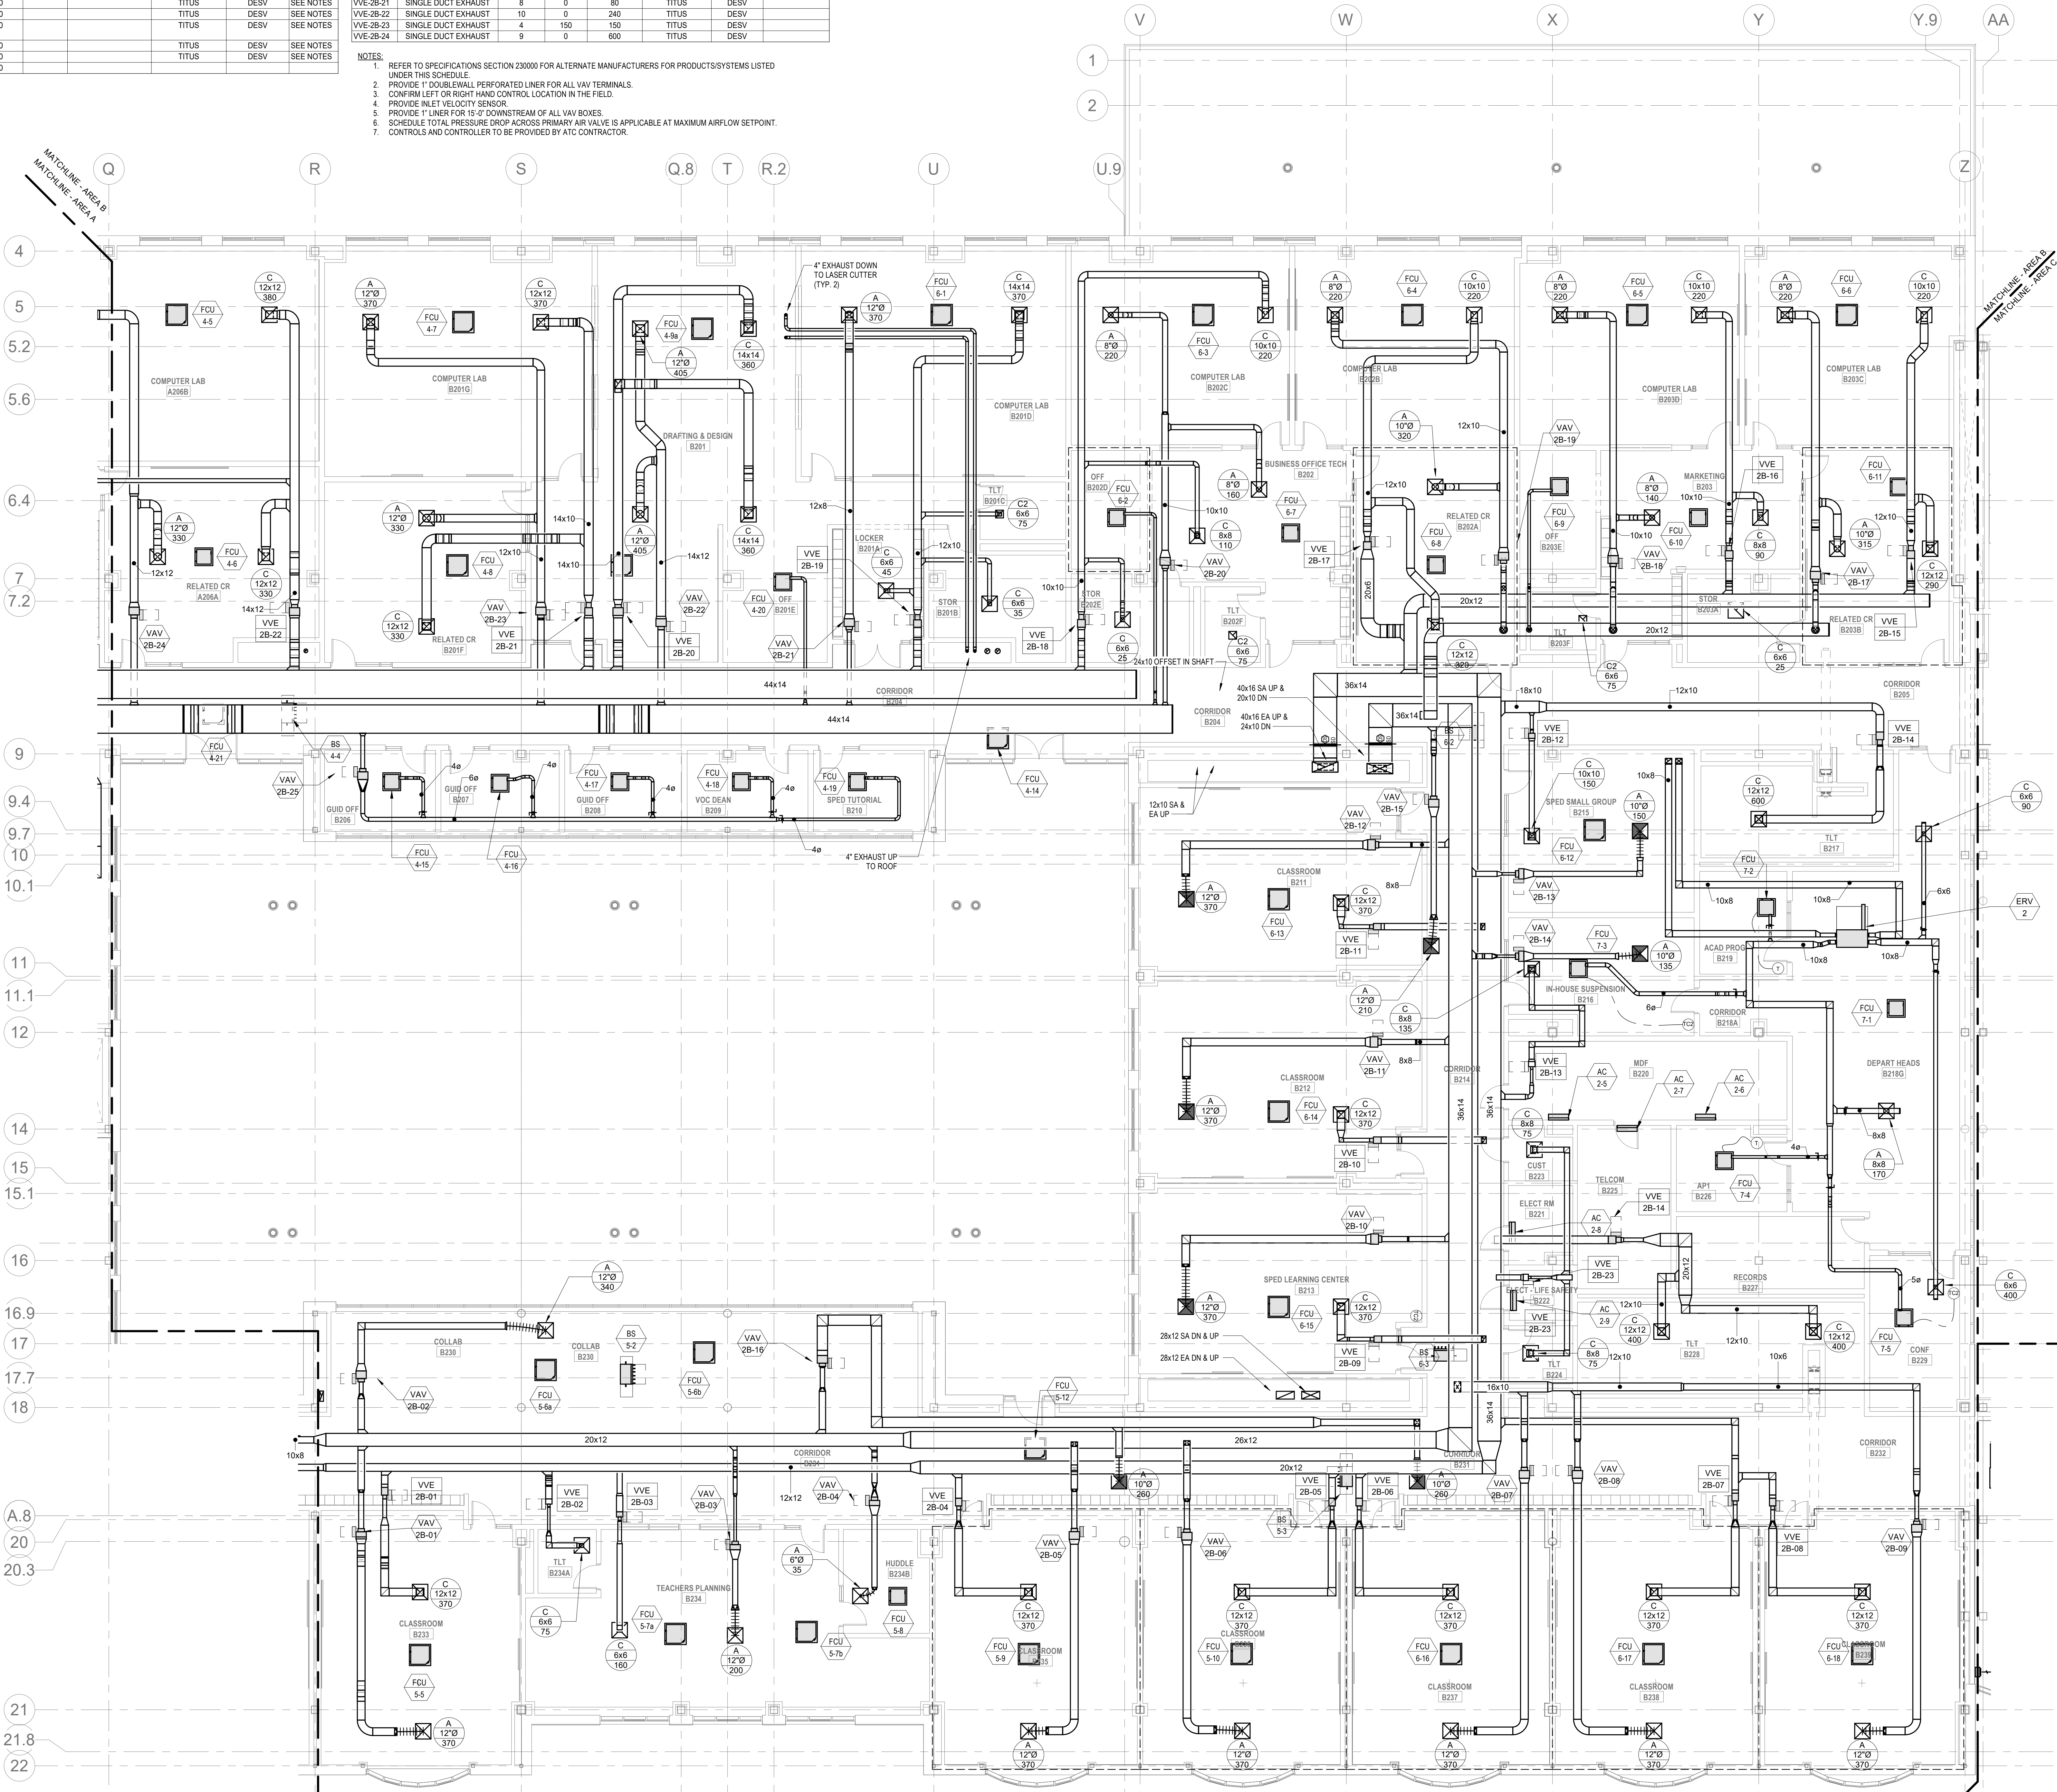


© COPYRIGHT 2021 DRUMREY ROSANE ANDERSON, INC.

BALA
ENGINEERS


MSBA 60% CD
SUBMISSION

January 13, 2023

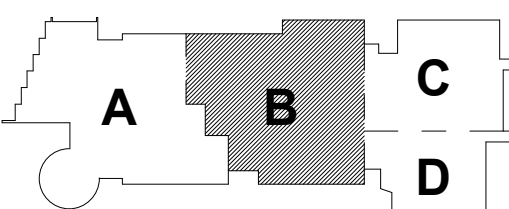

KEY PLAN

PROJECT NORTH MAGNETIC NORTH

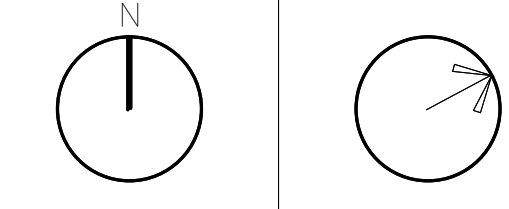

MECHANICAL
DUCTWORK
SECOND FLOOR
PLAN - AREA B

Scale: 1/8" = 1'-0"

Job No.: 20202

Drawn By: DRA

Date: January 13, 2023

M1-1-2B

HVAC DRAWING NOTES

- 48"Ø DIAMETER EA DUCT DOWN.
- 72x12 EA DUCT UP TO ROOF VENT.
- 30"Ø DIAMETER EA DUCT DOWN.
- NOT USED.
- NOT USED.
- NOT USED.
- 10"Ø DIAMETER EA DUCT DOWN.
- 10"Ø DIAMETER EA DUCT UP TO FAN ON ROOF.
- 48"Ø DIAMETER EA DUCT UP TO FAN ON ROOF AND DN.
- NOT USED.
- 36"Ø DIAMETER EA DUCT DOWN.
- 36"Ø DIAMETER EA DUCT UP TO FAN ON ROOF.

DRA


Drumme Rosane Anderson, Inc.
225 Oakland Road
Studio 205
South Windsor, CT
06074
Tel: 817.984.1700
www.dra-inc.com

280 Charles Street
Studio 300
Waltham, MA
02453

Planning | Architecture | Interior Design

Northeast
Metropolitan
Regional
Vocational High
School

Wakefield, MA 01880

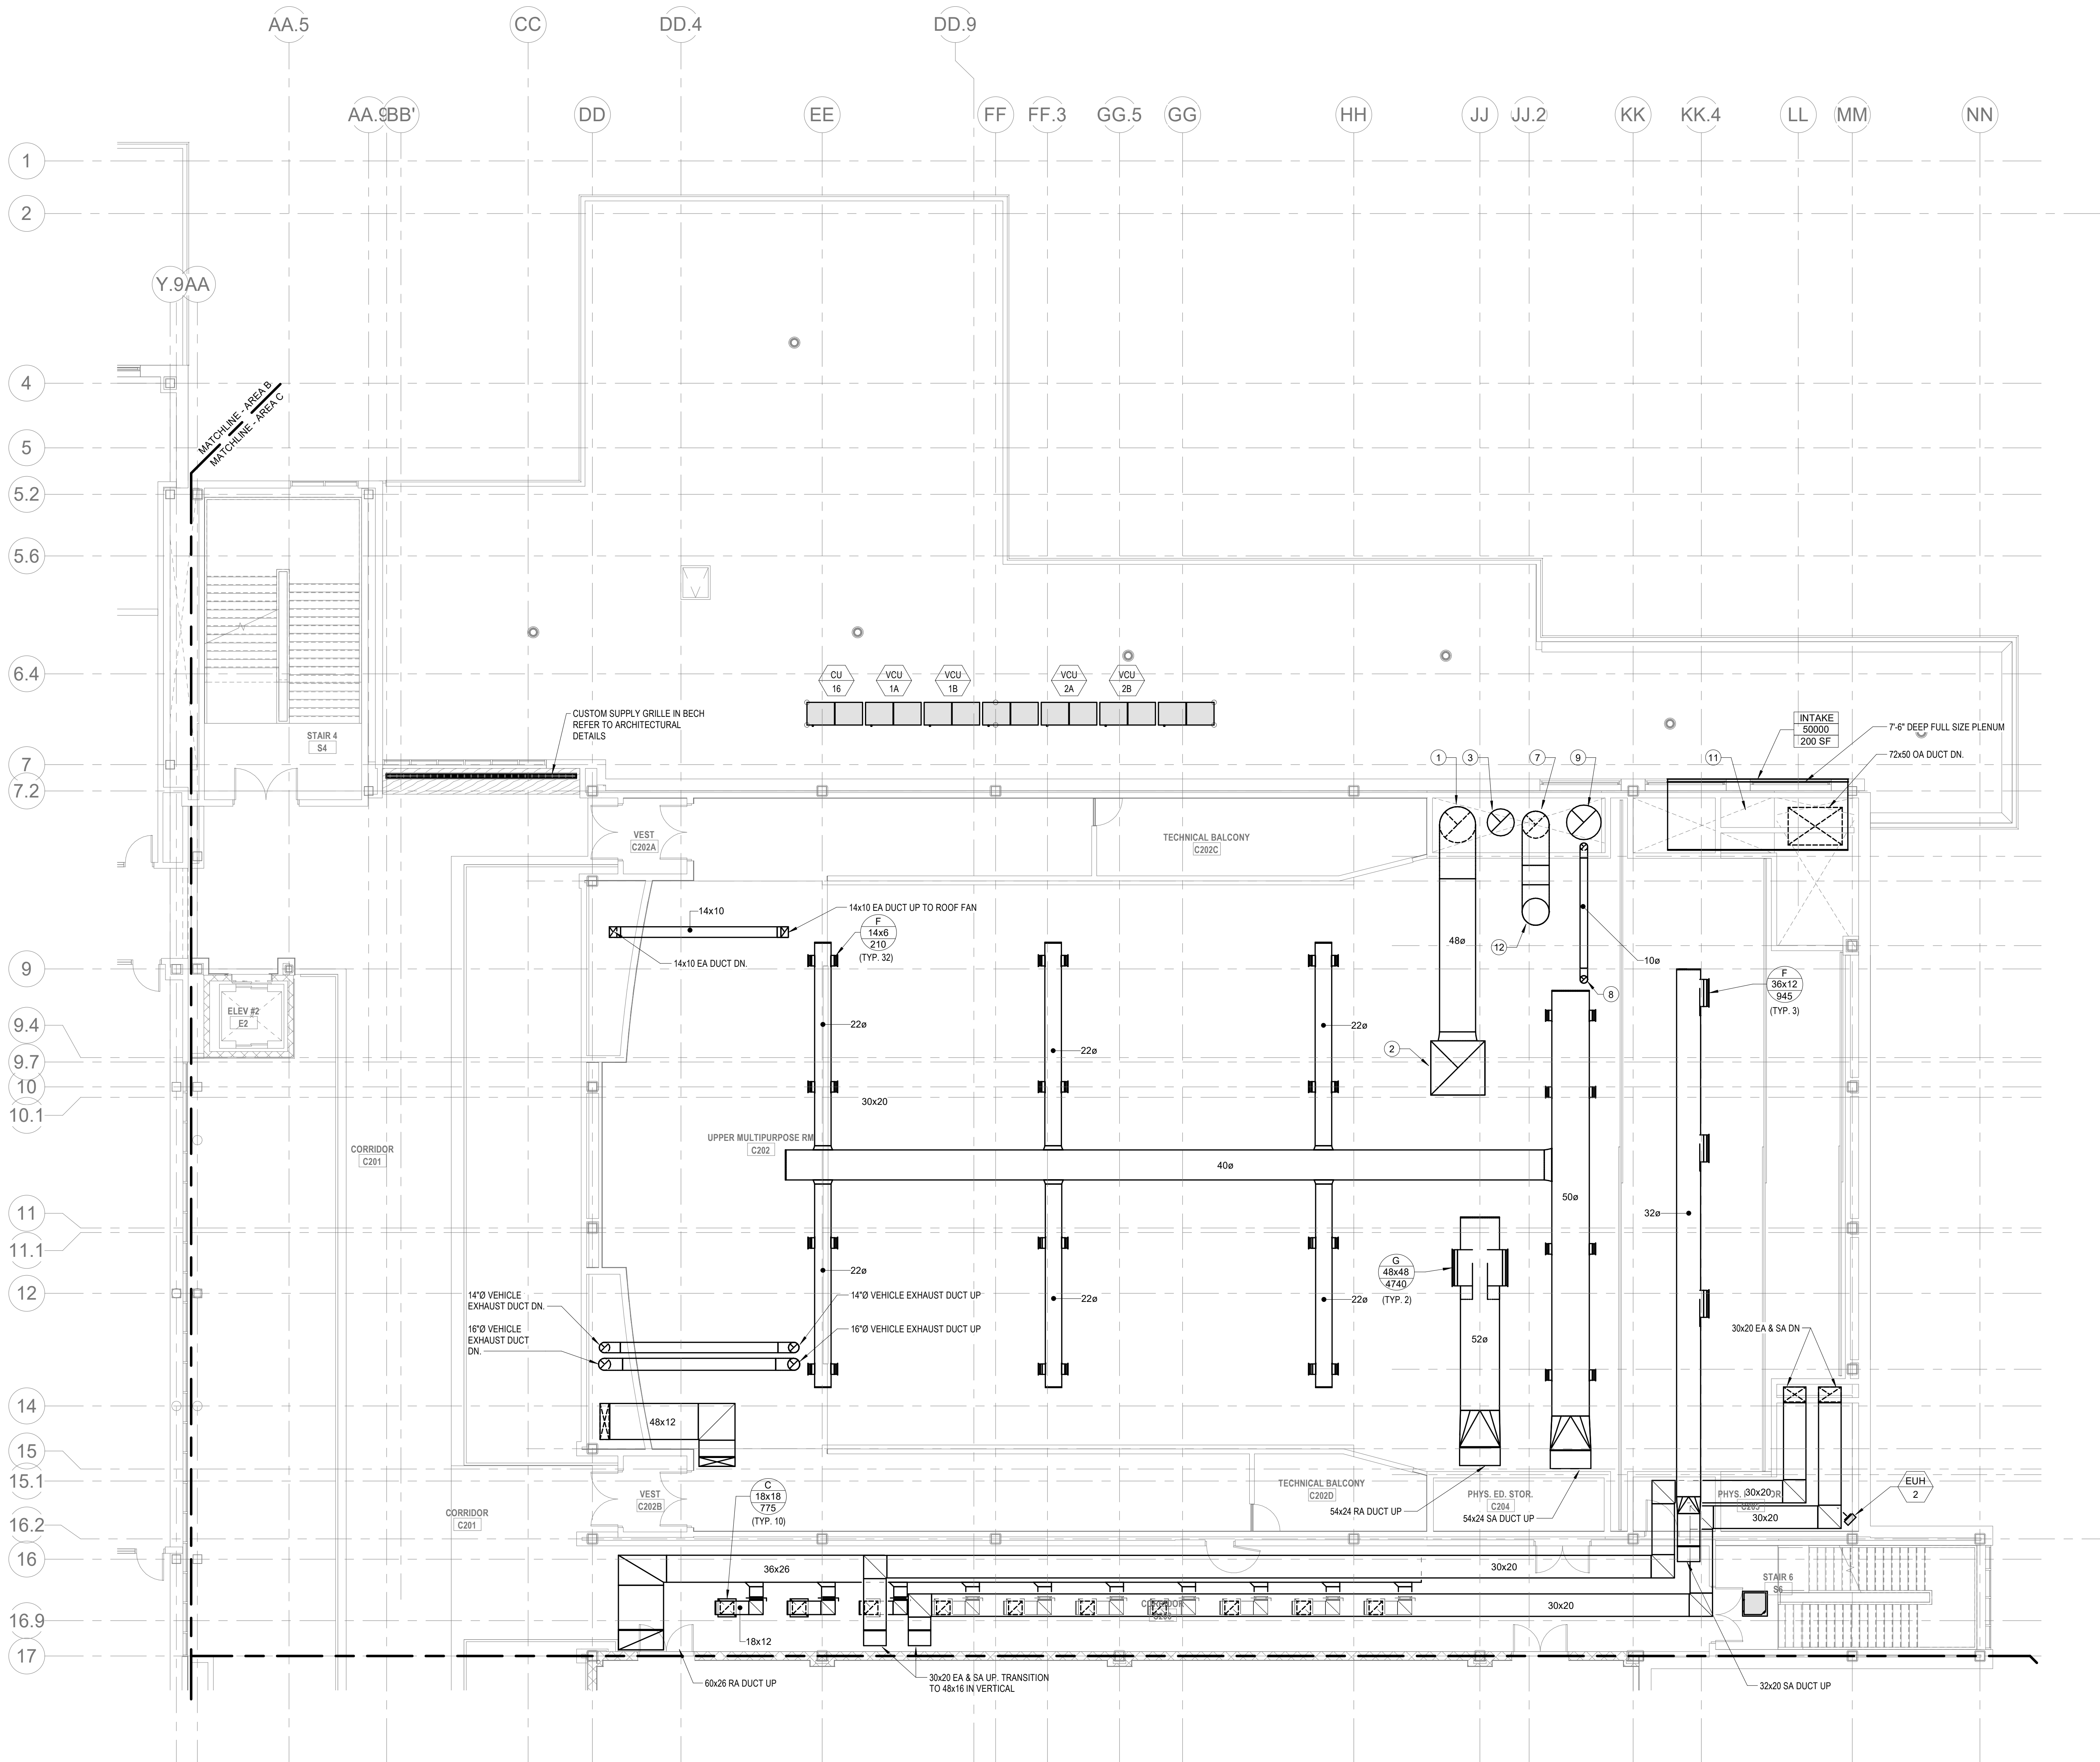


© COPYRIGHT 2021 DRUMMEY ROSANE ANDERSON, INC.

BALA
ENGINEERS

MSBA 60% CD
SUBMISSION



January 13, 2023

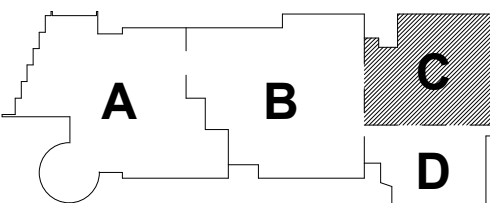

KEY PLAN

PROJECT NORTH

MAGNETIC NORTH

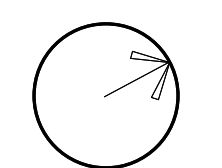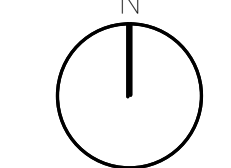

MECHANICAL
DUCTWORK
SECOND FLOOR
PLAN - AREA C

Scale: 1/8" = 1'-0"
Job No.: 20202
Drawn By: DRA
Date: January 13, 2023

M1-1-2C

HVAC DRAWING NOTES


1.

DRA

DrummeY Rosane Anderson, Inc.
225 Oakland Road
Studio 205
South Windsor, CT
06074
Planning | Architecture | Interior Design
Tel: 817.984.1700
www.draa.com

Northeast
Metropolitan
Regional
Vocational High
School

Wakefield, MA 01880

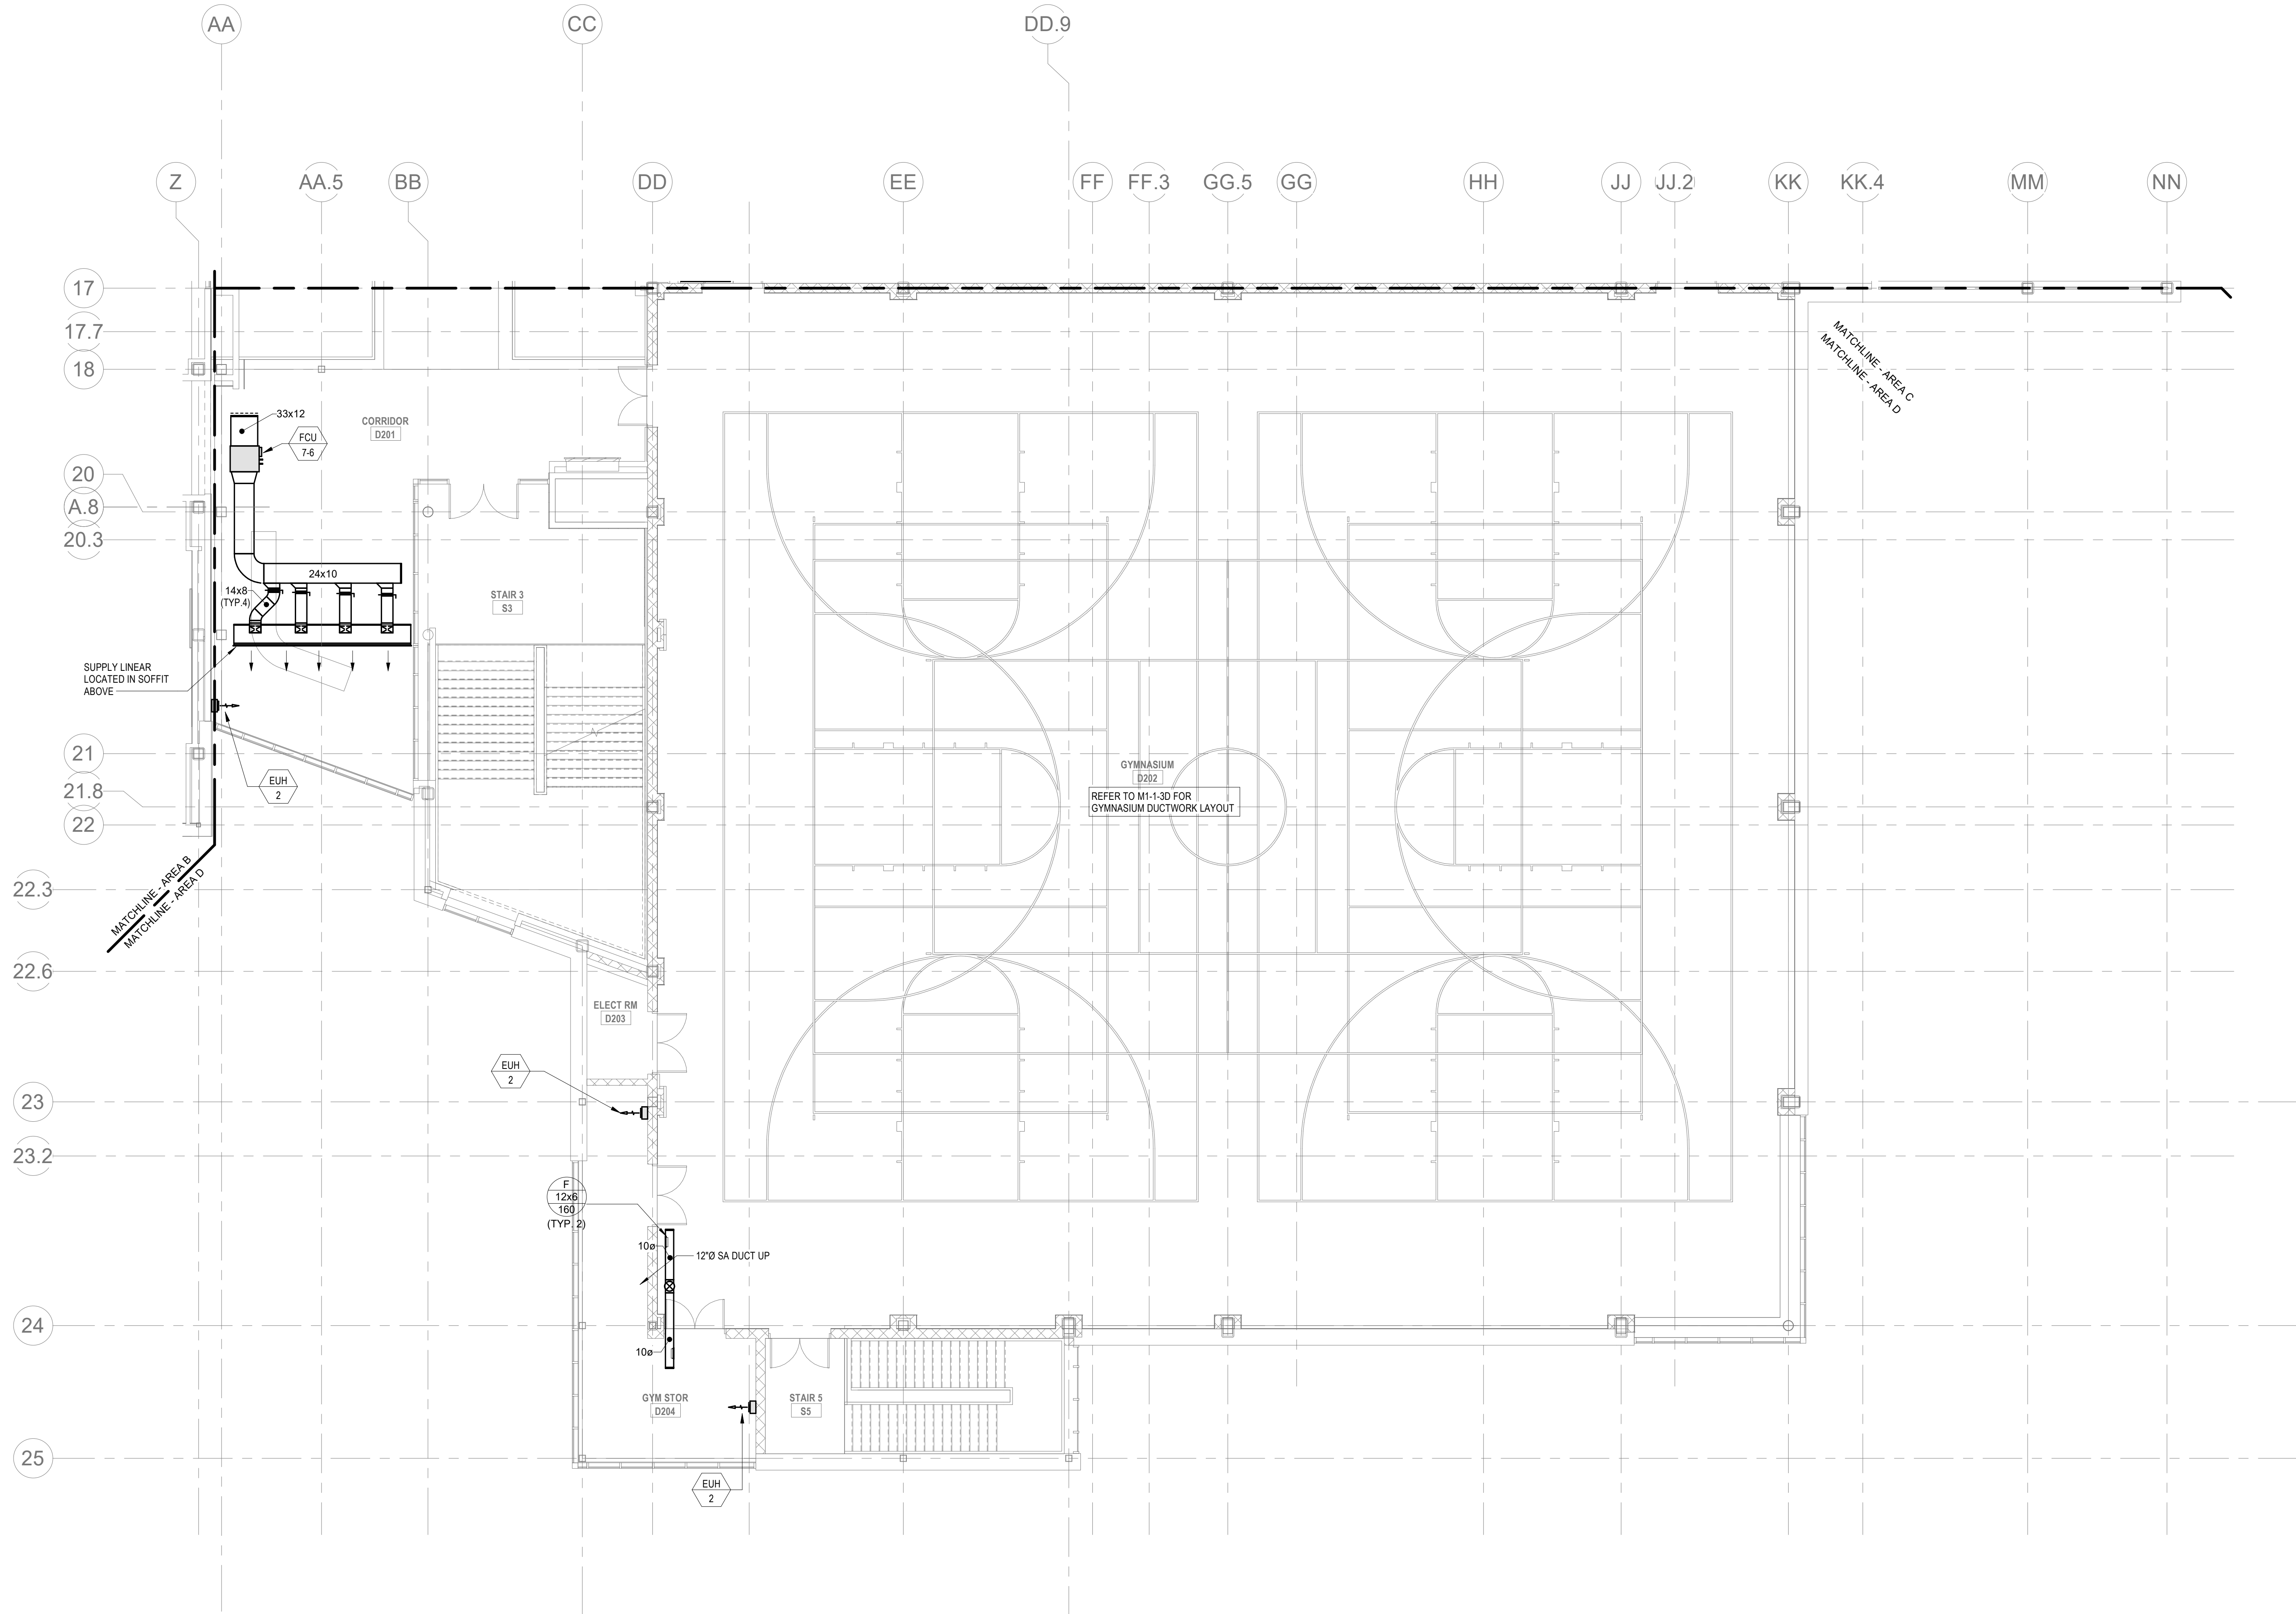


© COPYRIGHT 2021 DRUMMEY ROSANE ANDERSON, INC.

BALA
ENGINEERS
BALA CONSULTING ENGINEERS, INC.
200 WEST 14TH STREET, SUITE 200
NEW YORK, NY 10011-4209
TEL: 212.693.1200 FAX: 212.693.1201
WWW.BALA-ENGINEERS.COM


MSBA 60% CD
SUBMISSION

January 13, 2023

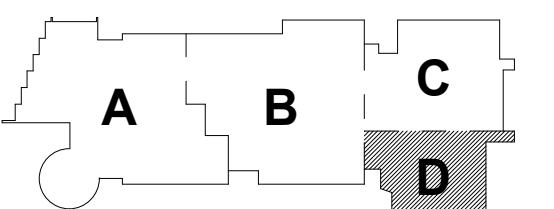

KEY PLAN

PROJECT NORTH MAGNETIC NORTH

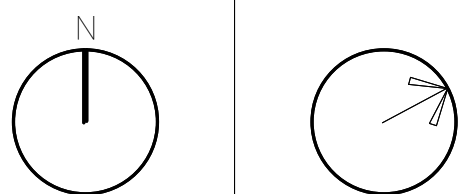

MECHANICAL
DUCTWORK
SECOND FLOOR
PLAN - AREA D

Scale: 1/8" = 1'-0"
Job No.: 20202
Drawn By: DRA
Date: January 13, 2023

M1-1-2D

M1-1-3A - VARIABLE AIR VOLUME TERMINAL (VAV)

UNIT NO	SYSTEM	ROOM SERVED	PRIMARY AIR VALVE INLET DIA (IN)	Air Terminal Air Flow	PRIMARY AIR VALVE		TOTAL PRESS DROP (IN WG)	SOUND DATA - MAX PWL IN 3RD OCTAVE @ 1.0" INLET PRESSURE		DISCH	RAD	MANUFACTURER	MODEL	NOTES
					MIN FLOW OCCUPIED (CFM)	MINIMUM FLOW UNOCCUPIED (CFM)								
VAV-3A-01	HRU-1	A323 CR	8	370	60	0	1.00					TITUS	DESV	SEE NOTES
VAV-3A-02	HRU-1	A323 CR	8	370	60	0	1.00					TITUS	DESV	SEE NOTES
VAV-3A-03	HRU-1	A324 CR	8	370	60	0	1.00					TITUS	DESV	SEE NOTES
VAV-3A-04	HRU-1	A320 SCI LAB	14	1350	510	0	0.00					TITUS	DESV	SEE NOTES
VAV-3A-05	HRU-1	A324 CR	8	370	60	0	1.00					TITUS	DESV	SEE NOTES
VAV-3A-06	HRU-2	A309 CORR	14	1430	510	0	0.00					TITUS	DESV	SEE NOTES
VAV-3A-07	HRU-1	A308 DIG. LRNG	8	370	60	0	1.00					TITUS	DESV	SEE NOTES
VAV-3A-08	HRU-1	A307 SPD	4	160	35	35	1.00					TITUS	DESV	SEE NOTES
VAV-3A-09	HRU-1	A308 SPD	4	160	35	35	1.00					TITUS	DESV	SEE NOTES
VAV-3A-10	HRU-1	A305 HEALTH CR	8	370	60	0	1.00					TITUS	DESV	SEE NOTES
VAV-3A-11	HRU-1	A302 BIO CR	8	370	60	0	1.00					TITUS	DESV	SEE NOTES
VAV-3A-12	HRU-1	A302 BIO CR	8	370	60	0	1.00					TITUS	DESV	SEE NOTES
VAV-3A-13	HRU-2	A309 CORR	14	1445	510	0	0.00					TITUS	DESV	SEE NOTES
VAV-3A-14	HRU-2	A320 SCI LAB	14	1445	510	0	0.00					TITUS	DESV	SEE NOTES
VAV-3A-15	HRU-2	A322 CR	14	1450	510	0	0.00					TITUS	DESV	SEE NOTES
VAV-3A-16	HRU-2	A322 CR	8	370	125	0	1.00					TITUS	DESV	SEE NOTES
VAV-3A-17	HRU-2	A322 CR	14	1645	510	0	0.00					TITUS	DESV	SEE NOTES

- NOTES:
- REFER TO SPECIFICATIONS SECTION 230000 FOR ALTERNATE MANUFACTURERS FOR PRODUCTS/SYSTEMS LISTED UNDER THIS SCHEDULE.
 - PROVIDE 1" DOUBLEWALL PERFORATED LINER FOR ALL VAV TERMINALS.
 - REFER TO FLOOR PLANS. VAV TERMINALS ARE PROVIDED WITH AND WITHOUT ELECTRIC RE-HEAT COILS.
 - CONFIRM LEFT OR RIGHT HAND CONTROL LOCATION IN THE FIELD.
 - PROVIDE INLET VELOCITY SENSOR.
 - PROVIDE 1" LINER FOR 15' DOWNSTREAM OF ALL VAV BOXES.
 - SCHEDULE TOTAL PRESSURE DROP ACROSS PRIMARY AIR VALVE IS APPLICABLE AT MAXIMUM AIRFLOW SETPOINT.
 - CONTROLS AND CONTROLLER TO BE PROVIDED BY ATC CONTRACTOR.

M1-1-3A VARIABLE AIR VOLUME EXHAUST AIR TERMINAL SCHEDULE (VVE)

UNIT NO	TYPE	INLET DIAMETER (IN)	MAX AIRFLOW (CFM)	MIN TURNDOWN (CFM)	MANUFACTURER	MODEL	REMARKS
VVE-3A-01	SINGLE DUCT EXHAUST	6	0	125	TITUS	DESV	
VVE-3A-02	SINGLE DUCT EXHAUST	6	0	125	TITUS	DESV	
VVE-3A-03	SINGLE DUCT EXHAUST	6	0	125	TITUS	DESV	
VVE-3A-04	SINGLE DUCT EXHAUST	12	0	1400	TITUS	DESV	
VVE-3A-05	SINGLE DUCT EXHAUST	6	0	125	TITUS	DESV	
VVE-3A-06	SINGLE DUCT EXHAUST	8	0	600	TITUS	DESV	
VVE-3A-07	SINGLE DUCT EXHAUST	6	0	125	TITUS	DESV	
VVE-3A-08	SINGLE DUCT EXHAUST	4	0	70	TITUS	DESV	
VVE-3A-09	SINGLE DUCT EXHAUST	4	0	70	TITUS	DESV	
VVE-3A-10	SINGLE DUCT EXHAUST	6	0	125	TITUS	DESV	
VVE-3A-11	SINGLE DUCT EXHAUST	6	0	125	TITUS	DESV	
VVE-3A-12	SINGLE DUCT EXHAUST	8	0	125	TITUS	DESV	
VVE-3A-13	SINGLE DUCT EXHAUST	6	0	125	TITUS	DESV	
VVE-3A-14	SINGLE DUCT EXHAUST	6	0	125	TITUS	DESV	
VVE-3A-15	SINGLE DUCT EXHAUST	7	0	335			
VVE-3A-16	SINGLE DUCT EXHAUST	8	0	80	TITUS	DESV	
VVE-3A-17	SINGLE DUCT EXHAUST	7	0	335			
VVE-3A-34	SINGLE DUCT EXHAUST	8	0	125	TITUS	DESV	

- NOTES:
- REFER TO SPECIFICATIONS SECTION 230000 FOR ALTERNATE MANUFACTURERS FOR PRODUCTS/SYSTEMS LISTED UNDER THIS SCHEDULE.
 - PROVIDE 1" DOUBLEWALL PERFORATED LINER FOR ALL VAV TERMINALS.
 - CONFIRM LEFT OR RIGHT HAND CONTROL LOCATION IN THE FIELD.
 - PROVIDE INLET VELOCITY SENSOR.
 - PROVIDE 1" LINER FOR 15' DOWNSTREAM OF ALL VAV BOXES.
 - SCHEDULE TOTAL PRESSURE DROP ACROSS PRIMARY AIR VALVE IS APPLICABLE AT MAXIMUM AIRFLOW SETPOINT.
 - CONTROLS AND CONTROLLER TO BE PROVIDED BY ATC CONTRACTOR.

HVAC DRAWING NOTES


DRA

Drummeay Rosane Anderson, Inc.
225 Oakland Road
Studio 205
South Windsor, CT 06074

260 Charles Street
Studio 300
Waltham, MA 02453
Tel: 617.984.1700
www.draam.com

Northeast
Metropolitan
Regional
Vocational High
School

Wakefield, MA 01880

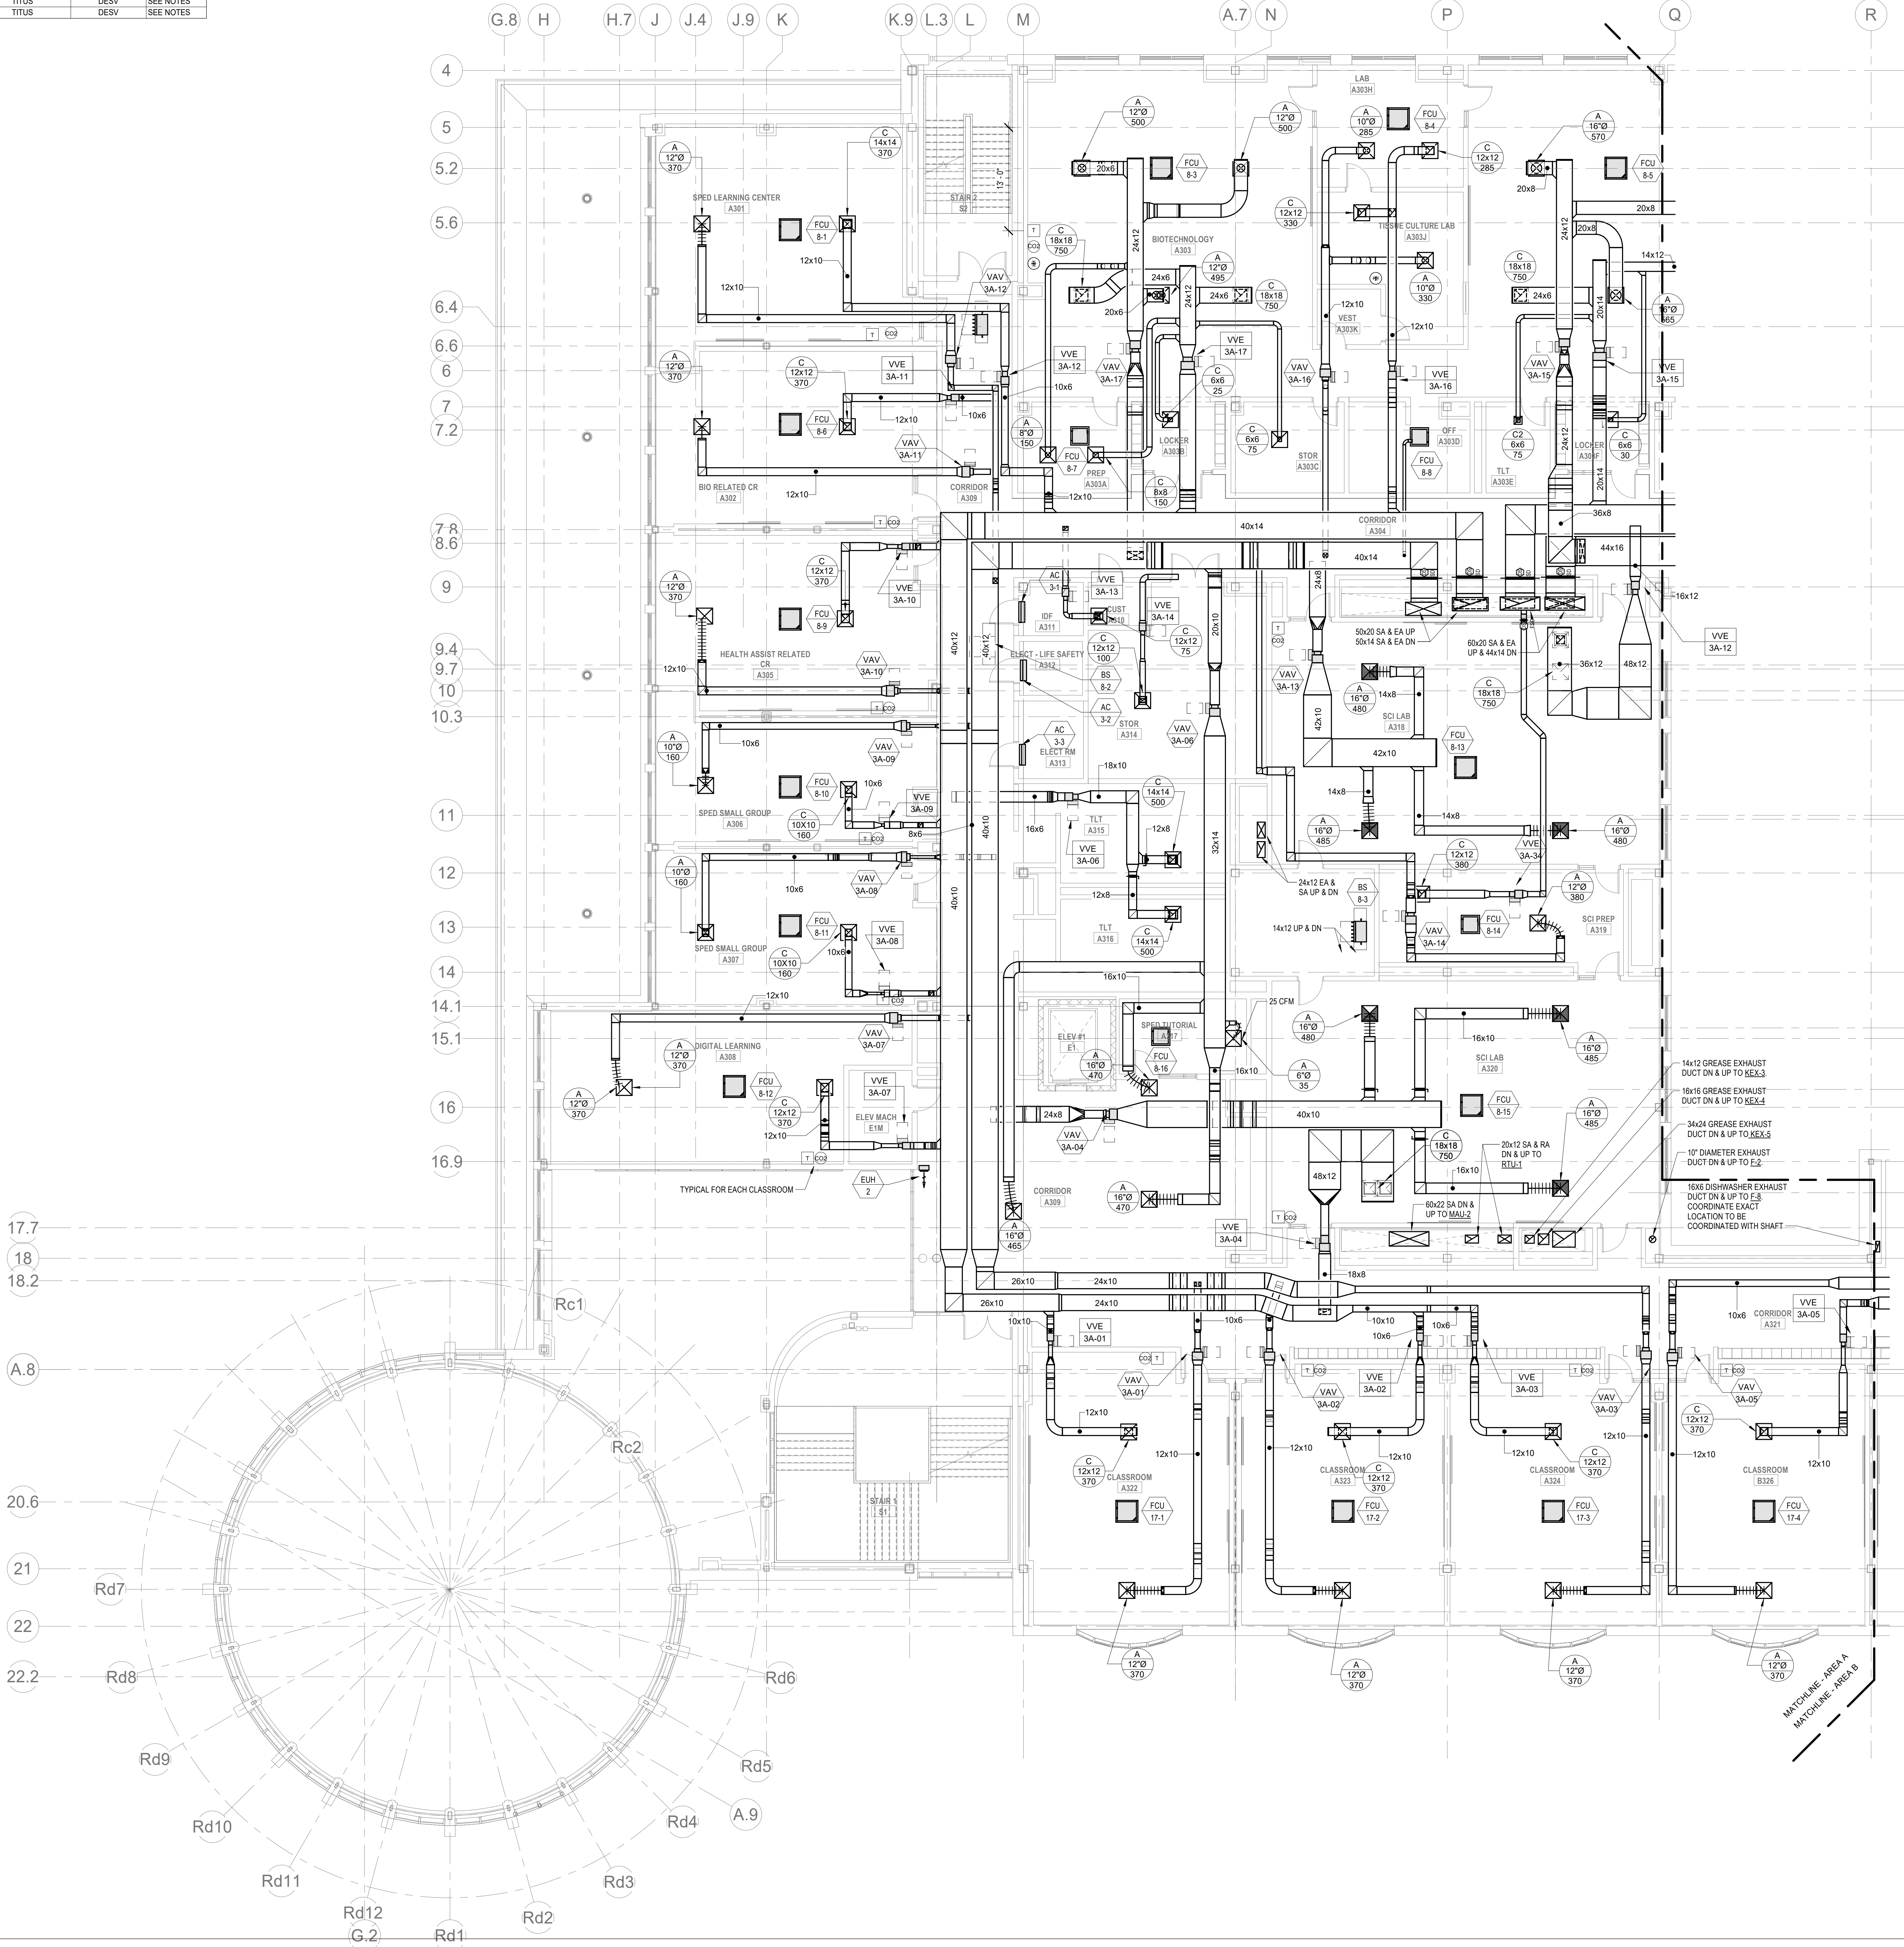


© COPYRIGHT 2021 DRUMMEAY ROSANE ANDERSON, INC.

BALA
ENGINEERS

MSBA 60% CD
SUBMISSION



January 13, 2023

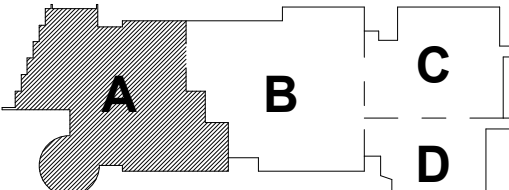

KEY PLAN

PROJECT NORTH

MAGNETIC NORTH

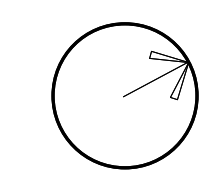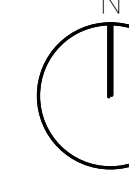

MECHANICAL
DUCTWORK
THIRD FLOOR
PLAN - AREA A


Scale: 1/8" = 1'-0"

Job No.: 20022

Drawn By: DRA

Date: January 13, 2023

M1-1-3A

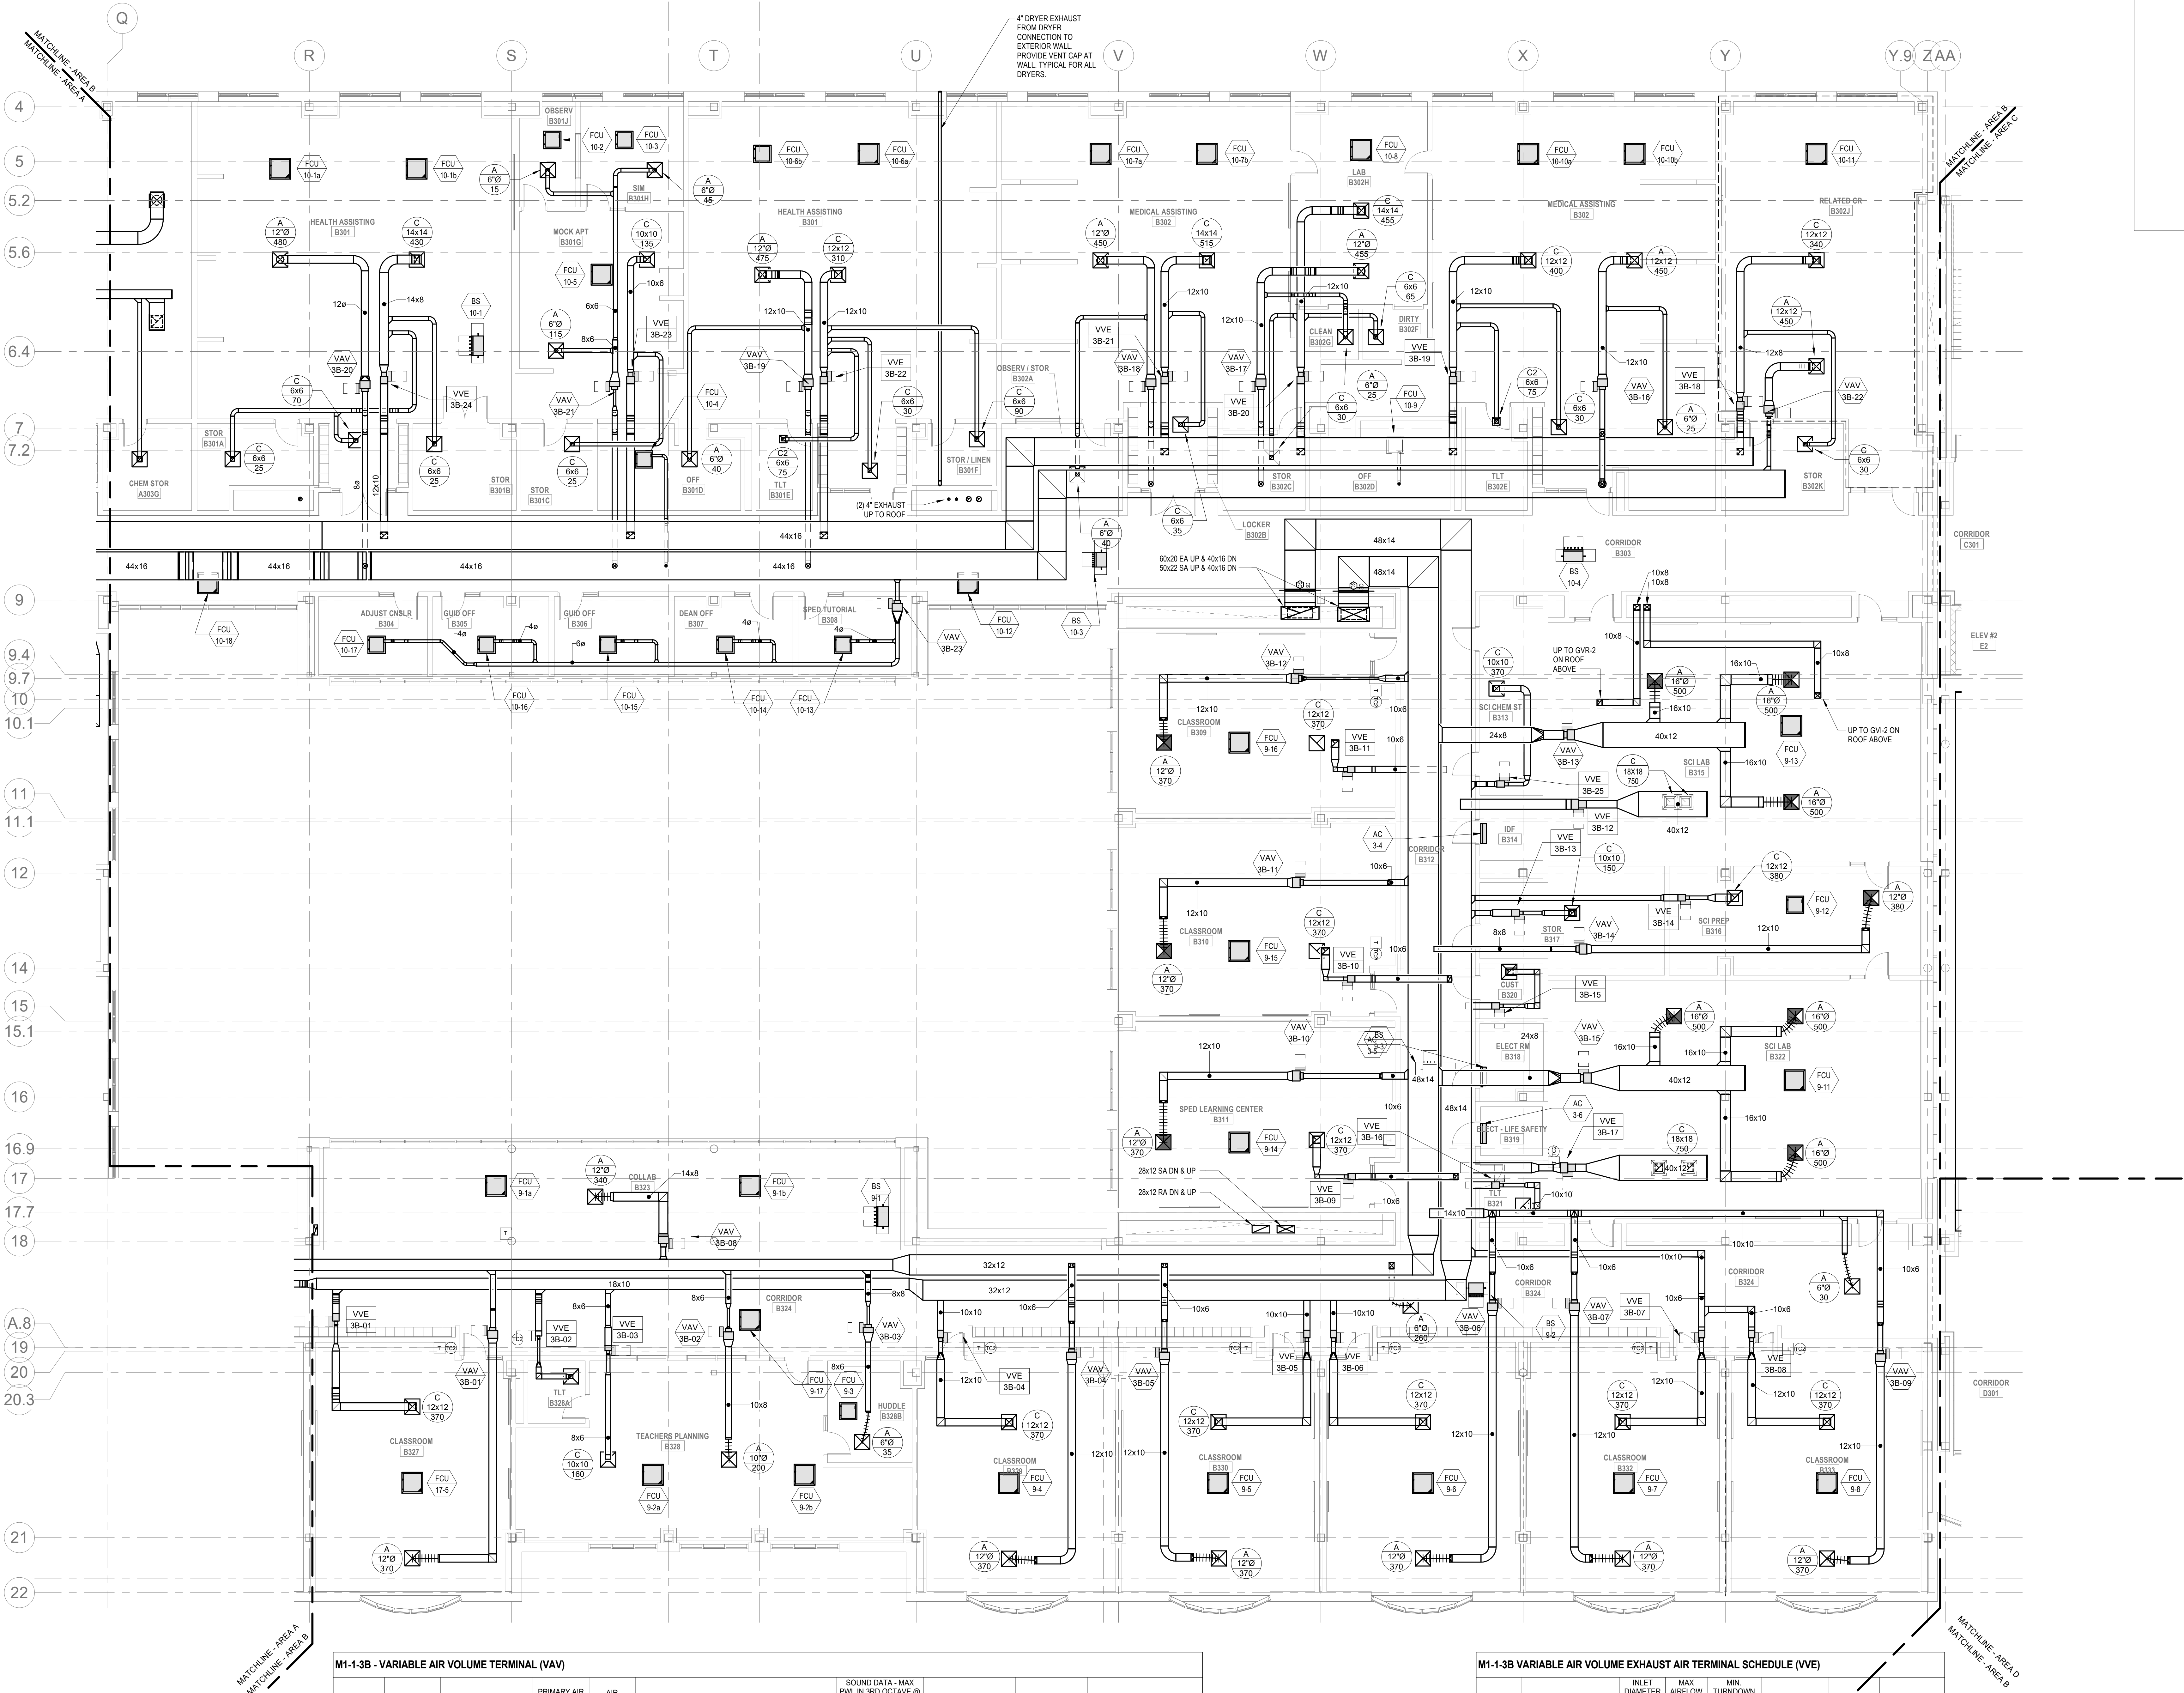

M1-1-3B - VARIABLE AIR VOLUME TERMINAL (VAV)

UNIT NO.	SYSTEM	ROOM SERVED	PRIMARY AIR VALVE PRIMARY INLET DIA (IN)	AIR TERMINAL AIR FLOW	MIN FLOW OCCUPIED (CFM)	MINIMUM FLOW UNOCCUPIED (CFM)	TOTAL PRESS DROP (IN WG)	DISCH	RAD	MANUFACTURER	MODEL	NOTES
VAV-38-01	HRU-2	B327 CR	8	370	0	0.00	0.00			TITUS	DESV	SEE NOTES
VAV-38-02	HRU-1	B328 TEACHERS PLAN	6	200	30	70	1.00			TITUS	DESV	SEE NOTES
VAV-38-03	HRU-2	B329B HUDDLE	4	35	35	140	1.00			TITUS	DESV	SEE NOTES
VAV-38-04	HRU-2	B330 CR	8	370	125	0	1.00			TITUS	DESV	SEE NOTES
VAV-38-05	HRU-1	B330 CR	8	370	125	0	1.00			TITUS	DESV	SEE NOTES
VAV-38-06	HRU-2	B332 CR	8	370	125	0	1.00			TITUS	DESV	SEE NOTES
VAV-38-07	HRU-2	B332 CR	8	370	125	0	1.00			TITUS	DESV	SEE NOTES
VAV-38-08	HRU-2	B333 COLLAB	8	370	125	0	1.00			TITUS	DESV	SEE NOTES
VAV-38-09	HRU-2	B333 CR	8	370	125	0	1.00			TITUS	DESV	SEE NOTES
VAV-38-10	HRU-2	B311 SPED	8	370	125	0	1.00			TITUS	DESV	SEE NOTES
VAV-38-11	HRU-2	B310 CR	8	370	125	0	1.00			TITUS	DESV	SEE NOTES
VAV-38-12	HRU-2	B309 CR	8	370	125	0	1.00			TITUS	DESV	SEE NOTES
VAV-38-13	HRU-2	B316 SCI LAB	0	1500	510	0	0.00			TITUS	DESV	SEE NOTES
VAV-38-14	HRU-2	B316 SCI PREP	8	380	125	0	1.00			TITUS	DESV	SEE NOTES
VAV-38-15	HRU-2	B322 SCI LAB	0	1500	510	0	0.00			TITUS	DESV	SEE NOTES
VAV-38-16	HRU-2	B302 MEDICAL ASSIST	8	475	0	0	0.00			TITUS	DESV	SEE NOTES
VAV-38-17	HRU-1	B302H LAB	8	370	80	0	1.00			TITUS	DESV	SEE NOTES
VAV-38-18	HRU-1	B302 MEDICAL ASSIST	8	490	80	0	1.00			TITUS	DESV	SEE NOTES
VAV-38-19	HRU-1	B301 HEALTH ASSIST	8	515	80	0	1.00			TITUS	DESV	SEE NOTES
VAV-38-20	HRU-2	A322 CR	8	480	125	0	1.00			TITUS	DESV	SEE NOTES
VAV-38-21	HRU-2	B301G MOCK APT	4	175	35	140	1.00			TITUS	DESV	SEE NOTES
VAV-38-22	HRU-2	B302G RELAX CR	8	480	125	0	1.00			TITUS	DESV	SEE NOTES
VAV-38-23	HRU-1	A322 CR	6	180	30	0	1.00			TITUS	DESV	SEE NOTES



- NOTES:
- REFER TO SPECIFICATIONS SECTION 230000 FOR ALTERNATE MANUFACTURERS FOR PRODUCTS/SYSTEMS LISTED UNDER THIS SCHEDULE.
 - PROVIDE 1" DOUBLED WALL PERFORATED LINER FOR ALL VAV TERMINALS.
 - REFER TO FLOOR PLANS. VAV TERMINALS ARE PROVIDED WITH AND WITHOUT ELECTRIC RE-HEAT COILS.
 - CONFIRM LEFT OR RIGHT HAND CONTROL LOCATION IN THE FIELD.
 - PROVIDE INLET VELOCITY SENSOR.
 - PROVIDE 1" LINER FOR 15' DOWNSTREAM OF ALL VAV BOXES.
 - SCHEDULE TOTAL PRESSURE DROP ACROSS PRIMARY AIR VALVE IS APPLICABLE AT MAXIMUM AIRFLOW SETPOINT.
 - CONTROLS AND CONTROLLER TO BE PROVIDED BY ATC CONTRACTOR.

M1-1-3B VARIABLE AIR VOLUME EXHAUST AIR TERMINAL SCHEDULE (VVE)

UNIT NO.	TYPE	INLET DIAMETER (IN)	MAX AIRFLOW (CFM)	MIN. TURNDOWN (CFM)	MANUFACTURER	MODEL	REMARKS
VVE-38-01	SINGLE DUCT EXHAUST	6	0	125	TITUS	DESV	
VVE-38-02	SINGLE DUCT EXHAUST	4	0	75	TITUS	DESV	
VVE-38-03	SINGLE DUCT EXHAUST	5	0	125	TITUS	DESV	
VVE-38-04	SINGLE DUCT EXHAUST	6	0	125	TITUS	DESV	
VVE-38-05	SINGLE DUCT EXHAUST	6	0	125	TITUS	DESV	
VVE-38-06	SINGLE DUCT EXHAUST	6	0	125	TITUS	DESV	
VVE-38-07	SINGLE DUCT EXHAUST	6	0	125	TITUS	DESV	
VVE-38-08	SINGLE DUCT EXHAUST	6	0	125	TITUS	DESV	
VVE-38-09	SINGLE DUCT EXHAUST	6	0	125	TITUS	DESV	
VVE-38-10	SINGLE DUCT EXHAUST	6	0	125	TITUS	DESV	
VVE-38-11	SINGLE DUCT EXHAUST	6	0	125	TITUS	DESV	
VVE-38-12	SINGLE DUCT EXHAUST	12	0	125	TITUS	DESV	
VVE-38-13	SINGLE DUCT EXHAUST	6	0	125	TITUS	DESV	
VVE-38-14	SINGLE DUCT EXHAUST	6	0	125	TITUS	DESV	
VVE-38-15	SINGLE DUCT EXHAUST	6	0	125	TITUS	DESV	
VVE-38-16	SINGLE DUCT EXHAUST	6	0	125	TITUS	DESV	
VVE-38-17	SINGLE DUCT EXHAUST	12	0	125	TITUS	DESV	
VVE-38-18	SINGLE DUCT EXHAUST	8	0	105	TITUS	DESV	
VVE-38-19	SINGLE DUCT EXHAUST	8	0	105	TITUS	DESV	
VVE-38-20	SINGLE DUCT EXHAUST	8	0	105	TITUS	DESV	
VVE-38-21	SINGLE DUCT EXHAUST	8	0	105	TITUS	DESV	
VVE-38-22	SINGLE DUCT EXHAUST	8	0	105	TITUS	DESV	
VVE-38-23	SINGLE DUCT EXHAUST	8	0	105	TITUS	DESV	
VVE-38-24	SINGLE DUCT EXHAUST	8	0	105	TITUS	DESV	
VVE-38-25	SINGLE DUCT EXHAUST	6	0	125	TITUS	DESV	

- NOTES:
- REFER TO SPECIFICATIONS SECTION 230000 FOR ALTERNATE MANUFACTURERS FOR PRODUCTS/SYSTEMS LISTED UNDER THIS SCHEDULE.
 - PROVIDE 1" DOUBLED WALL PERFORATED LINER FOR ALL VAV TERMINALS.
 - CONFIRM LEFT OR RIGHT HAND CONTROL LOCATION IN THE FIELD.
 - PROVIDE INLET VELOCITY SENSOR.
 - PROVIDE 1" LINER FOR 15' DOWNSTREAM OF ALL VAV BOXES.
 - SCHEDULE TOTAL PRESSURE DROP ACROSS PRIMARY AIR VALVE IS APPLICABLE AT MAXIMUM AIRFLOW SETPOINT.
 - CONTROLS AND CONTROLLER TO BE PROVIDED BY ATC CONTRACTOR.

© COPYRIGHT 2021 DRUMREY ROSANE ANDERSON, INC.

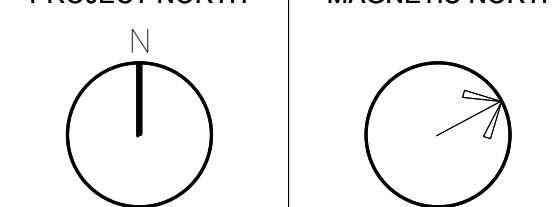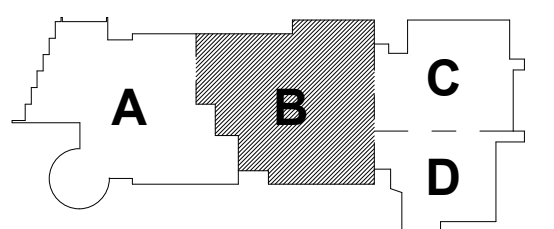

HVAC DRAWING NOTES


1. PROVIDE REMOTE OPERATED BALANCING DAMPER. REFER TO DETAIL XX ON DWG XX.

DRA

Drumme Rosane Anderson, Inc.
225 Oakland Road
Studio 205
South Windsor, CT
06074
260 Charles Street
Studio 300
Waltham, MA
02453
Planning | Architecture | Interior Design
Tel: 617.984.1700
www.draa.com

Northeast
Metropolitan
Regional
Vocational High
School

Wakefield, MA 01880

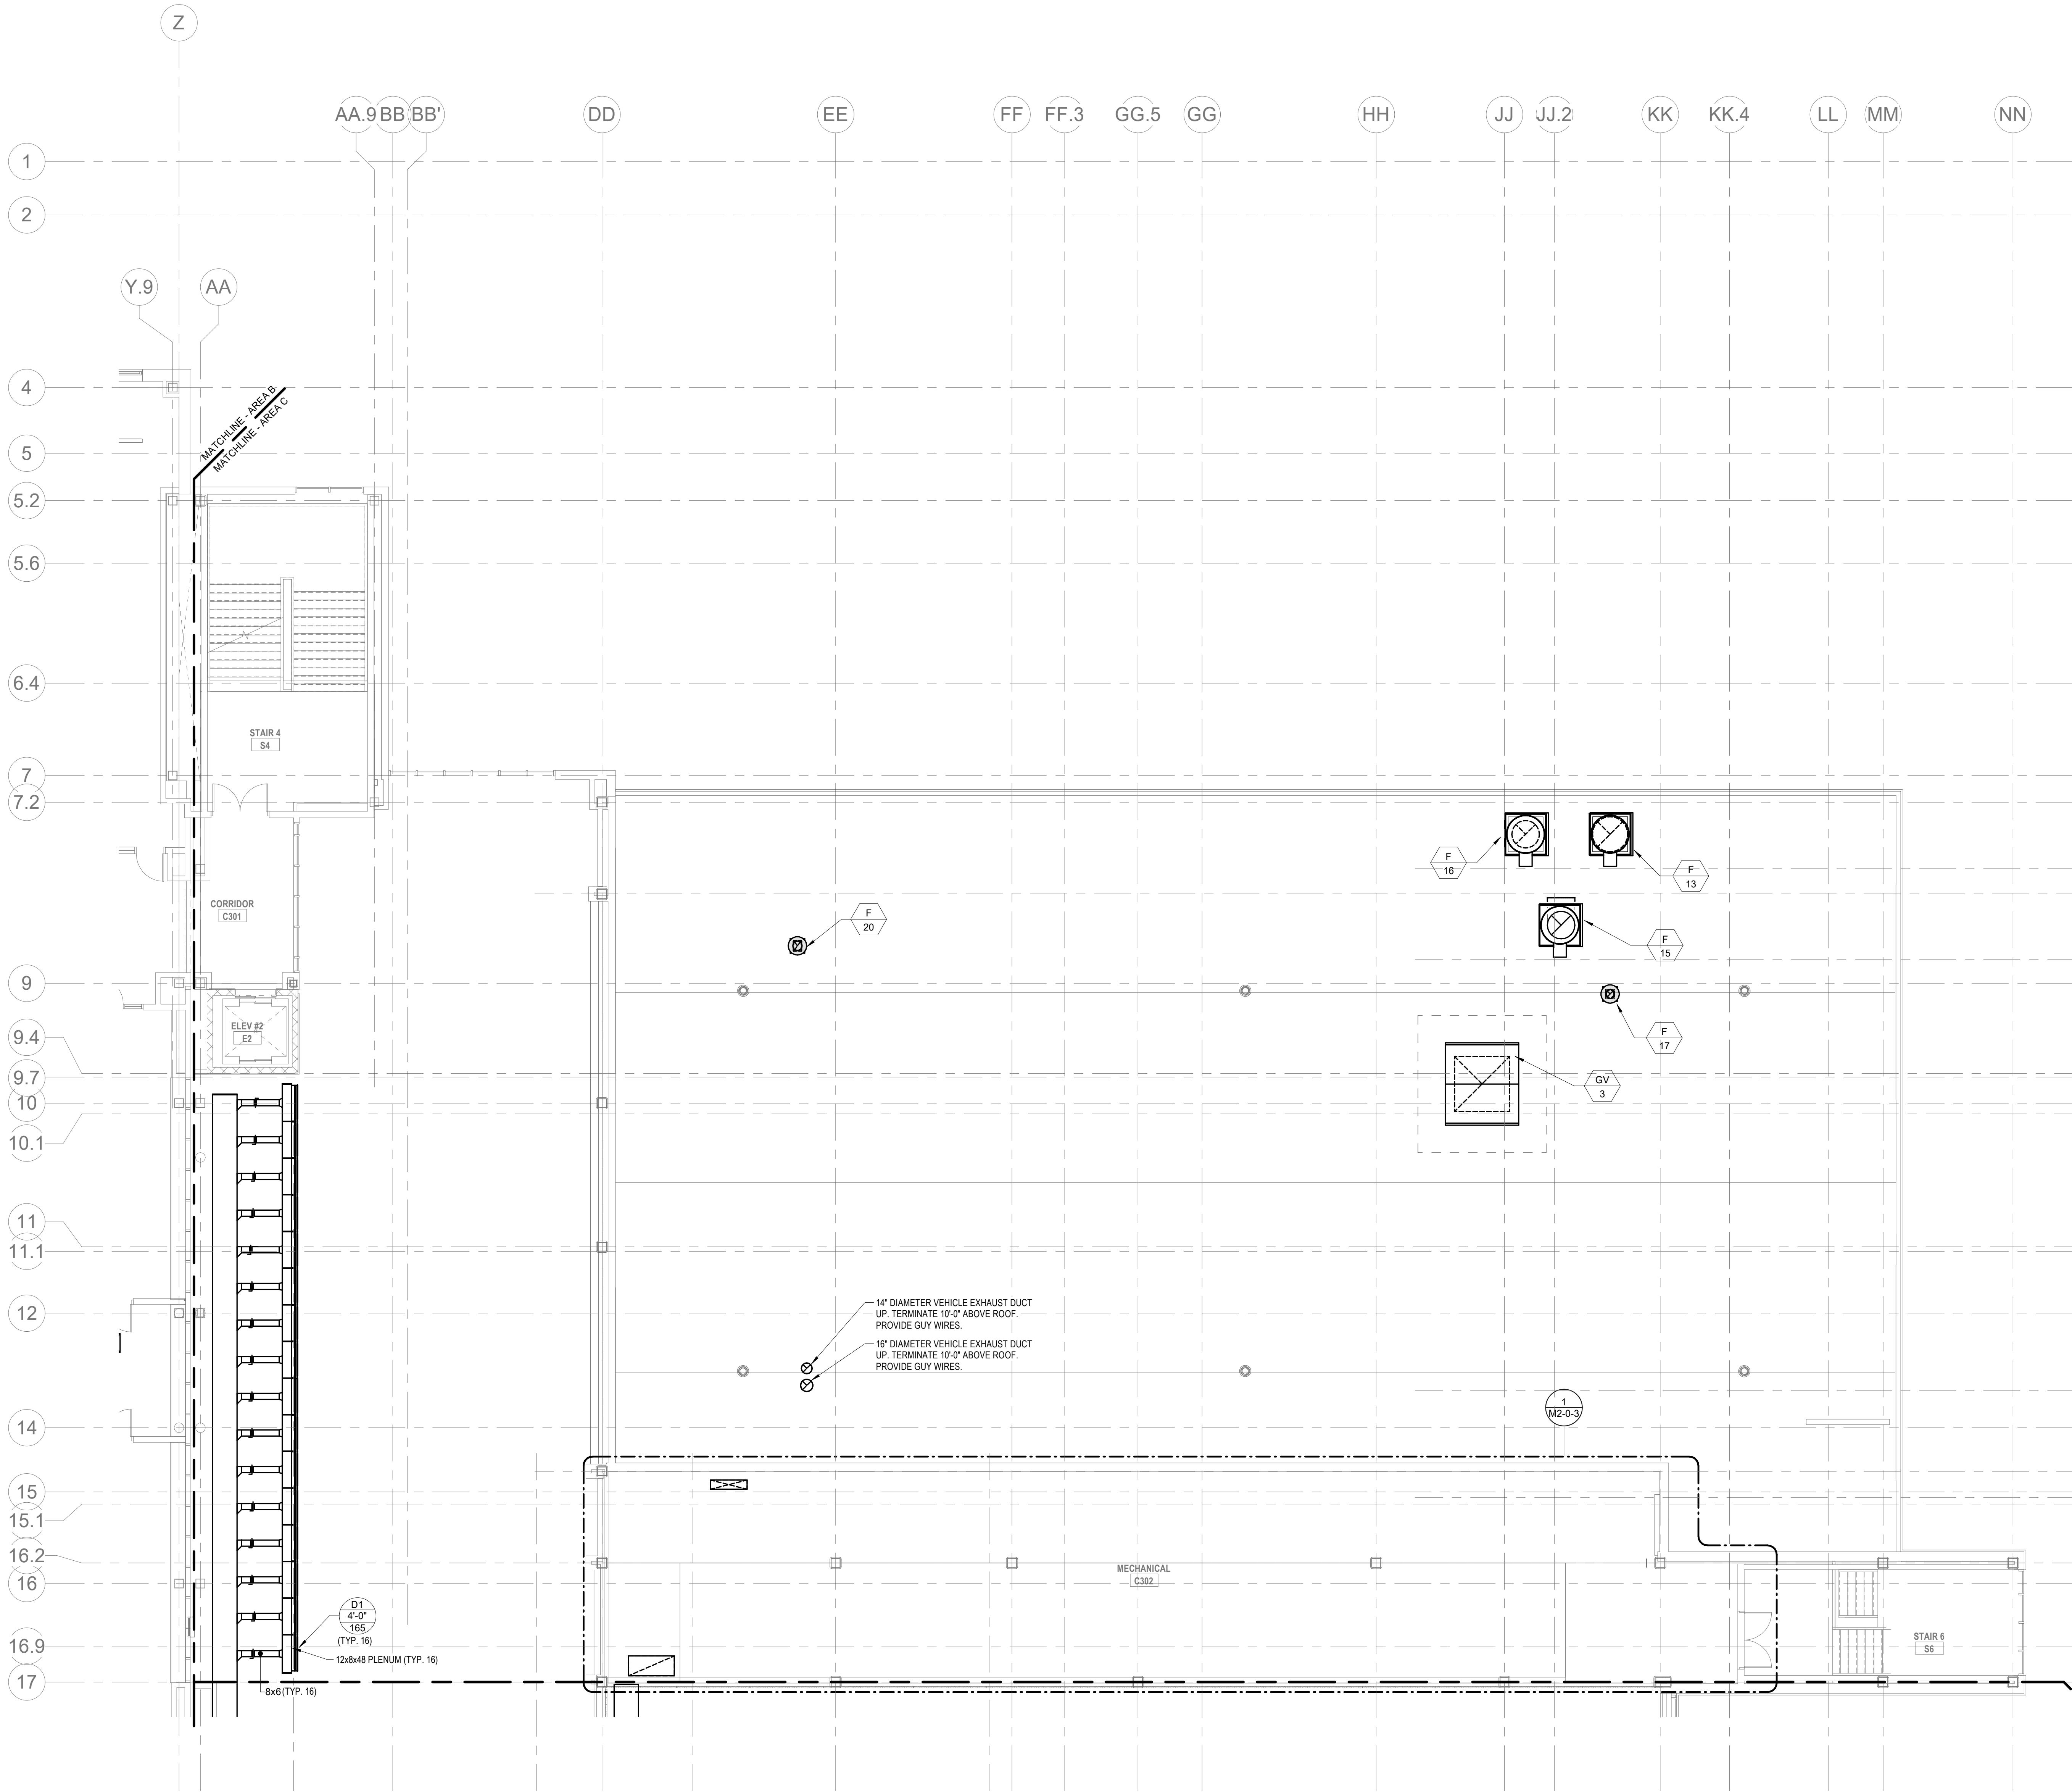


© COPYRIGHT 2021 DRUMME ROSANE ANDERSON, INC.

BALA
ENGINEERS
BALA CONSULTING ENGINEERS, INC.
300 WASHINGTON STREET
SUITE 200
BOSTON, MA 02108
TEL: 617.552.1234 FAX: 617.552.1235
WWW.BALA-ENG.COM


MSBA 60% CD
SUBMISSION

January 13, 2023

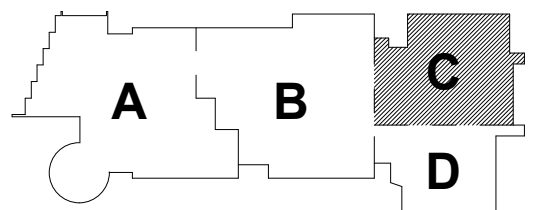

KEY PLAN

PROJECT NORTH MAGNETIC NORTH

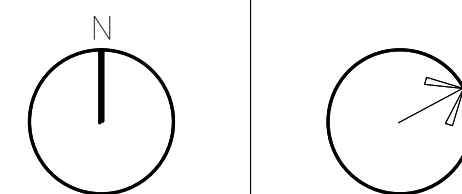

MECHANICAL
DUCTWORK
THIRD FLOOR
PLAN - AREA C

Scale: 1/8" = 1'-0"
Job No.: 20202
Drawn By: DRA
Date: January 13, 2023

M1-1-3C

HVAC DRAWING NOTES

1.

DRA


Drummeey Rosane Anderson, Inc.
225 Oakland Road
Studio 205
South Windsor, CT
06074

280 Charles Street
Studio 300
Waltham, MA
02453

Planning | Architecture | Interior Design
Tel: 617.984.1700
www.draa.com

Northeast
Metropolitan
Regional
Vocational High
School

Wakefield, MA 01880

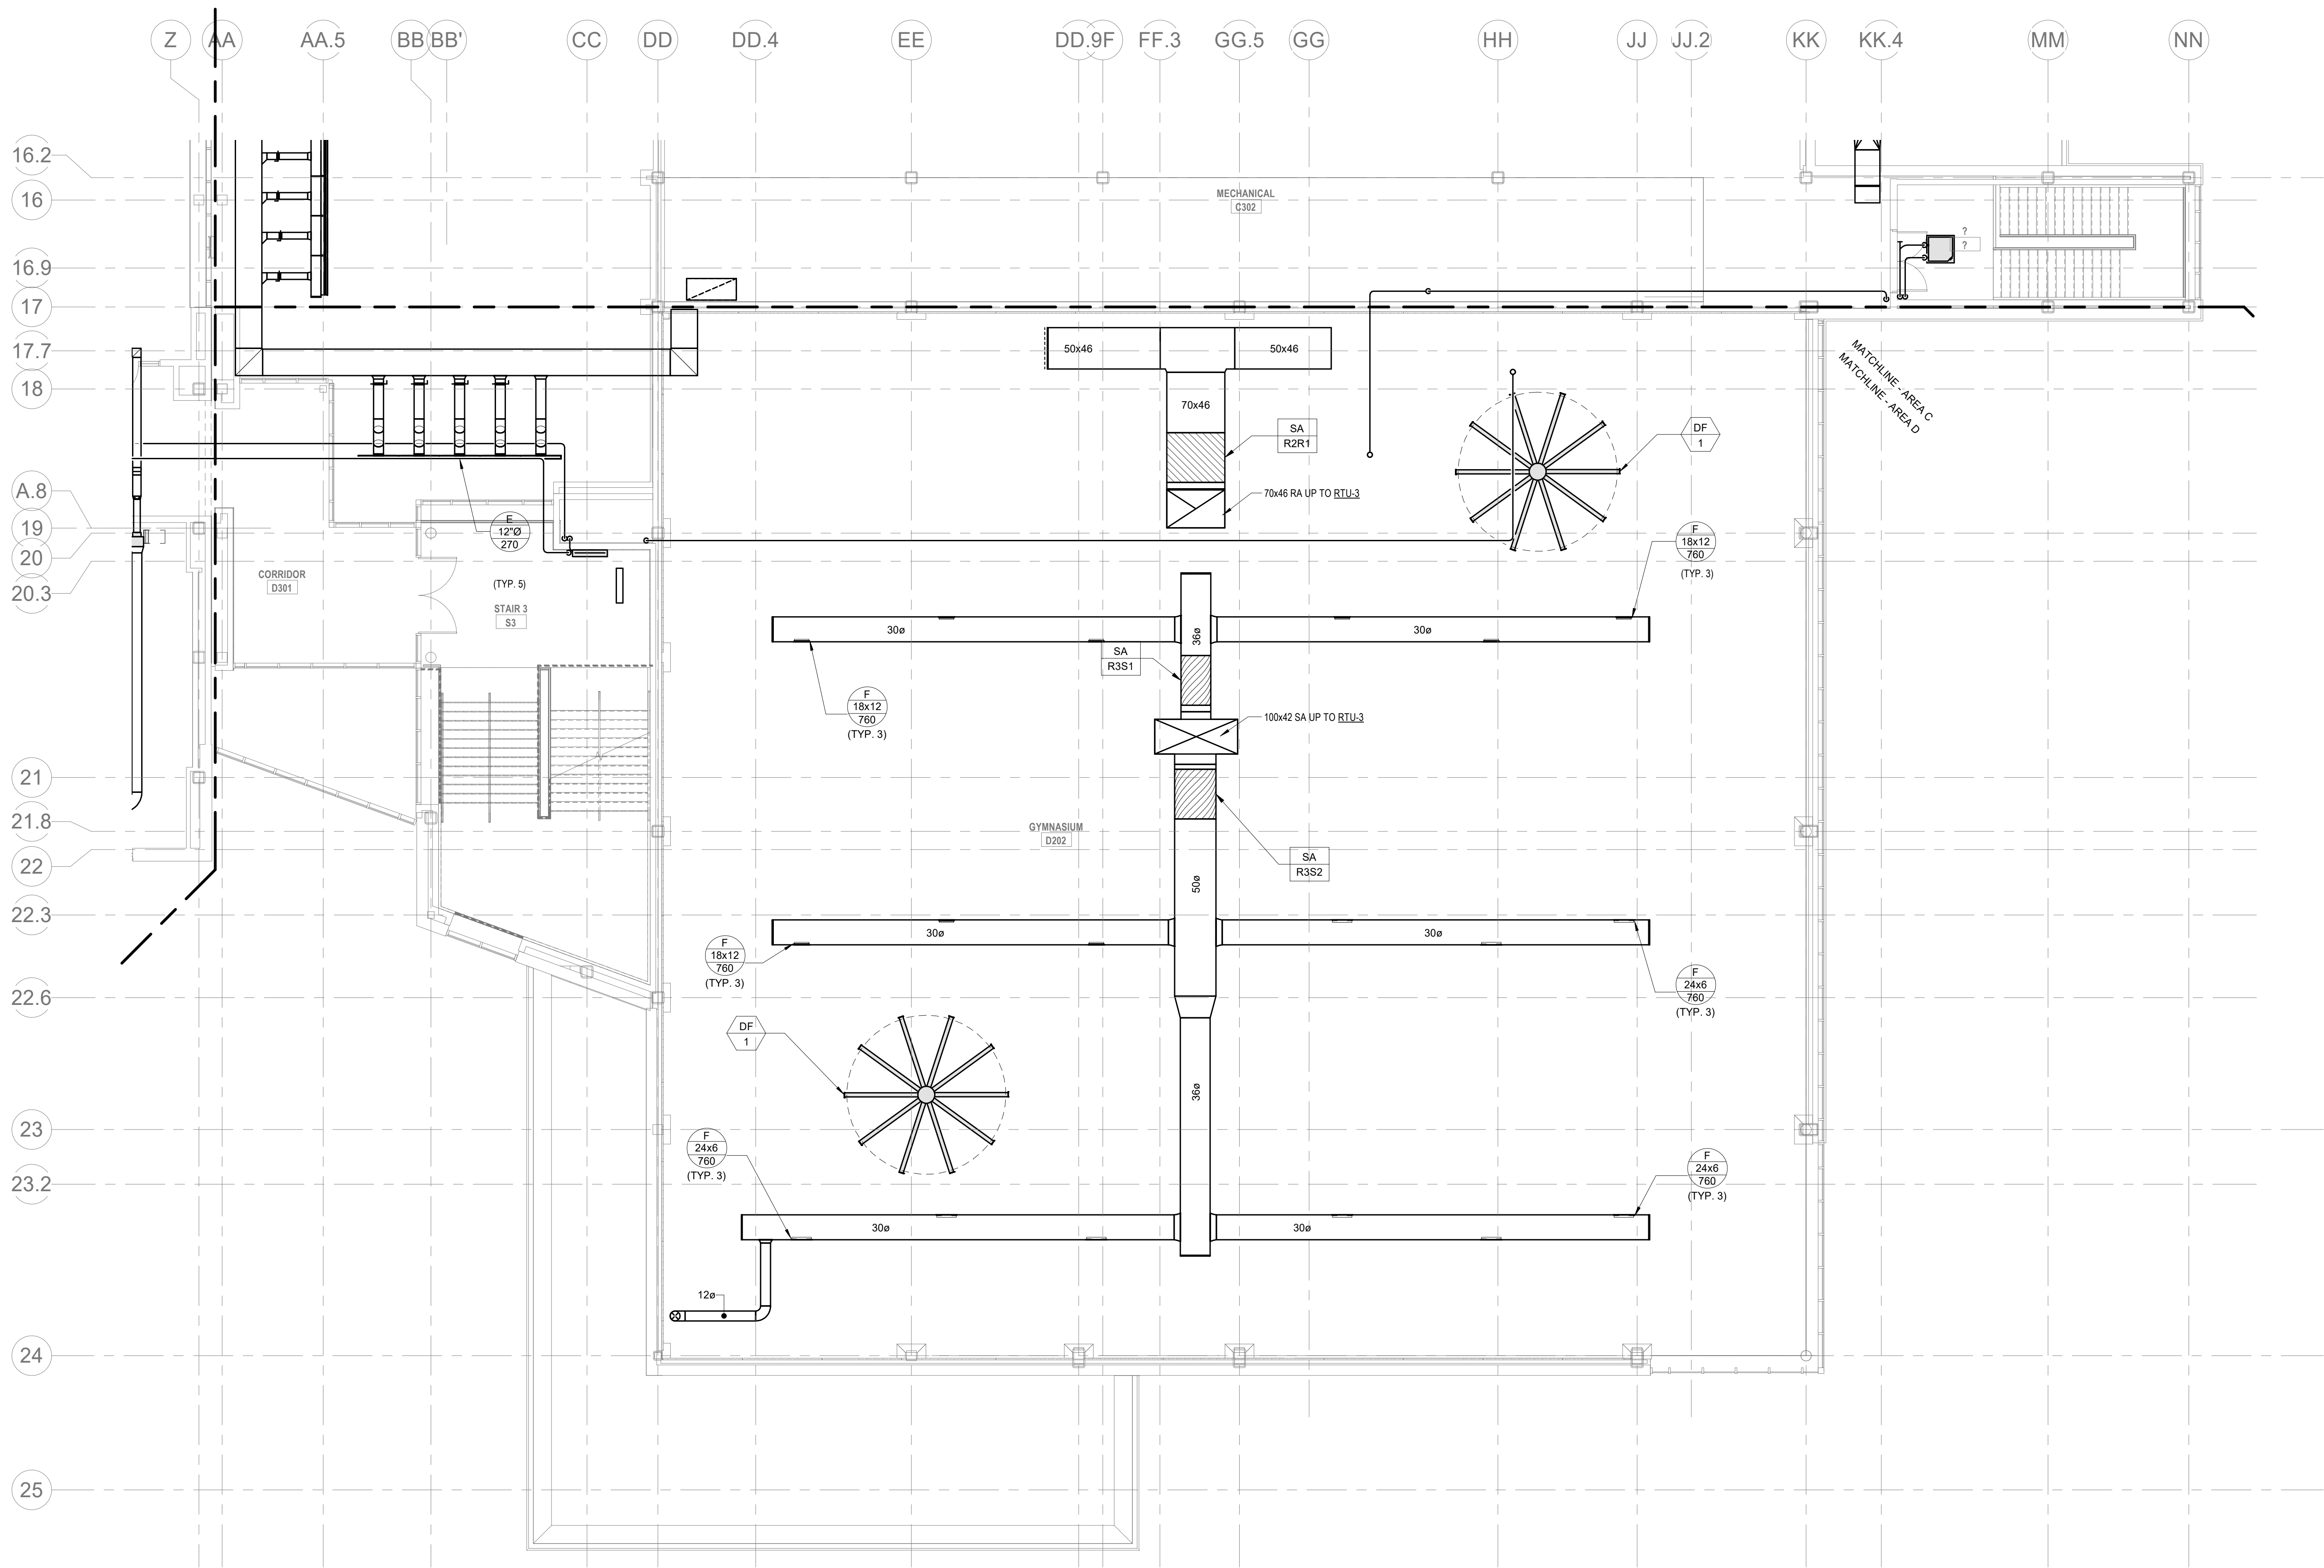


© COPYRIGHT 2021 DRUMMEY ROSANE ANDERSON, INC.

BALA
ENGINEERS
BALA CONSULTING ENGINEERS, INC.
200 WEST 10TH STREET
SUITE 200
NEW YORK, NY 10011
TEL: 212.693.1234 FAX: 212.693.1235
WWW.BALA-ENGINEERS.COM


MSBA 60% CD
SUBMISSION

January 13, 2023

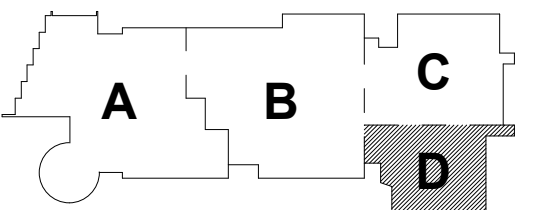


KEY PLAN

PROJECT NORTH

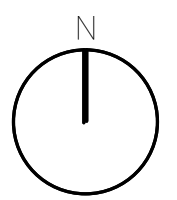

MAGNETIC NORTH

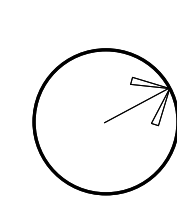

MECHANICAL
DUCTWORK
THIRD FLOOR
PLAN - AREA D


Scale: 1/8" = 1'-0"

Job No.: 20202

Drawn By: DRA

Date: January 13, 2023

M1-1-3D

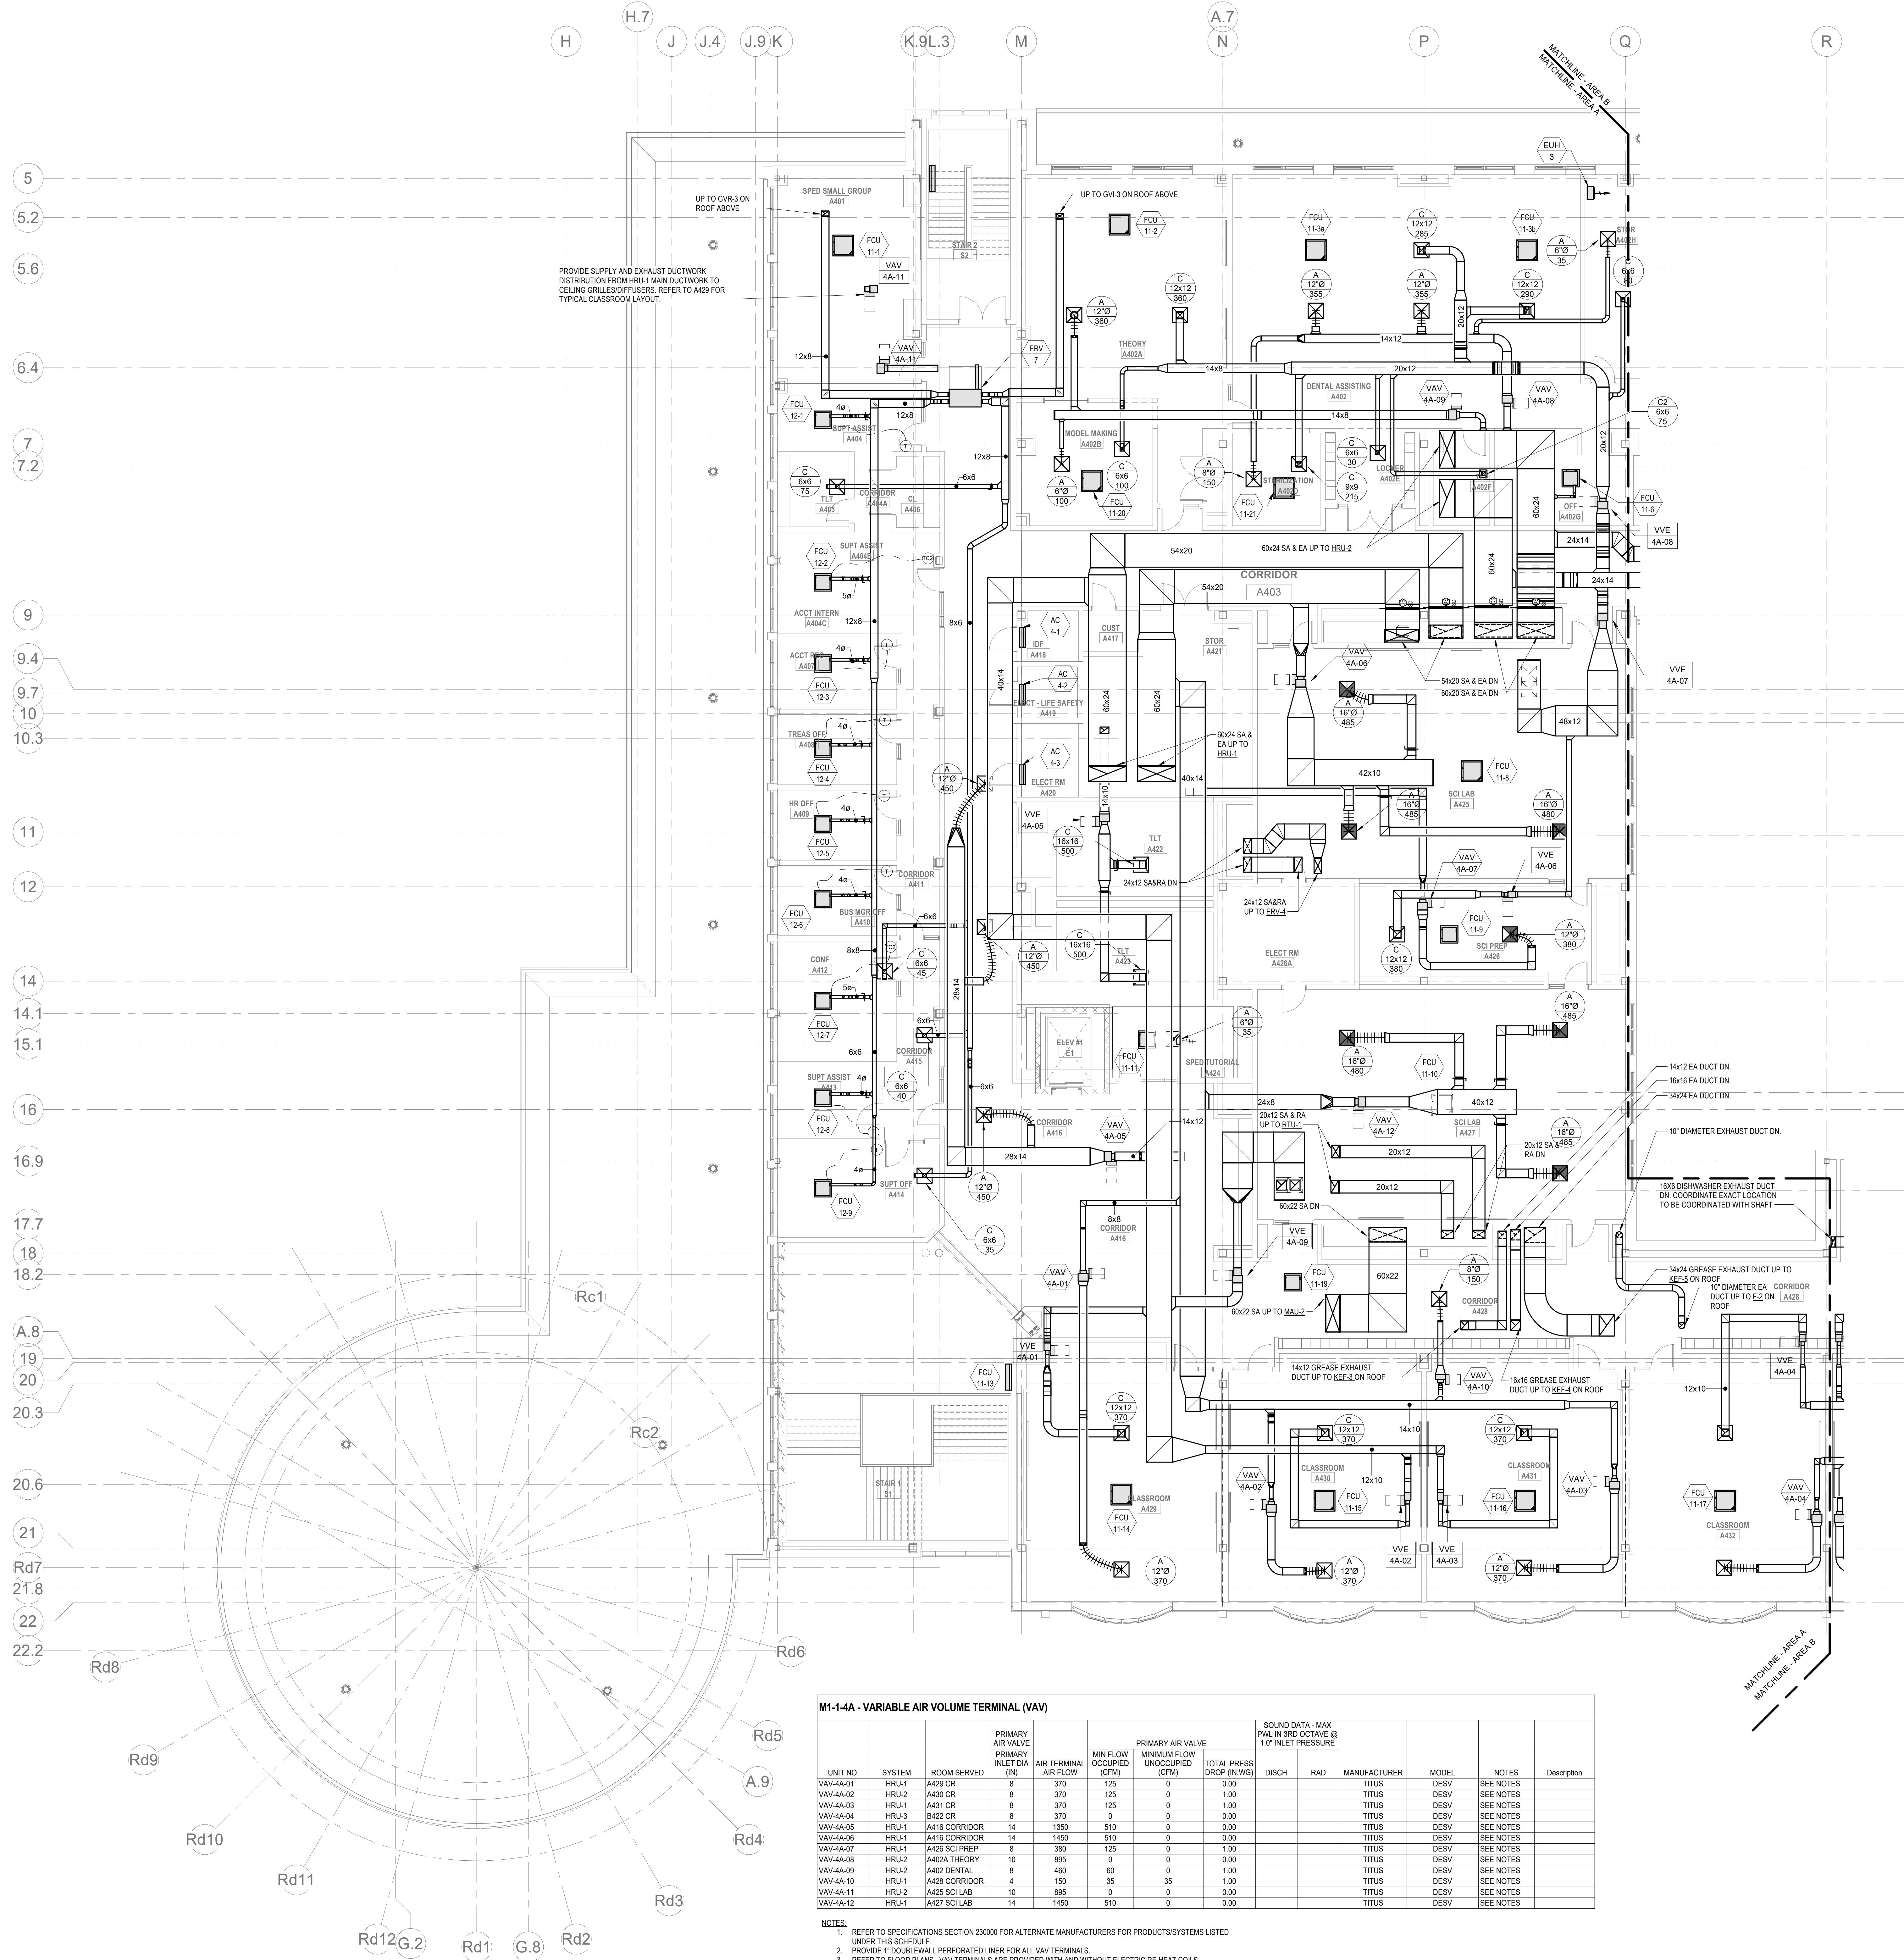


M1-1-4A - VARIABLE AIR VOLUME TERMINAL (VAV)									
UNIT NO	SYSTEM	ROOM SERVED	PRIMARY AIR VALVE INLET DIA (IN)	AIR TERMINAL AIR FLOW (CFM)	MIN FLOW OCCUPIED (CFM)	PRIMARY AIR VALVE UNOCCUPIED (CFM)	TOTAL PRESS DROP (IN WG)	SOUND DATA - MAX PWL IN 8RD OCTAVE @ 1.0' INLET PRESSURE	
VAV-4A-01	HRU-1	A401 CR	8	370	125	0	1.00		
VAV-4A-02	HRU-2	A402 CR	8	370	125	0	1.00		
VAV-4A-03	HRU-1	A403 CR	8	370	125	0	1.00		
VAV-4A-04	HRU-3	A404 CR	8	370	0	0.00			
VAV-4A-05	HRU-1	A405 CORRIDOR	14	1350	510	0	0.00		
VAV-4A-06	HRU-1	A406 CORRIDOR	14	1450	510	0	0.00		
VAV-4A-07	HRU-1	A407 SCI PREP	8	380	125	0	1.00		
VAV-4A-08	HRU-2	A408 THEORY	10	885	0	0.00			
VAV-4A-09	HRU-2	A409 DENTAL	8	460	80	0	1.00		
VAV-4A-10	HRU-1	A410 CORRIDOR	4	150	35	35	1.00		
VAV-4A-11	HRU-2	A411 SCI LAB	10	885	0	0.00			
VAV-4A-12	HRU-1	A412 SCI LAB	14	1450	510	0	0.00		

- NOTES:
- REFER TO SPECIFICATIONS SECTION 230000 FOR ALTERNATE MANUFACTURERS FOR PRODUCTS/SYSTEMS LISTED UNDER THIS SCHEDULE.
 - PROVIDE 1" DOUBLEWALL PERFORATED LINER FOR ALL VAV TERMINALS.
 - REFER TO FLOOR PLANS. VAV TERMINALS ARE PROVIDED WITH AND WITHOUT ELECTRIC REHEAT COILS.
 - CONFIRM LEFT OR RIGHT HAND CONTROL LOCATION IN THE FIELD.
 - PROVIDE INLET VELOCITY SENSOR.
 - PROVIDE 1" LINER FOR 15'-0" DOWNSTREAM OF ALL VAV BOXES.
 - SCHEDULE TOTAL PRESSURE DROP ACROSS PRIMARY AIR VALVE IS APPLICABLE AT MAXIMUM AIRFLOW SETPOINT.
 - CONTROLS AND CONTROLLER TO BE PROVIDED BY ATC CONTRACTOR.

M1-1-4A VARIABLE AIR VOLUME EXHAUST AIR TERMINAL SCHEDULE (VVE)									
UNIT NO	TYPE	INLET DIAMETER (IN)	MAX AIRFLOW (CFM)	MIN. TURNDOWN (CFM)	MANUFACTURER	MODEL	REMARKS		
VVE-4A-01	SINGLE DUCT EXHAUST	6	0	125	TITUS	DESV			
VVE-4A-02	SINGLE DUCT EXHAUST	6	0	125	TITUS	DESV			
VVE-4A-03	SINGLE DUCT EXHAUST	6	0	125	TITUS	DESV			
VVE-4A-04	SINGLE DUCT EXHAUST	6	0	125	TITUS	DESV			
VVE-4A-05	SINGLE DUCT EXHAUST	10	0	600	TITUS	DESV			
VVE-4A-06	SINGLE DUCT EXHAUST	6	0	125	TITUS	DESV			
VVE-4A-07	SINGLE DUCT EXHAUST	12	0	125	TITUS	DESV			
VVE-4A-08	SINGLE DUCT EXHAUST	10	0	240	TITUS	DESV			
VVE-4A-09	SINGLE DUCT EXHAUST	12	0	1400	TITUS	DESV			
VVE-4A-10	SINGLE DUCT EXHAUST	8	0	125	TITUS	DESV			

- NOTES:
- REFER TO SPECIFICATIONS SECTION 230000 FOR ALTERNATE MANUFACTURERS FOR PRODUCTS/SYSTEMS LISTED UNDER THIS SCHEDULE.
 - PROVIDE 1" DOUBLEWALL PERFORATED LINER FOR ALL VAV TERMINALS.
 - CONFIRM LEFT OR RIGHT HAND CONTROL LOCATION IN THE FIELD.
 - PROVIDE INLET VELOCITY SENSOR.
 - PROVIDE 1" LINER FOR 15'-0" DOWNSTREAM OF ALL VAV BOXES.
 - SCHEDULE TOTAL PRESSURE DROP ACROSS PRIMARY AIR VALVE IS APPLICABLE AT MAXIMUM AIRFLOW SETPOINT.
 - CONTROLS AND CONTROLLER TO BE PROVIDED BY ATC CONTRACTOR.

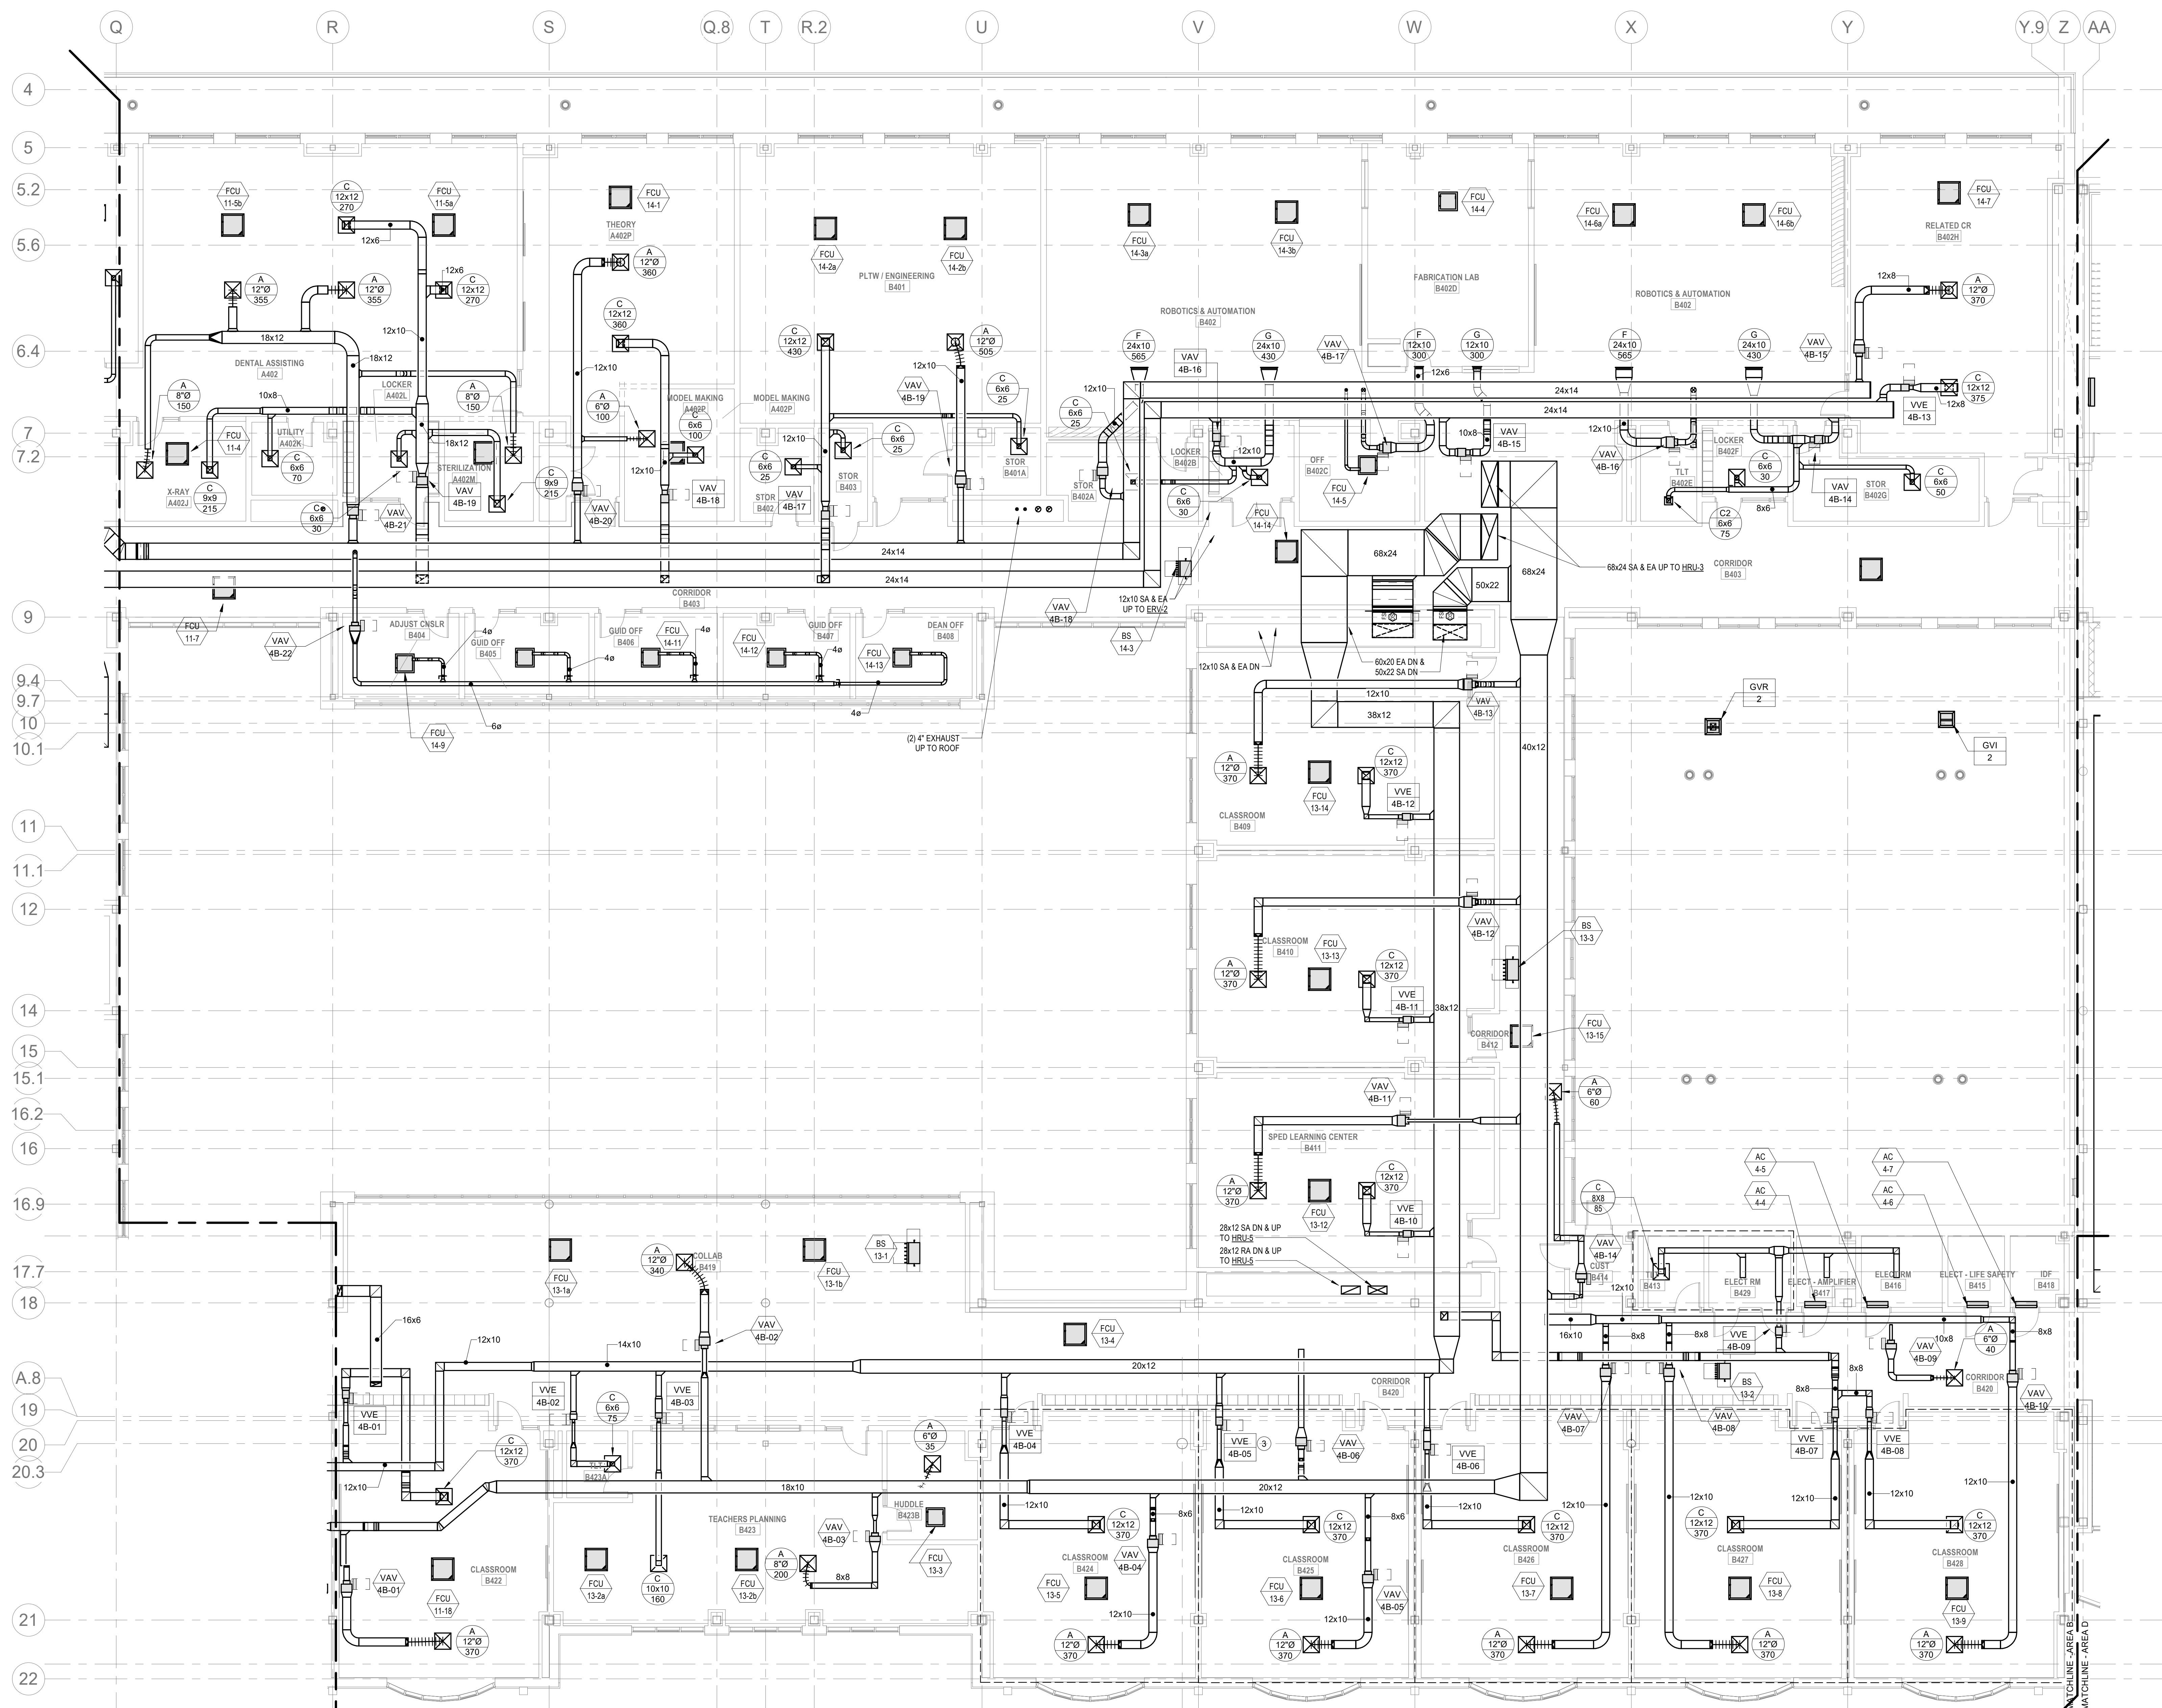

HVAC DRAWING NOTES

DRA

Drummet Rosane Anderson, Inc.
225 Oakland Road
Studio 205
South Windsor, CT
06074
Tel: 817.984.1702
www.dra.com

Northeast
Metropolitan
Regional
Vocational High
School


Wakefield, MA 01880

© COPYRIGHT 2021 DRUMMET ROSANE ANDERSON, INC.

BALA
ENGINEERS

MSBA 60% CD
SUBMISSION

January 13, 2023

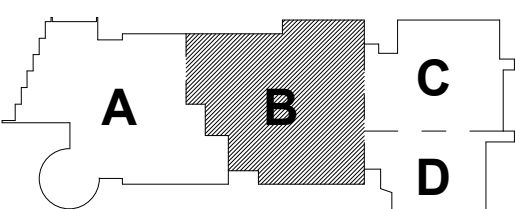

PROJECT NORTH

MAGNETIC NORTH

MECHANICAL
DUCTWORK
FOURTH FLOOR
PLAN - AREA B

Scale: 1/8" = 1'-0"

Job No.: 20202

Drawn By: DRA

Date: January 13, 2023

M1-1-4B

M1-1-4B VARIABLE AIR VOLUME EXHAUST AIR TERMINAL SCHEDULE (VVE)

UNIT NO	TYPE	INLET DIAMETER (IN)	MAX AIRFLOW (CFM)	MIN TURNDOWN (CFM)	MANUFACTURER	MODEL	REMARKS
VVE-4B-01	SINGLE DUCT EXHAUST	6	0	370	TITUS	DESV	
VVE-4B-02	SINGLE DUCT EXHAUST	4	0	75	TITUS	DESV	
VVE-4B-03	SINGLE DUCT EXHAUST	5	0	125	TITUS	DESV	
VVE-4B-04	SINGLE DUCT EXHAUST	6	0	125	TITUS	DESV	
VVE-4B-05	SINGLE DUCT EXHAUST	6	0	125	TITUS	DESV	
VVE-4B-06	SINGLE DUCT EXHAUST	6	0	125	TITUS	DESV	
VVE-4B-07	SINGLE DUCT EXHAUST	6	0	125	TITUS	DESV	
VVE-4B-08	SINGLE DUCT EXHAUST	6	0	125	TITUS	DESV	
VVE-4B-09	SINGLE DUCT EXHAUST	6	0	125	TITUS	DESV	
VVE-4B-10	SINGLE DUCT EXHAUST	6	0	125	TITUS	DESV	
VVE-4B-11	SINGLE DUCT EXHAUST	6	0	125	TITUS	DESV	
VVE-4B-12	SINGLE DUCT EXHAUST	6	0	125	TITUS	DESV	
VVE-4B-13	SINGLE DUCT EXHAUST	6	0	125	TITUS	DESV	
VVE-4B-14	SINGLE DUCT EXHAUST	8	0	105	TITUS	DESV	
VVE-4B-15	SINGLE DUCT EXHAUST	8	0	105	TITUS	DESV	
VVE-4B-16	SINGLE DUCT EXHAUST	8	0	105	TITUS	DESV	
VVE-4B-17	SINGLE DUCT EXHAUST	8	0	105	TITUS	DESV	
VVE-4B-18	SINGLE DUCT EXHAUST	8	0	105	TITUS	DESV	
VVE-4B-19	SINGLE DUCT EXHAUST	5	0	240	TITUS	DESV	

- NOTES:
- REFER TO SPECIFICATIONS SECTION 230000 FOR ALTERNATE MANUFACTURERS FOR PRODUCTS/SYSTEMS LISTED UNDER THIS SCHEDULE.
 - PROVIDE 1" DOUBLEWALL PERFORATED LINER FOR ALL VAV TERMINALS.
 - CONFIRM LEFT OR RIGHT HAND CONTROL LOCATION IN THE FIELD.
 - PROVIDE INLET VELOCITY SENSOR.
 - PROVIDE 1" UNER FOR 15" DOWNSTREAM OF ALL VAV BOXES.
 - SCHEDULE TOTAL PRESSURE DROP ACROSS PRIMARY AIR VALVE IS APPLICABLE AT MAXIMUM AIRFLOW SETPOINT.
 - CONTROLS AND CONTROLLER TO BE PROVIDED BY ATC CONTRACTOR.

M1-1-4B - VARIABLE AIR VOLUME TERMINAL (VAV)

UNIT NO	SYSTEM	ROOM SERVED	INLET DIA (IN)	Air Terminal	PRIMARY AIR VALVE			TOTAL PRESSURE DROP (IN.WG)	DISCH	RAD	MANUFACTURER	MODEL	NOTES
					MIN FLOW OCCUPIED (CFM)	MINIMUM FLOW UNOCCUPIED (CFM)	FLOW (CFM)						
VAV-4B-01	HRU-3	B422 CR	6	370	0	0	0	0.00			TITUS	DESV	SEE NOTES
VAV-4B-02	HRU-3	B419 COLLAS	6	340	30	70	1.00				TITUS	DESV	SEE NOTES
VAV-4B-03	HRU-3	B423 PLANNING	4	200	35	35	1.00				TITUS	DESV	SEE NOTES
VAV-4B-04	HRU-3	B425 CR	6	370	0	0	0.00				TITUS	DESV	SEE NOTES
VAV-4B-05	HRU-3	B425 CR	8	370	0	0	0.00				TITUS	DESV	SEE NOTES
VAV-4B-06	HRU-3	B426 CR	8	370	125	0	0.00				TITUS	DESV	SEE NOTES
VAV-4B-07	HRU-3	B426 CR	8	370	0	0	0.00				TITUS	DESV	SEE NOTES
VAV-4B-08	HRU-3	B427 CR	8	370	0	0	0.00				TITUS	DESV	SEE NOTES
VAV-4B-09	HRU-3	B428 CORRIDOR	4	200	35	35	1.00				TITUS	DESV	SEE NOTES
VAV-4B-10	HRU-3	B428 CR	8	370	0	0	0.00				TITUS	DESV	SEE NOTES
VAV-4B-11	HRU-3	B411 SLC	8	370	0	0	0.00				TITUS	DESV	SEE NOTES
VAV-4B-12	HRU-3	B410 CR	8	370	0	0	0.00				TITUS	DESV	SEE NOTES
VAV-4B-13	HRU-3	B409 CR	8	370	0	0	0.00				TITUS	DESV	SEE NOTES
VAV-4B-14	HRU-3	B414 CUST	4	60	35	35	1.00				TITUS	DESV	SEE NOTES
VAV-4B-15	HRU-2	B4021	8	370	0	0	0.00				TITUS	DESV	SEE NOTES
VAV-4B-16	HRU-2	B402 ROBOTICS	8	565	0	0	0.00				TITUS	DESV	SEE NOTES
VAV-4B-17	HRU-2	B4020 FAB LAB	8	500	0	0	0.00				TITUS	DESV	SEE NOTES
VAV-4B-18	HRU-2	B402 ROBOTICS	8	565	0	0	0.00				TITUS	DESV	SEE NOTES
VAV-4B-19	HRU-2	B401 PLTW ENG	8	505	0	0	0.00				TITUS	DESV	SEE NOTES
VAV-4B-20	HRU-2	B401 PLTW ENG	8	460	0	0	0.00				TITUS	DESV	SEE NOTES
VAV-4B-21	HRU-2	B402 A402	6	1010	0	0	0.00				TITUS	DESV	SEE NOTES
VAV-4B-22	HRU-1	B402	6	200	60	0	1.00				TITUS	DESV	SEE NOTES


- NOTES:
- REFER TO SPECIFICATIONS SECTION 230000 FOR ALTERNATE MANUFACTURERS FOR PRODUCTS/SYSTEMS LISTED UNDER THIS SCHEDULE.
 - PROVIDE 1" DOUBLEWALL PERFORATED LINER FOR ALL VAV TERMINALS.
 - REFER TO FLOOR PLANS. VAV TERMINALS ARE PROVIDED WITH AND WITHOUT ELECTRIC RE-HEAT COILS.
 - CONFIRM LEFT OR RIGHT HAND CONTROL LOCATION IN THE FIELD.
 - PROVIDE INLET VELOCITY SENSOR.
 - PROVIDE 1" UNER FOR 15" DOWNSTREAM OF ALL VAV BOXES.
 - SCHEDULE TOTAL PRESSURE DROP ACROSS PRIMARY AIR VALVE IS APPLICABLE AT MAXIMUM AIRFLOW SETPOINT.
 - CONTROLS AND CONTROLLER TO BE PROVIDED BY ATC CONTRACTOR.




Drumme Rosane Anderson, Inc.
225 Oakland Road
Studio 205
South Windsor, CT 06074
260 Charles Street
Studio 300
Waltham, MA 02453
Planning | Architecture | Interior Design
Tel: 617.984.1700
www.draa.com

Northeast
Metropolitan
Regional
Vocational High
School


Wakefield, MA 01880

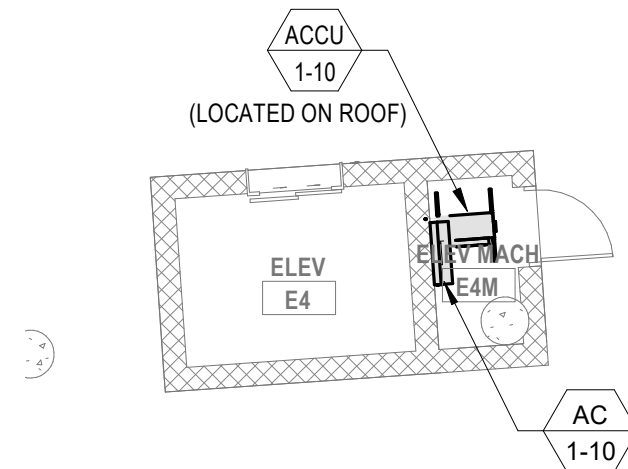

2 MECHANICAL Stadium Elevator (ADD ALTERNATE)
1/8" = 1'-0"

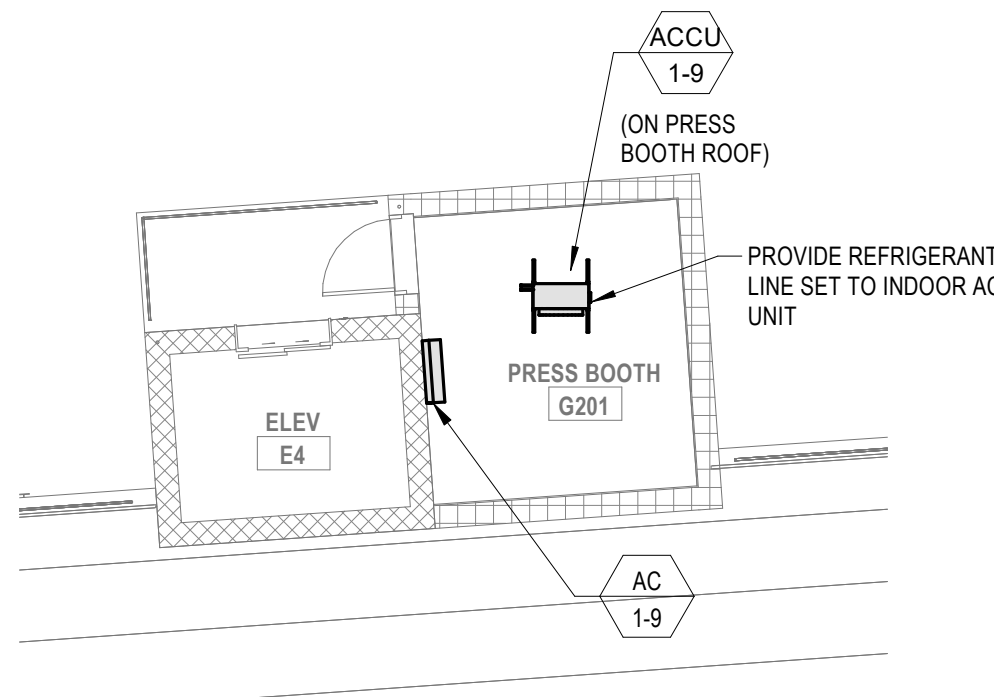

3 MECHANICAL Stadium Press Box (ADD ALTERNATE)
1/8" = 1'-0"

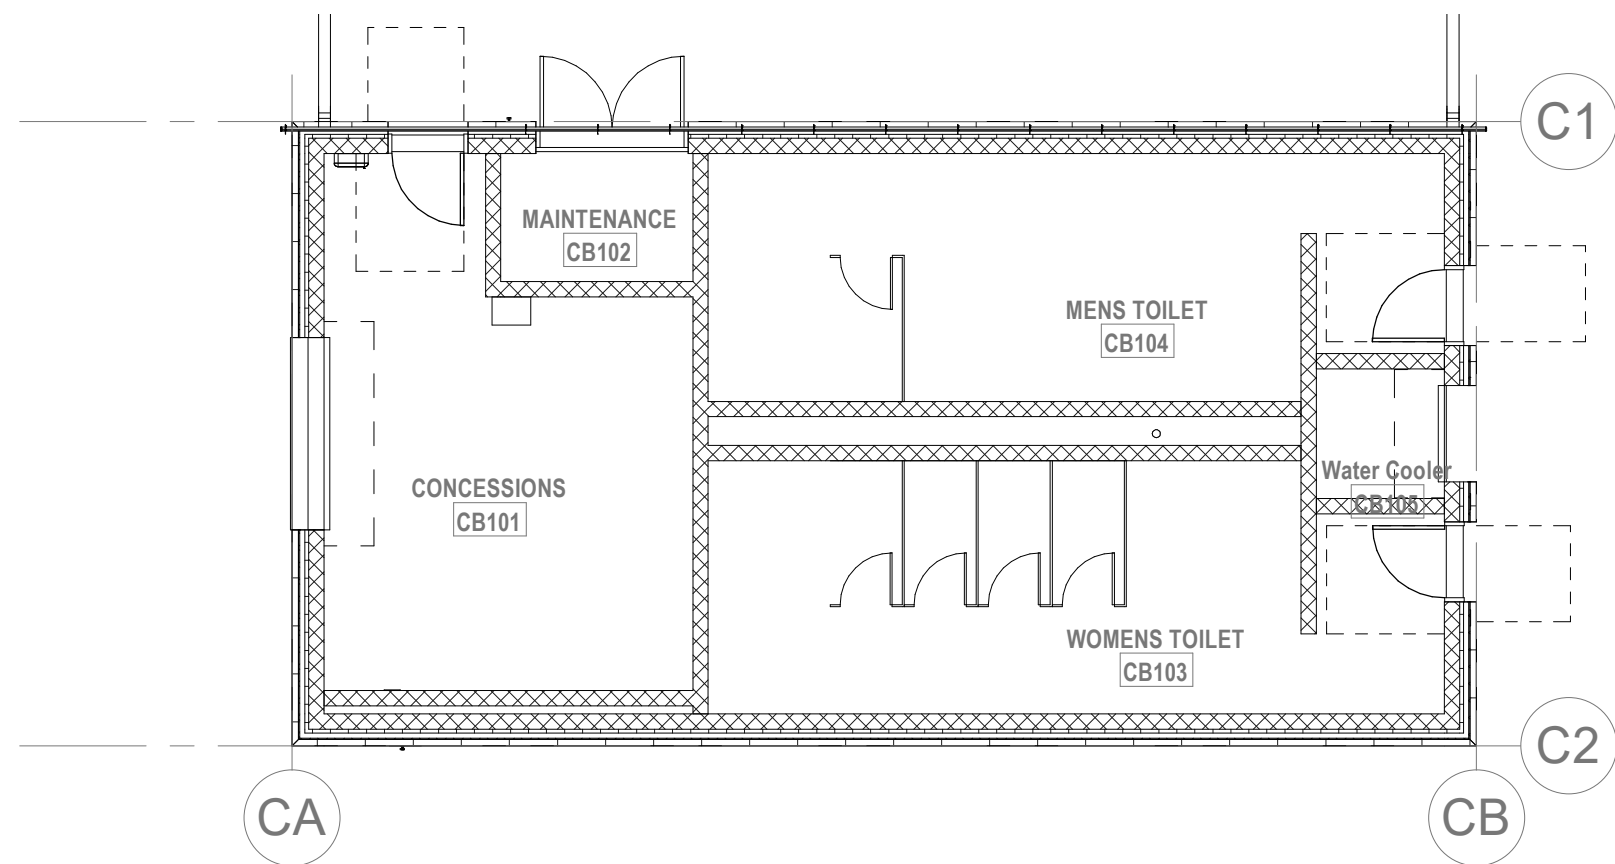


1 MECHANICAL Concessions Building (ADD ALTERNATE)
1/8" = 1'-0"

© COPYRIGHT 2021 DRUMMEY ROSANE ANDERSON, INC.

BALA
ENGINEERS
BALA CONSULTING ENGINEERS, INC.
200 WEST 14TH STREET, SUITE 200
NEW YORK, NY 10011-4209
TEL: 212.693.1234 FAX: 212.693.1235
WWW.BALA-ENG.COM

DESIGNED: CONCEPT: DRAWN: CHECKED: DATE: 01/13/23

MSBA 60% CD
SUBMISSION
January 13, 2023

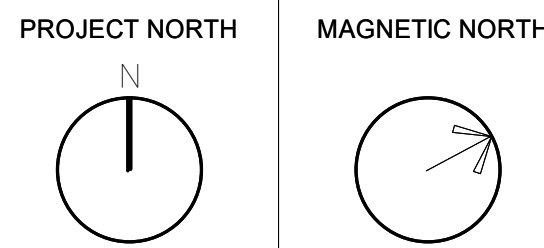


MECHANICAL
CONCESSION
BUILDING PLAN

Scale: 1/8" = 1'-0"
Job No.: 20202
Drawn By: DRA
Date: January 13, 2023
M1-1-CB




**Northeast
Metropolitan
Regional
Vocational High
School**

Wakefield, MA 01880

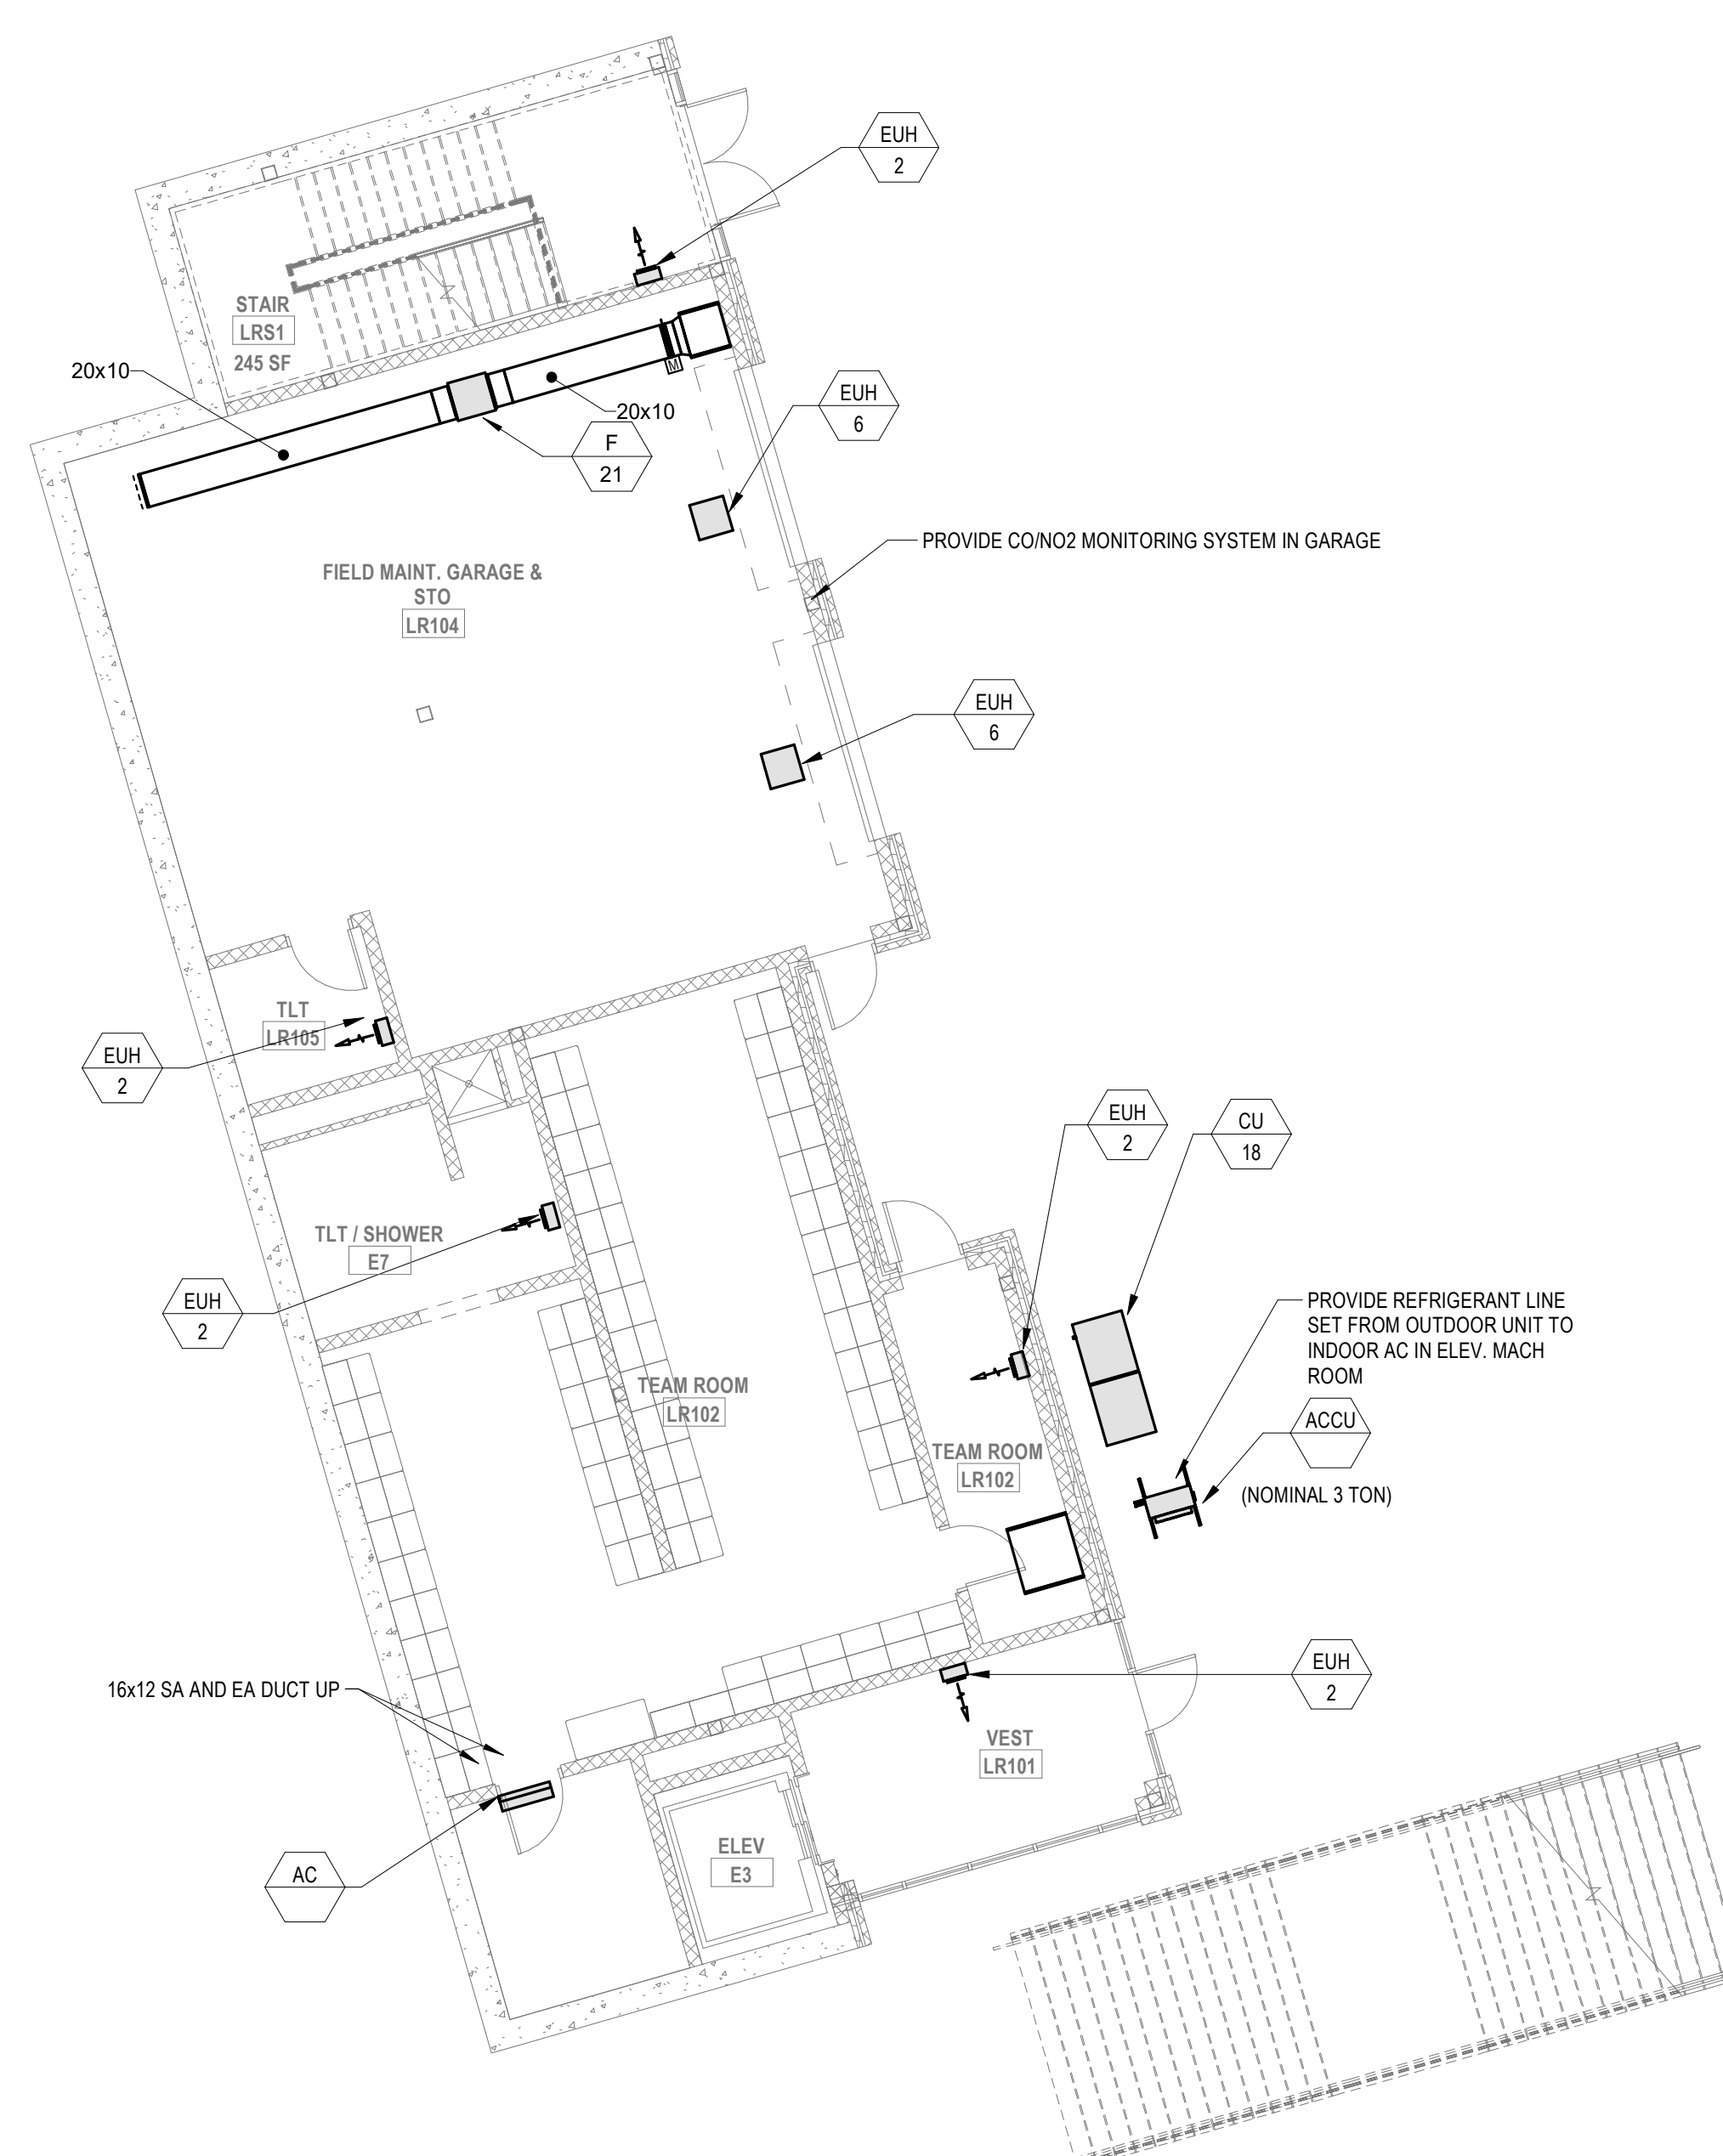

MECHANICAL Locker Building First Floor (ADD ALTERNATE)

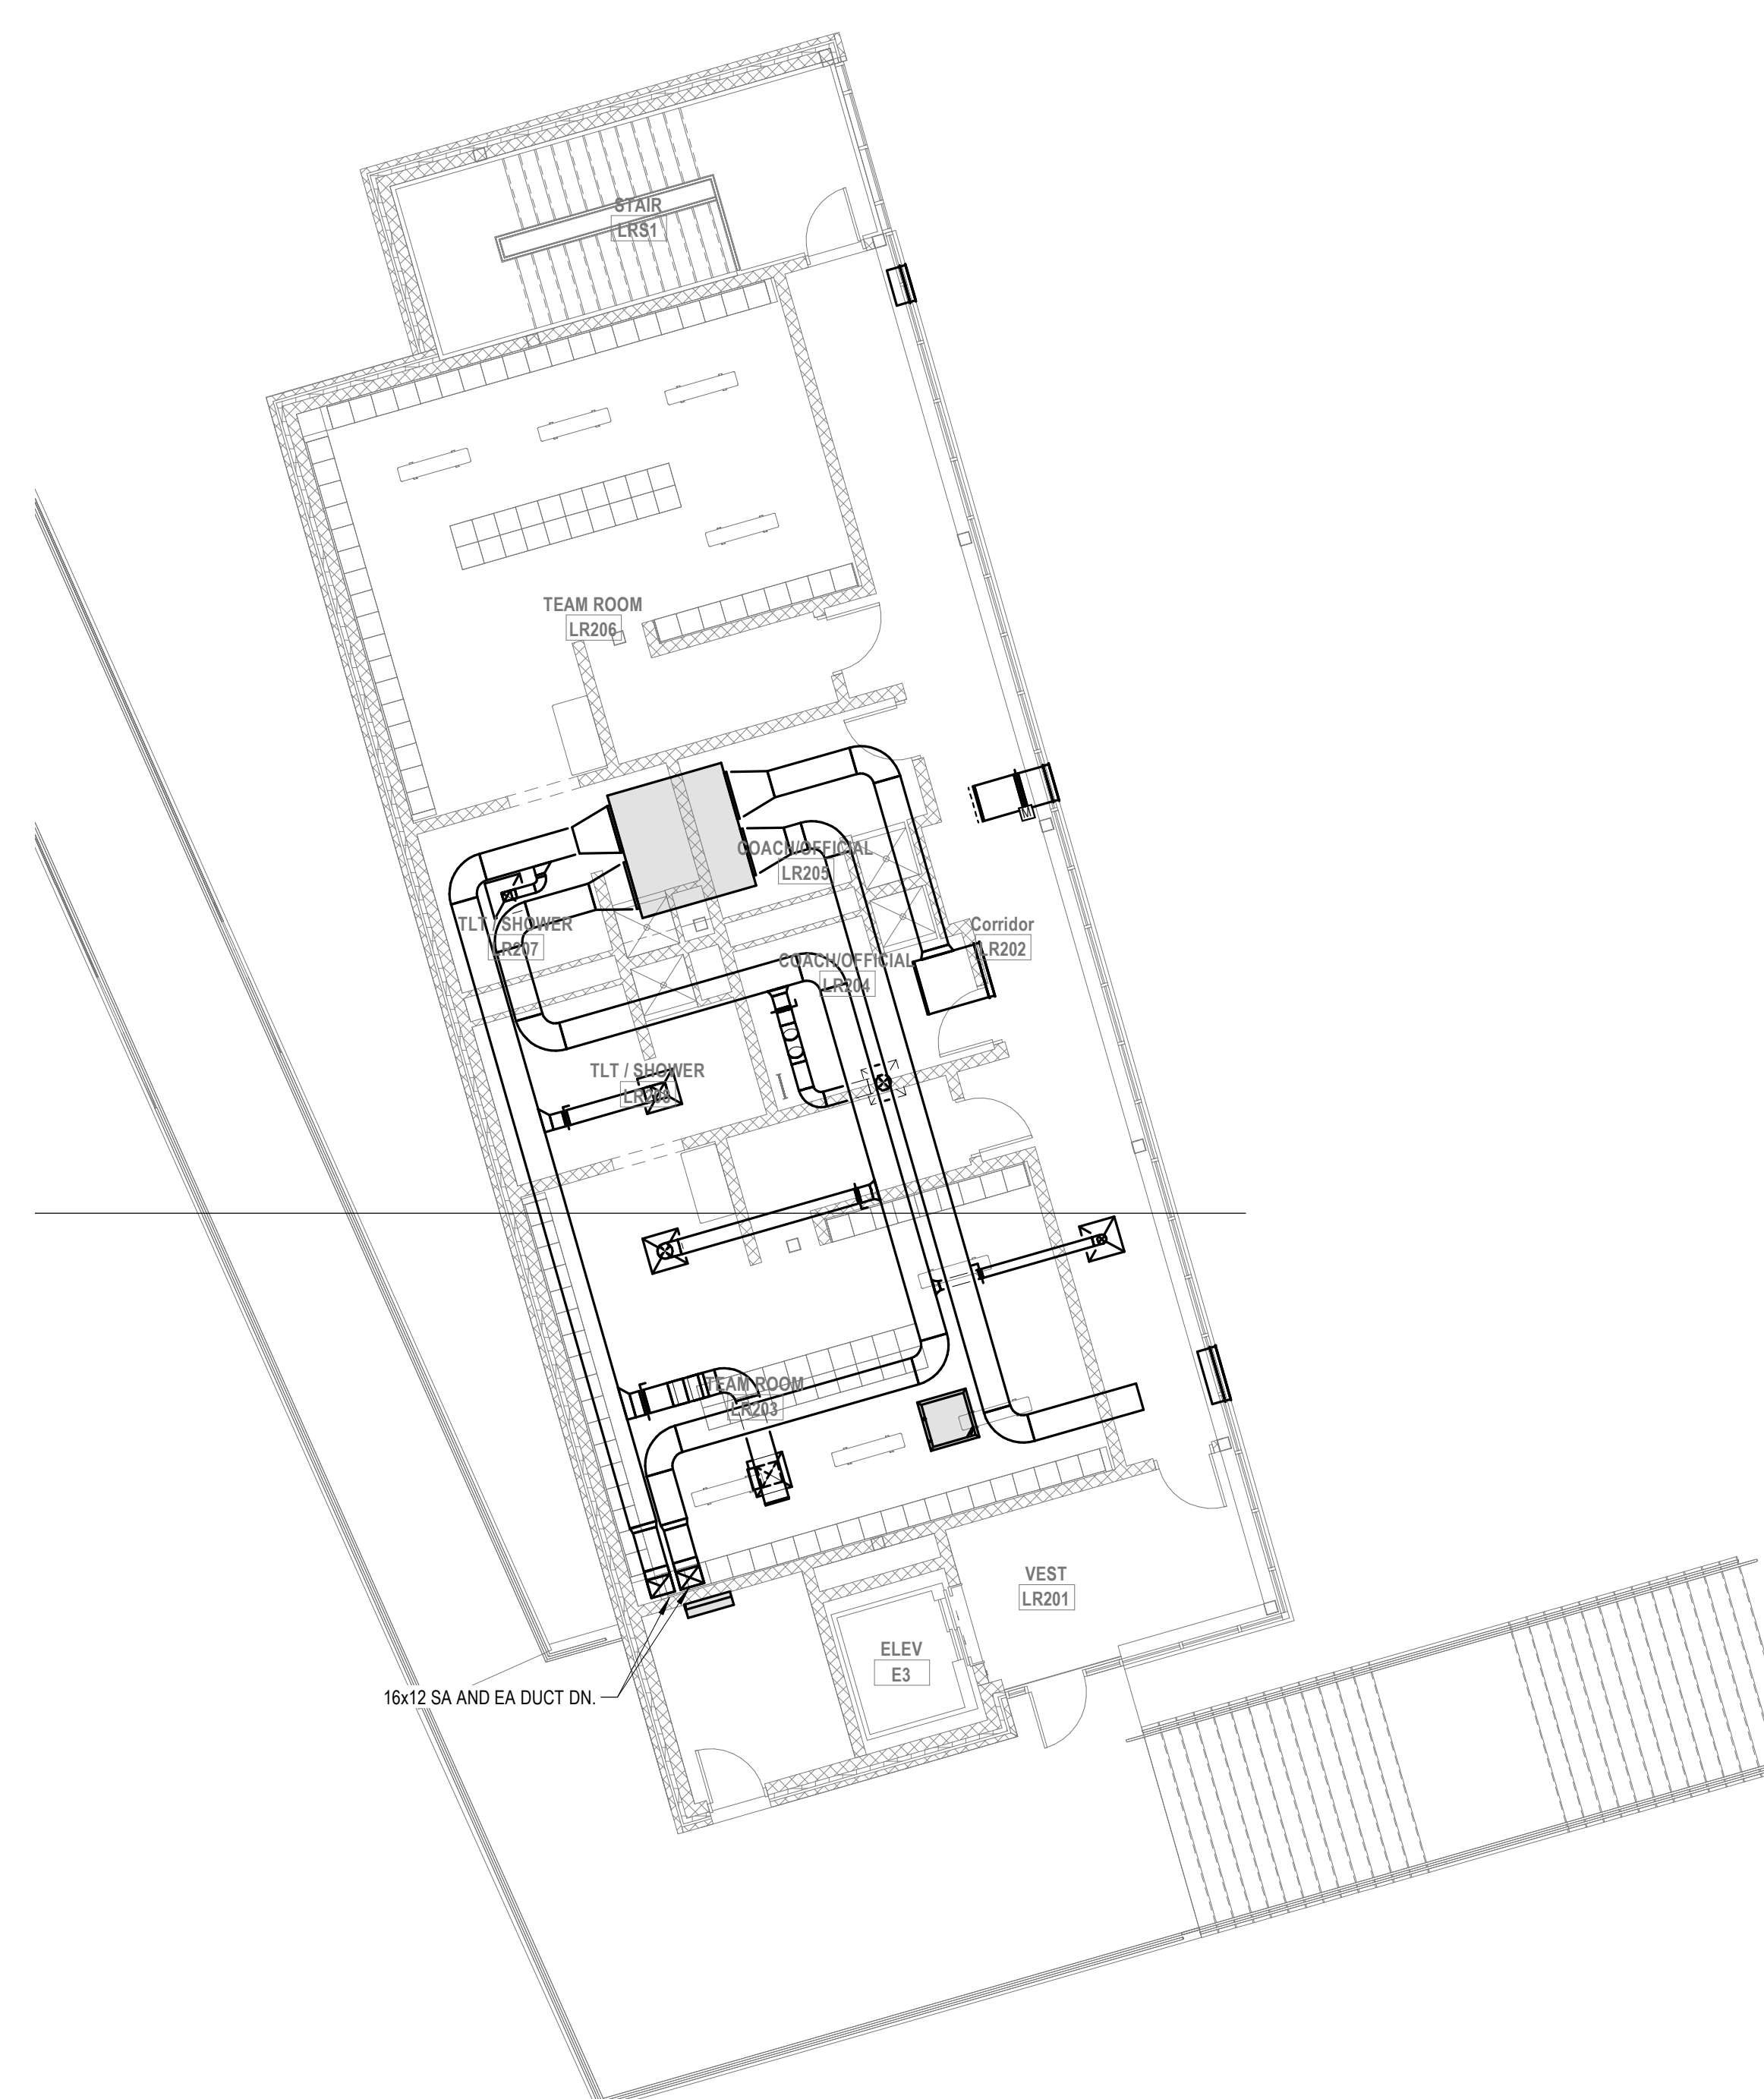


2 MECHANICAL Locker Building Second Level (ADD ALTERNATE)
M1-1-LB 1/8" = 1'-0"

© COPYRIGHT 2021 DRIMMEY ROSANE ANDERSON INC.


BALA
ENGINEERSMSBA 60% CD
SUBMISSION

January 13, 2023

PROJECT NORTH

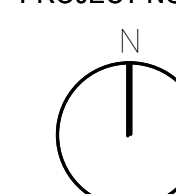

MAGNETIC NORTH

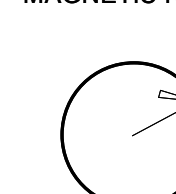

MECHANICAL LOCKER BUILDING PLAN

Scale: 1/8" = 1'-0"
Job No.: 20202
Drawn By: DRA
Date: January 13, 2023


M1-1-LB

DRA

Drummeys Rosane Anderson, Inc.
225 Oakland Road
Studio 205
South Windsor, CT
06074
260 Charles Street
Studio 300
Waltham, MA
02453
Planning | Architecture | Interior Design
Tel: 617-984-1700
www.draa.com

Northeast
Metropolitan
Regional
Vocational High
School

Wakefield, MA 01880

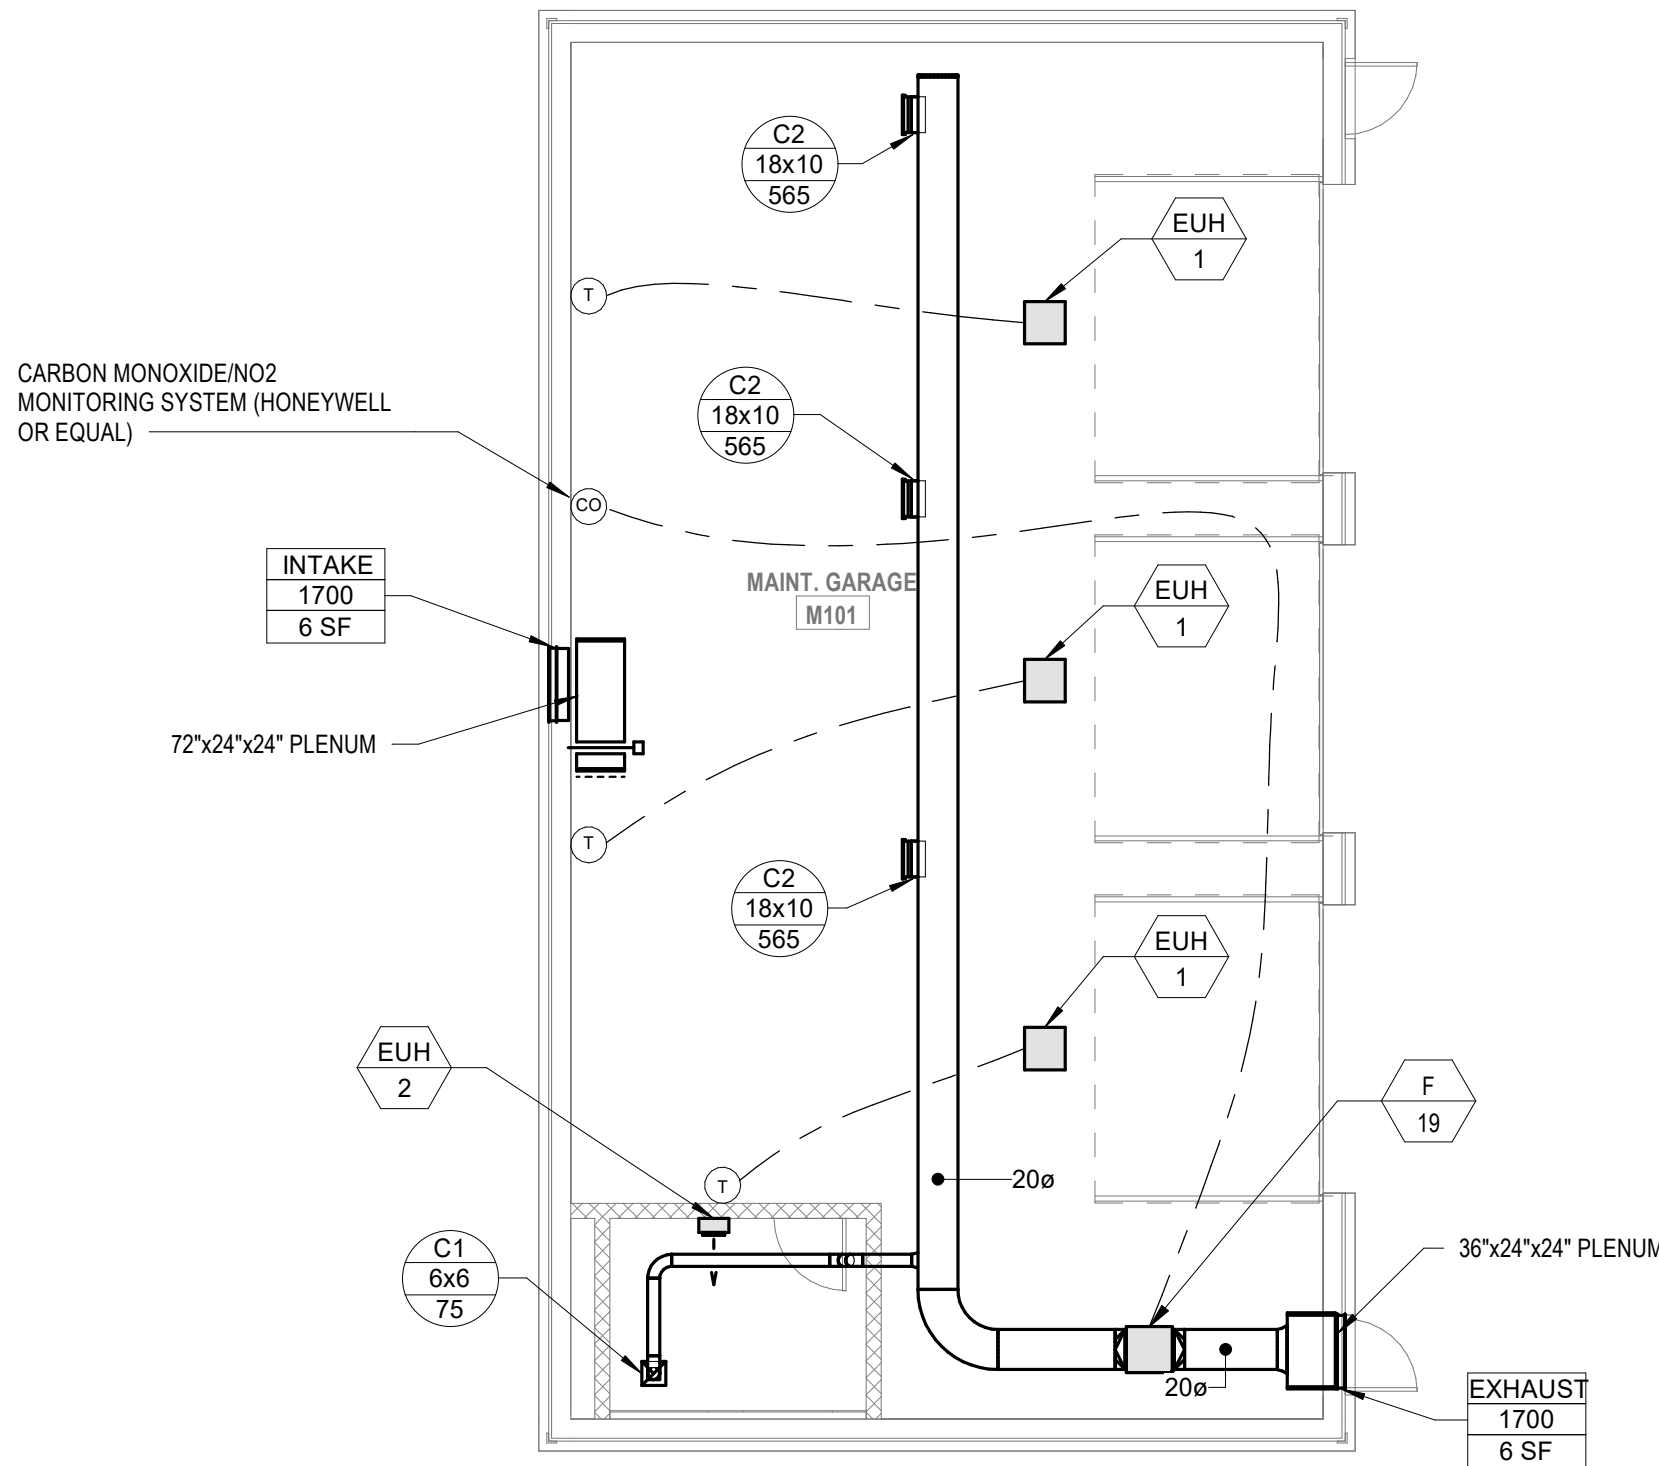

② MECHANICAL Maintenance Building Plan
1/8" = 1'-0"


© COPYRIGHT 2021 DRUMMEYS ROSANE ANDERSON, INC.

BALA
ENGINEERS
BALA CONSULTING ENGINEERS, INC.
300 WEST 10TH STREET
NEW YORK, NY 10014
TEL: 212-693-1000 FAX: 212-693-1001
WWW.BALA.COM


MSBA 60% CD
SUBMISSION

January 13, 2023

PROJECT NORTH

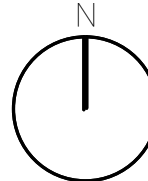

MAGNETIC NORTH

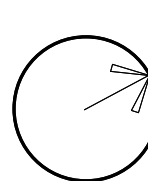

MECHANICAL
MAINTENANANCE
BUILDING PLAN


Scale: 1/8" = 1'-0"

Job No.: 20202

Drawn By: DRA

Date: January 13, 2023

M1-1-MB

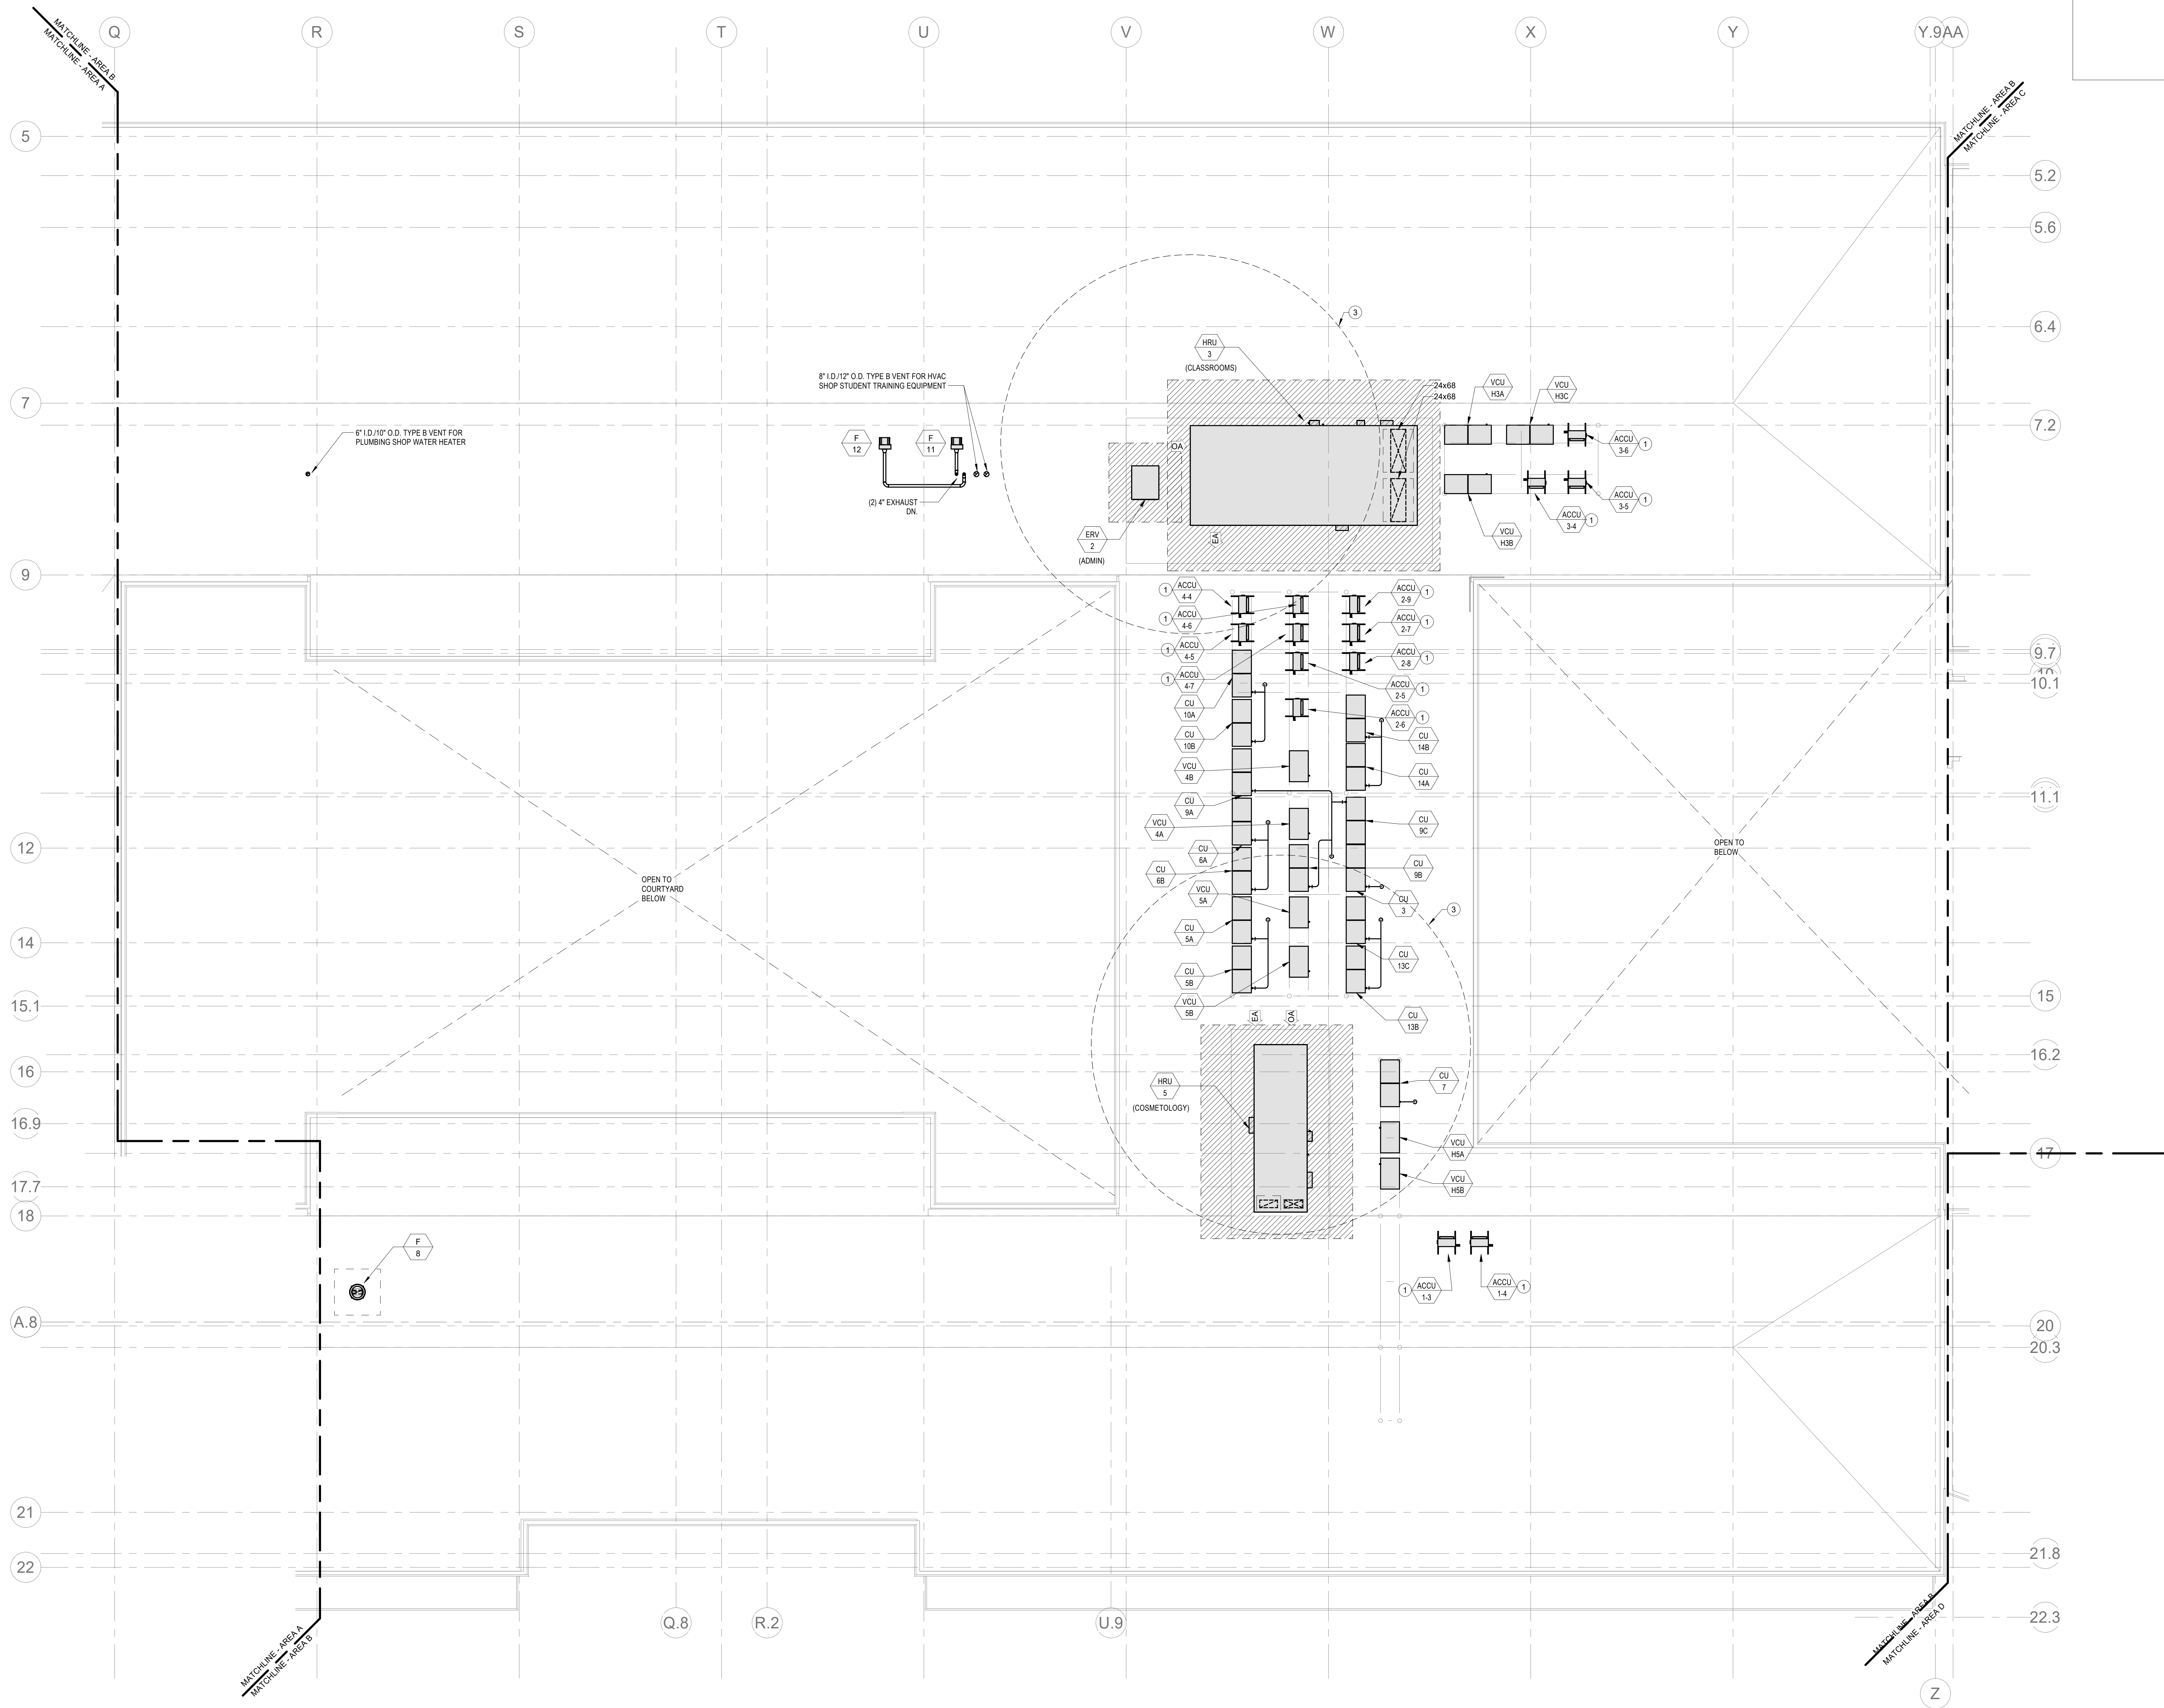

HVAC DRAWING NOTES

1. PROVIDE REFRIGERANT LINE SET FROM ACCU TO INDOOR AC UNIT. REFER TO EQUIPMENT CURB DETAIL TO DETAIL SHEETS.
2. REFER TO VRF PIPING DIAGRAMS ON THE M2 SERIES DRAWINGS FOR REFRIGERANT PIPING DISTRIBUTION. PROVIDE A CONDENSATE DRAIN FROM THE FAN COIL UNIT TO THE NEAREST CONDENSATE RECEPTOR. CONDENSATE RECEPTOR BY DIV. 22.
3. 25'-0" FRESH AIR INTAKE CLEARANCE FROM ALL HAZARDOUS/ODOROUS CONTAMINATES SHALL BE MAINTAINED. DIV. 23 CONTRACTOR SHALL VERIFY BASED UPON EQUIPMENT INSTALLATION.

DRA

Drumme Rosane Anderson, Inc.
225 Oakland Road
Studio 205
South Windsor, CT 06074
Tel: 617.984.1700
www.draan.com

280 Charles Street
Studio 300
Waltham, MA 02453
Tel: 617.984.1700
www.draan.com

Planning | Architecture | Interior Design

**Northeast
Metropolitan
Regional
Vocational High School**

Wakefield, MA 01880

© COPYRIGHT 2021 DRUMMEY ROSANE ANDERSON, INC.



BALA
ENGINEERS

BALA CONSULTING ENGINEERS, INC.
300 WEST 14TH STREET
NEW YORK, NY 10011
TEL: 212.693.1000 FAX: 212.693.1001
WWW.BALAE.COM

ARCHITECTS • ENGINEERS • PLANNERS
DESIGNERS • CONSULTANTS • INTERIORS

MSBA 60% CD
SUBMISSION

January 13, 2023

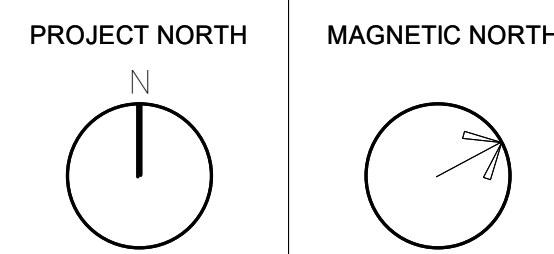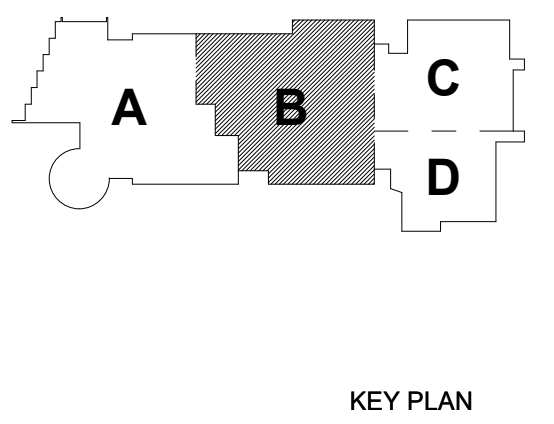


**MECHANICAL
ROOF PLAN -
AREA B**

Scale: 1/8" = 1'-0"
Job No.: 20022
Drawn By: DRA
Date: January 13, 2023

M1-2-1B

HVAC DRAWING NOTES

1. VRF REFRIGERANT PIPING IS SHOWN IN A SINGLE LINE DIAGRAMATIC LAYOUT FOR CLARITY. REFER TO THE M2 SERIES DRAWINGS FOR DETAILS ON VRF SYSTEM PIPING SIZES AND QUANTITIES. ALL LENGTHS ARE TO BE CONFIRMED IN THE FIELD AND SIZES ARE TO BE COORDINATED WITH THE VRF SYSTEM MANUFACTURER PRIOR TO ORDERING.
2. PROVIDE REFRIGERANT LINE SET FROM ACCU TO INDOOR AC UNIT. REFER TO EQUIPMENT CURB DETAIL ON DETAIL SHEETS.

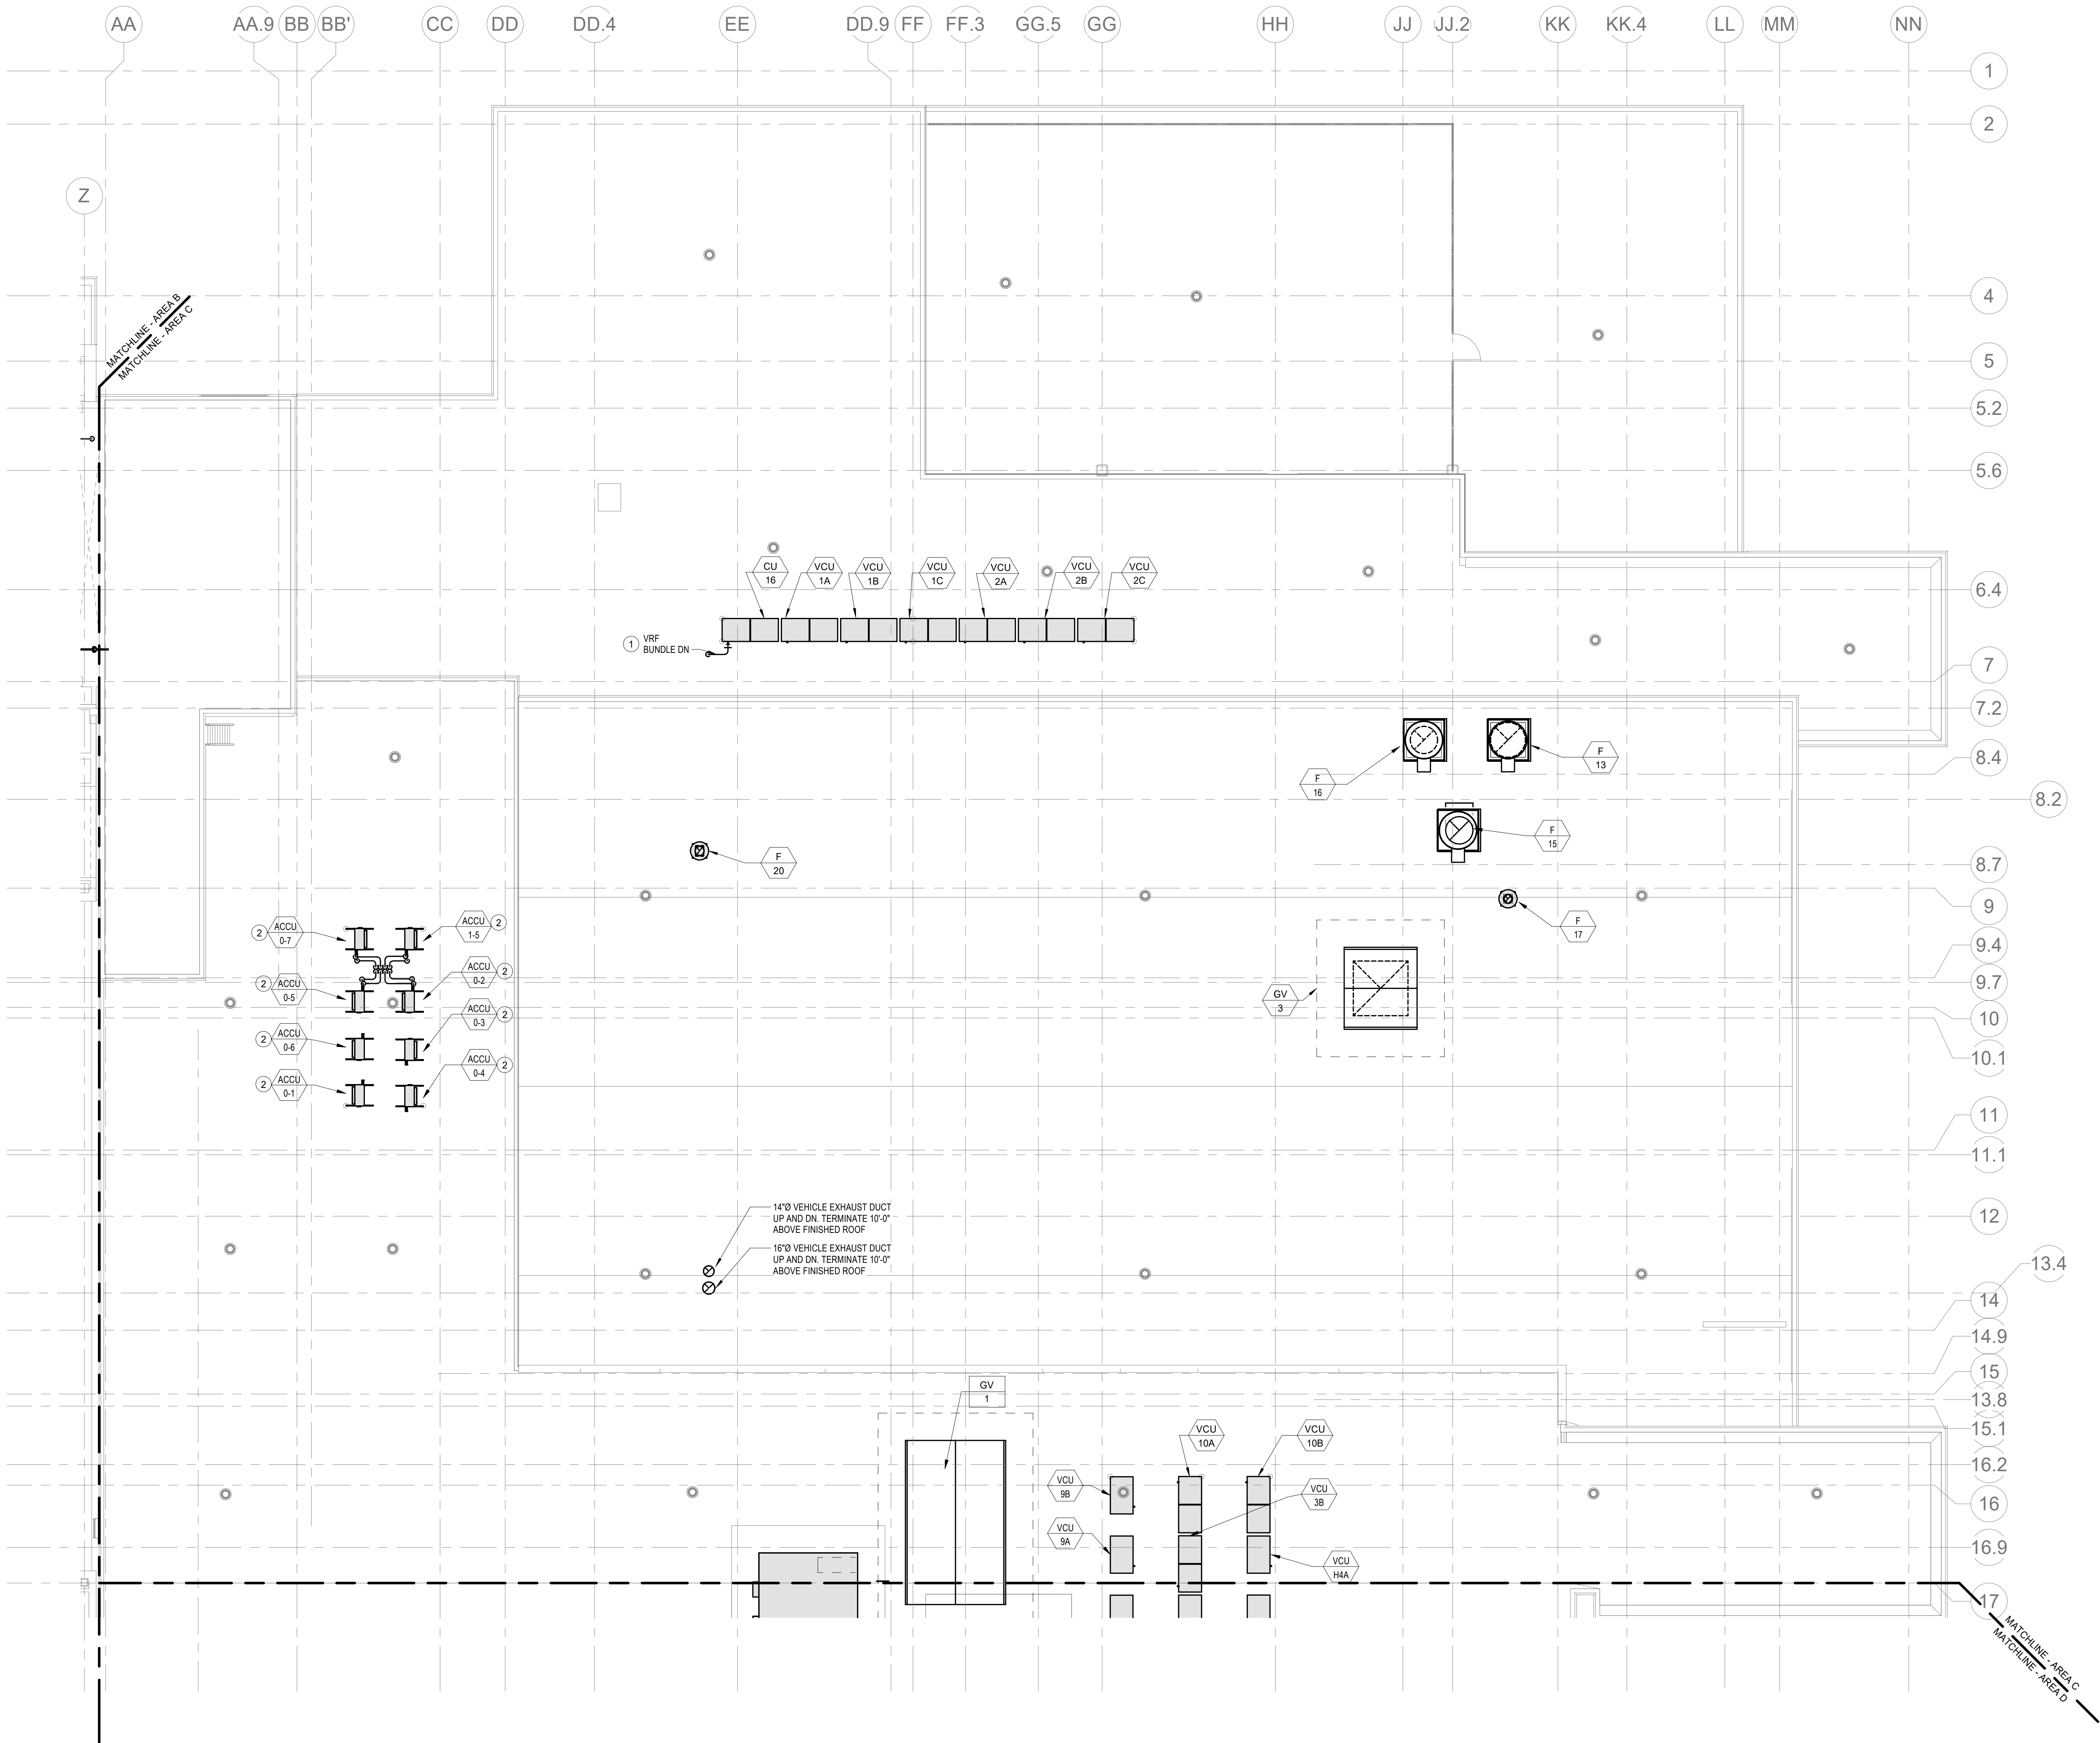


Northeast
Metropolitan
Regional
Vocational High
School

Wakefield, MA 01880

BALA
ENGINEERS


MSBA 60% CD
SUBMISSION

January 13, 2023

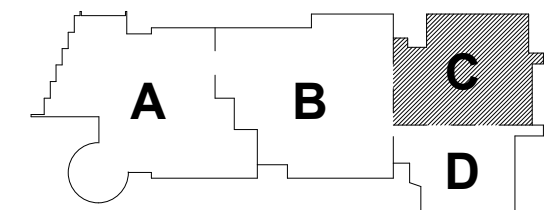

KEY PLAN

PROJECT NORTH MAGNETIC NORTH

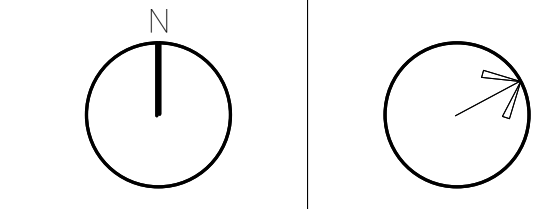

MECHANICAL
ROOF PLAN -
AREA C

Scale: 1/8" = 1'-0"
Job No.: 20202
Drawn By: DRA
Date: January 13, 2023

M1-2-1C

(

1. VRF REFRIGERANT PIPING IS SHOWN IN A SINGLE LINE DIAGRAMATIC LAYOUT FOR CLARITY. REFER TO THE M2 SERIES DRAWINGS FOR DETAILS ON VRF SYSTEM PIPING SIZES AND QUANTITIES. ALL LENGTHS ARE TO BE CONFIRMED IN THE FIELD AND SIZES ARE TO BE COORDINATED WITH THE VRF SYSTEM MANUFACTURER PRIOR TO ORDERING.
2. 25'-0" FRESH AIR INTAKE CLEARANCE FROM ALL HAZARDOUS/ODOROUS CONTAMINANTS SHALL BE MAINTAINED. DIV. 23 CONTRACTOR SHALL VERIFY BASED UPON EQUIPMENT INSTALLATION.


DRA

Drummey Rosane Anderson, Inc.	
225 Oakland Road Studio 205 South Windsor, CT 06074	260 Charles Street Studio 300 Waltham, MA 02453

Planning | Architecture | Interior Design
Tel: 617.964.1700
www.draas.com

**Northeast
Metropolitan
Regional
Vocational High
School**

Wakefield, MA 01880

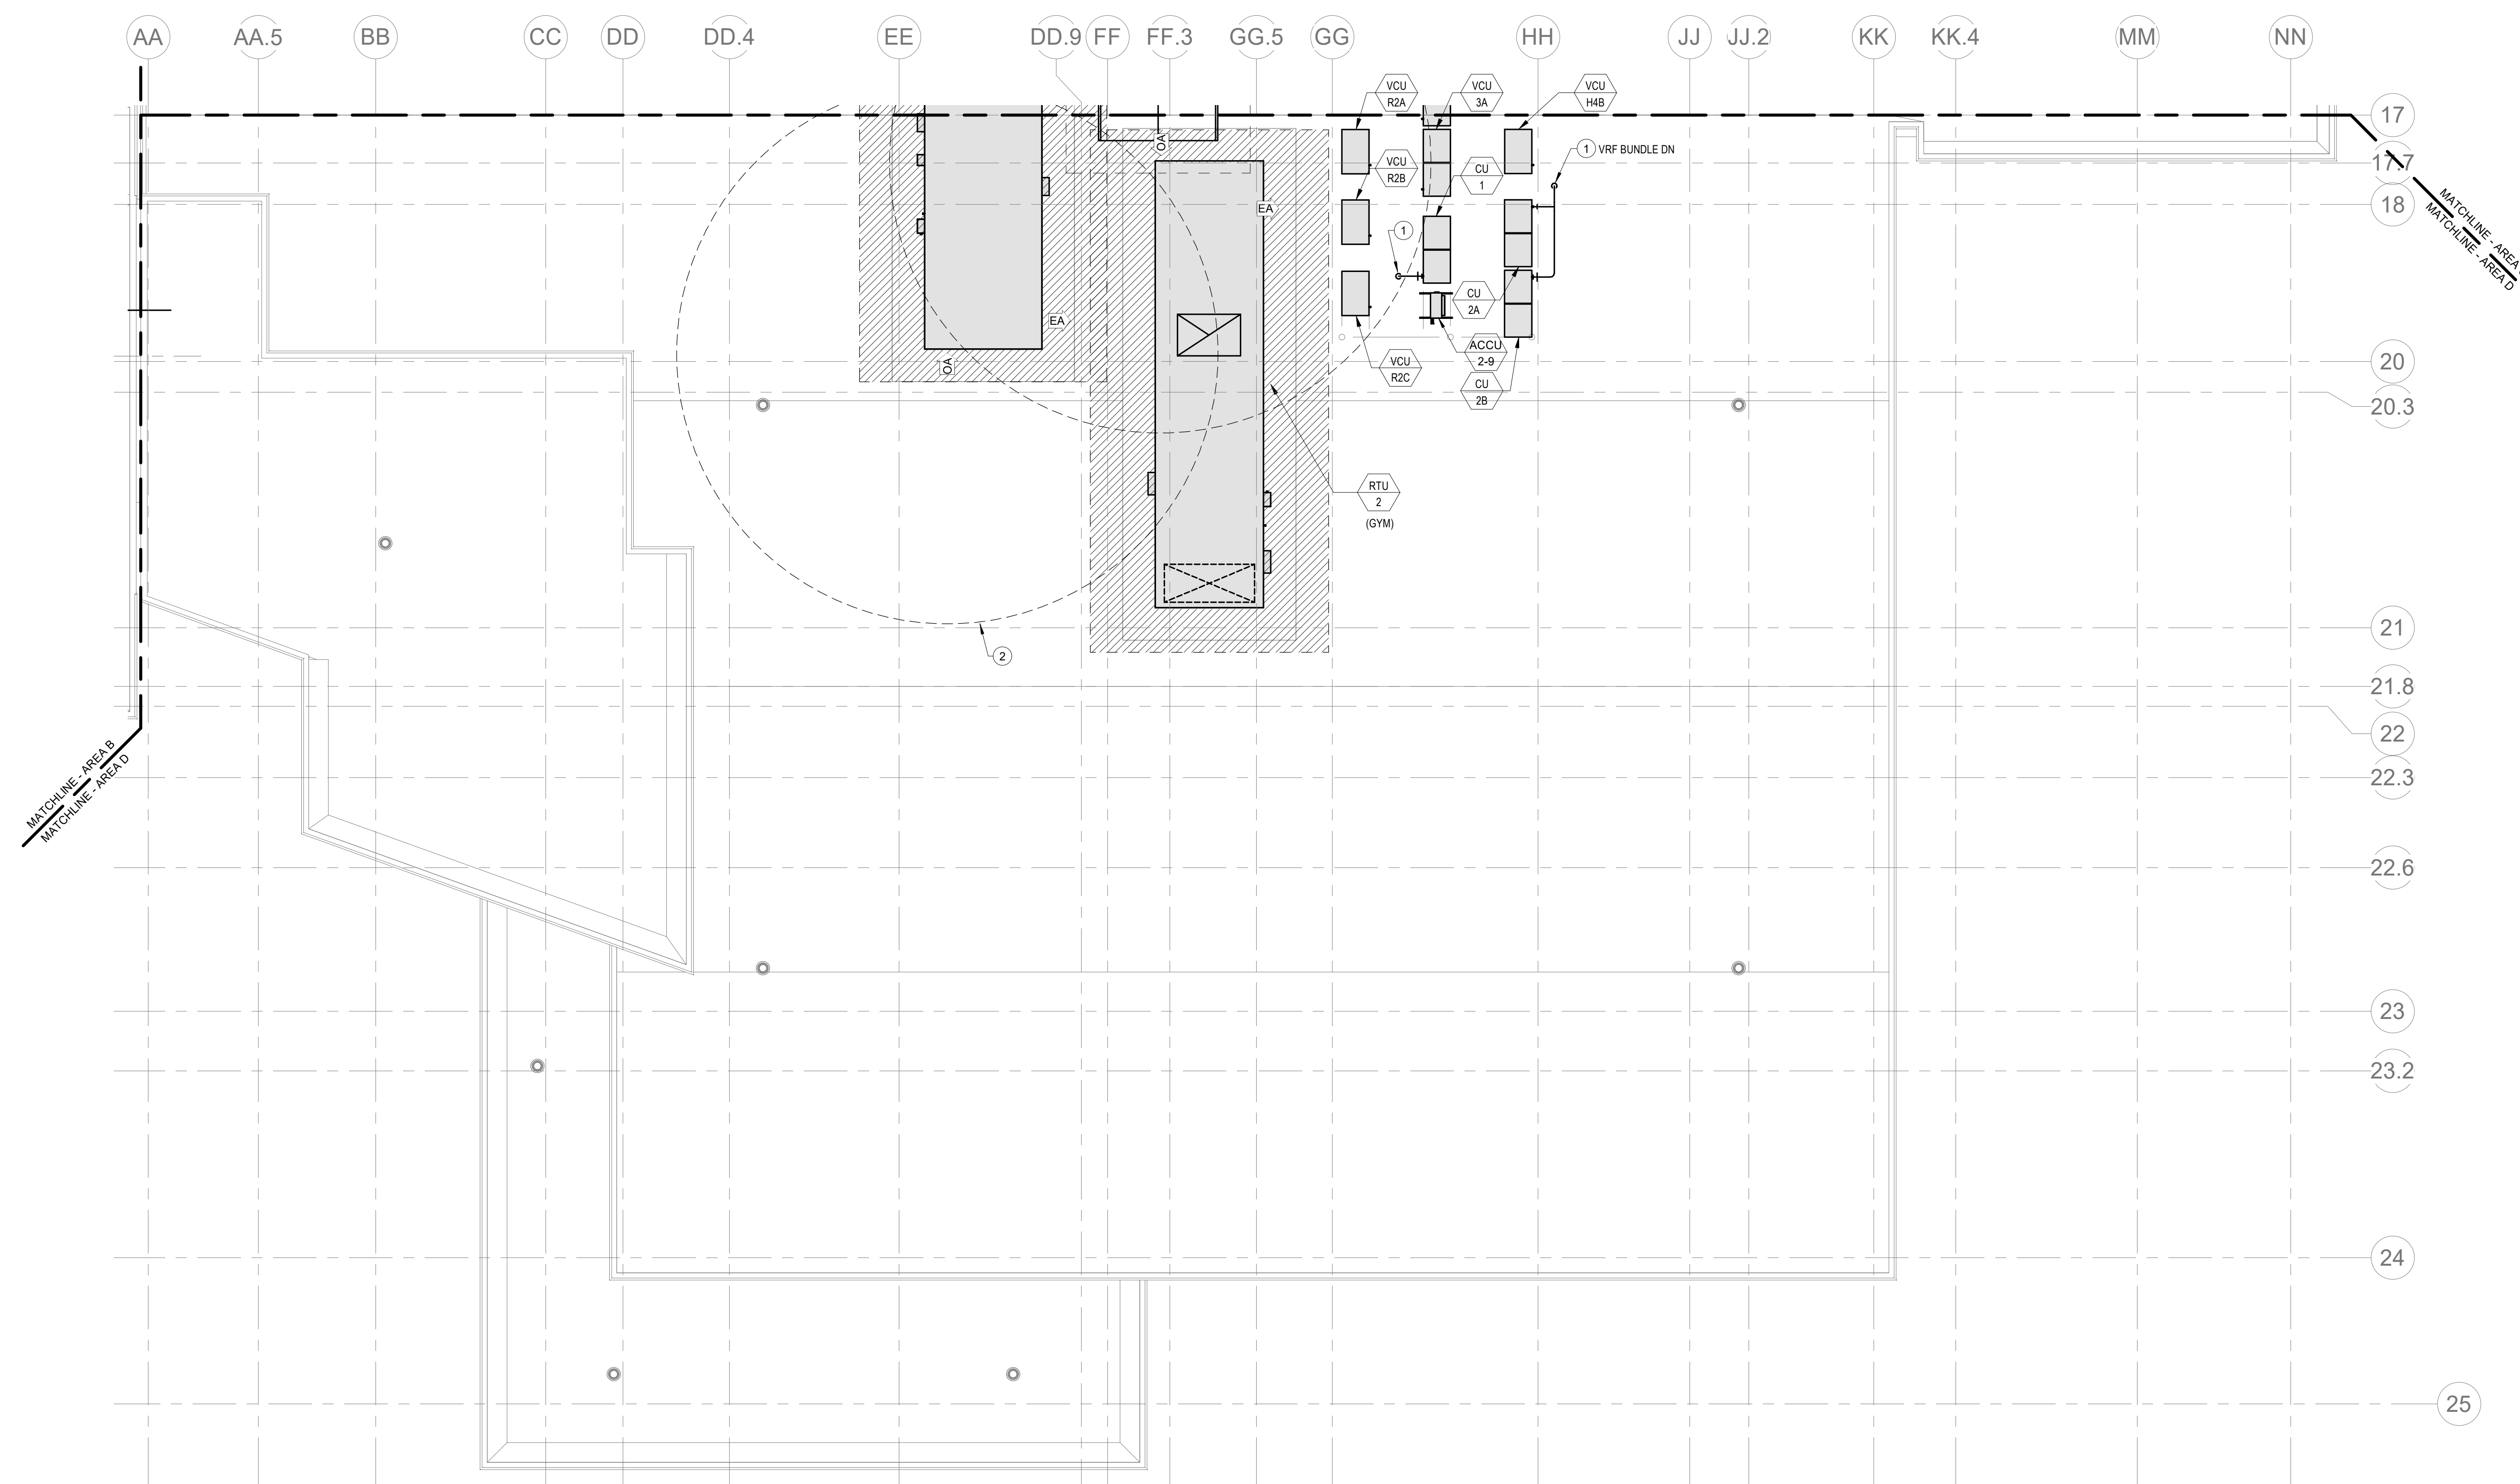

© COPYRIGHT 2004 DELIVERY POINTS AND FROM INC.


BALA
ENGINEERS

BALA CONELL TECHNOLOGIES, INC.
50 TEMPLE PLACE
BOSTON, MA 02111 USA
TEL: 617.237.8880 FAX: 617.237.8881
WWW.BALA.COM

MEMBERSHIP | PARTNERS | DONORS | PRESS CONTACT

MSBA 60% CD
SUBMISSION



January 13, 2023

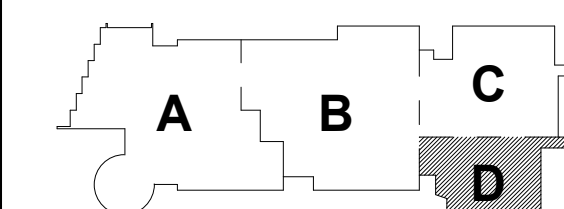

KEY PLAN

PROJECT NORTH

MAGNETIC NORTH

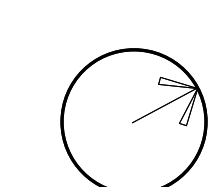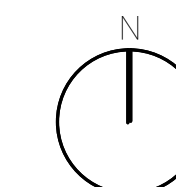

**MECHANICAL
ROOF PLAN -
AREA D**

Scale: 1/8" = 1'-0"

Job No. : 20202


Drawn By: DR

Date: January 13, 2022

M1-2-1D

HVAC DRAWING NOTES

1. VRF REFRIGERANT PIPING IS SHOWN IN A SINGLE LINE DIAGRAMATIC LAYOUT FOR CLARITY. REFER TO THE M2 SERIES DRAWINGS FOR DETAILS ON VRF SYSTEM PIPING SIZES AND QUANTITIES. ALL LENGTHS ARE TO BE CONFIRMED IN THE FIELD AND SIZES ARE TO BE COORDINATED WITH THE VRF SYSTEM MANUFACTURER PRIOR TO ORDERING.
2. PROVIDE REFRIGERANT LINE SET FROM AG UNIT TO ASSOCIATED CONDENSING UNIT ON ROOF. INTEGRAL CONDENSATE PUMP, AND CONDENSATE DRAIN PIPING TO NEAREST CONDENSATE RECEPTOR. CONDENSATE RECEPTOR BY DIV. 22.

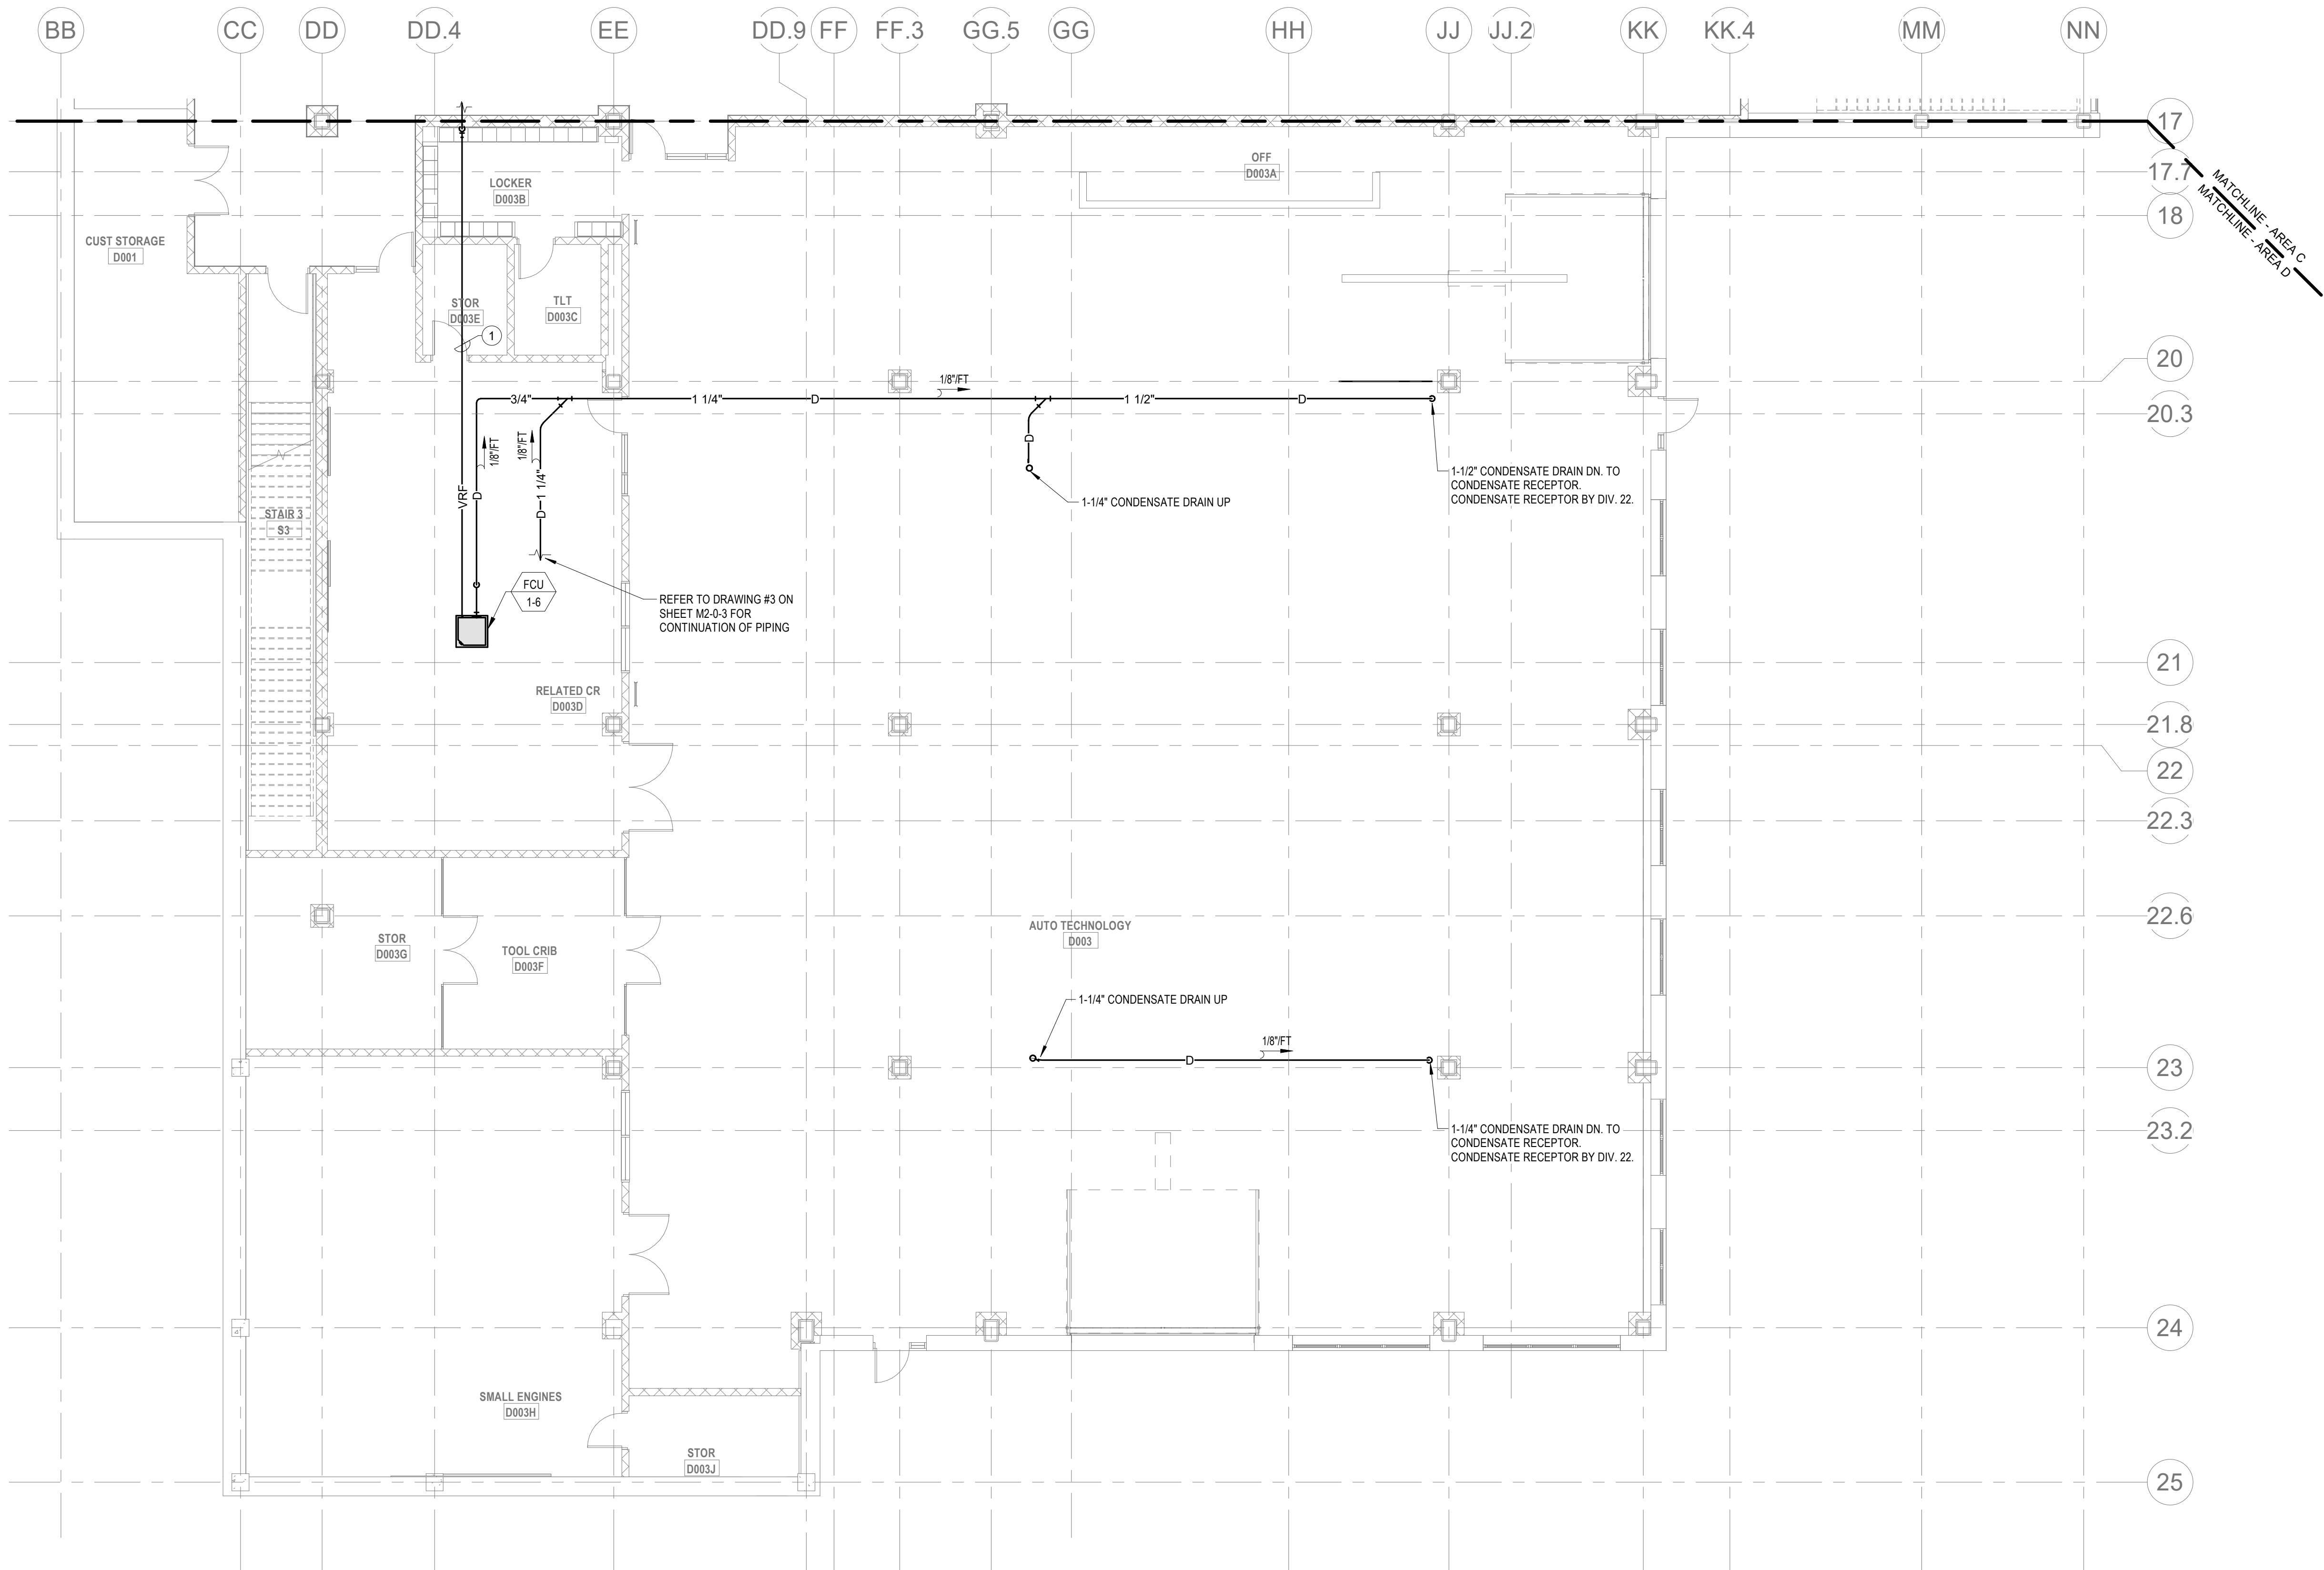

Northeast
Metropolitan
Regional
Vocational High
School


Wakefield, MA 01880

© COPYRIGHT 2021 DRUMMEY ROSANE ANDERSON, INC.

BALA
ENGINEERS


MSBA 60% CD
SUBMISSION

January 13, 2023

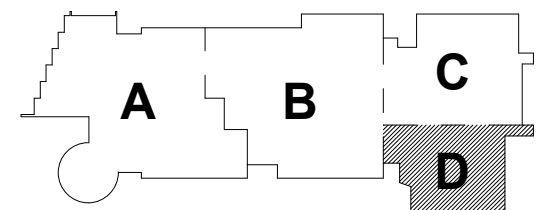


KEY PLAN

PROJECT NORTH

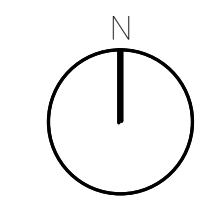

MAGNETIC NORTH

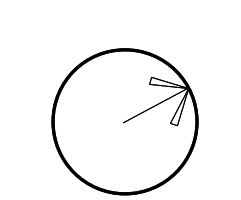

MECHANICAL
PIPING LOWER
LEVEL FLOOR
PLAN - AREA D


Scale: 1/8" = 1'-0"

Job No.: 2002

Drawn By: DRA

Date: January 13, 2023

M1-3-0D

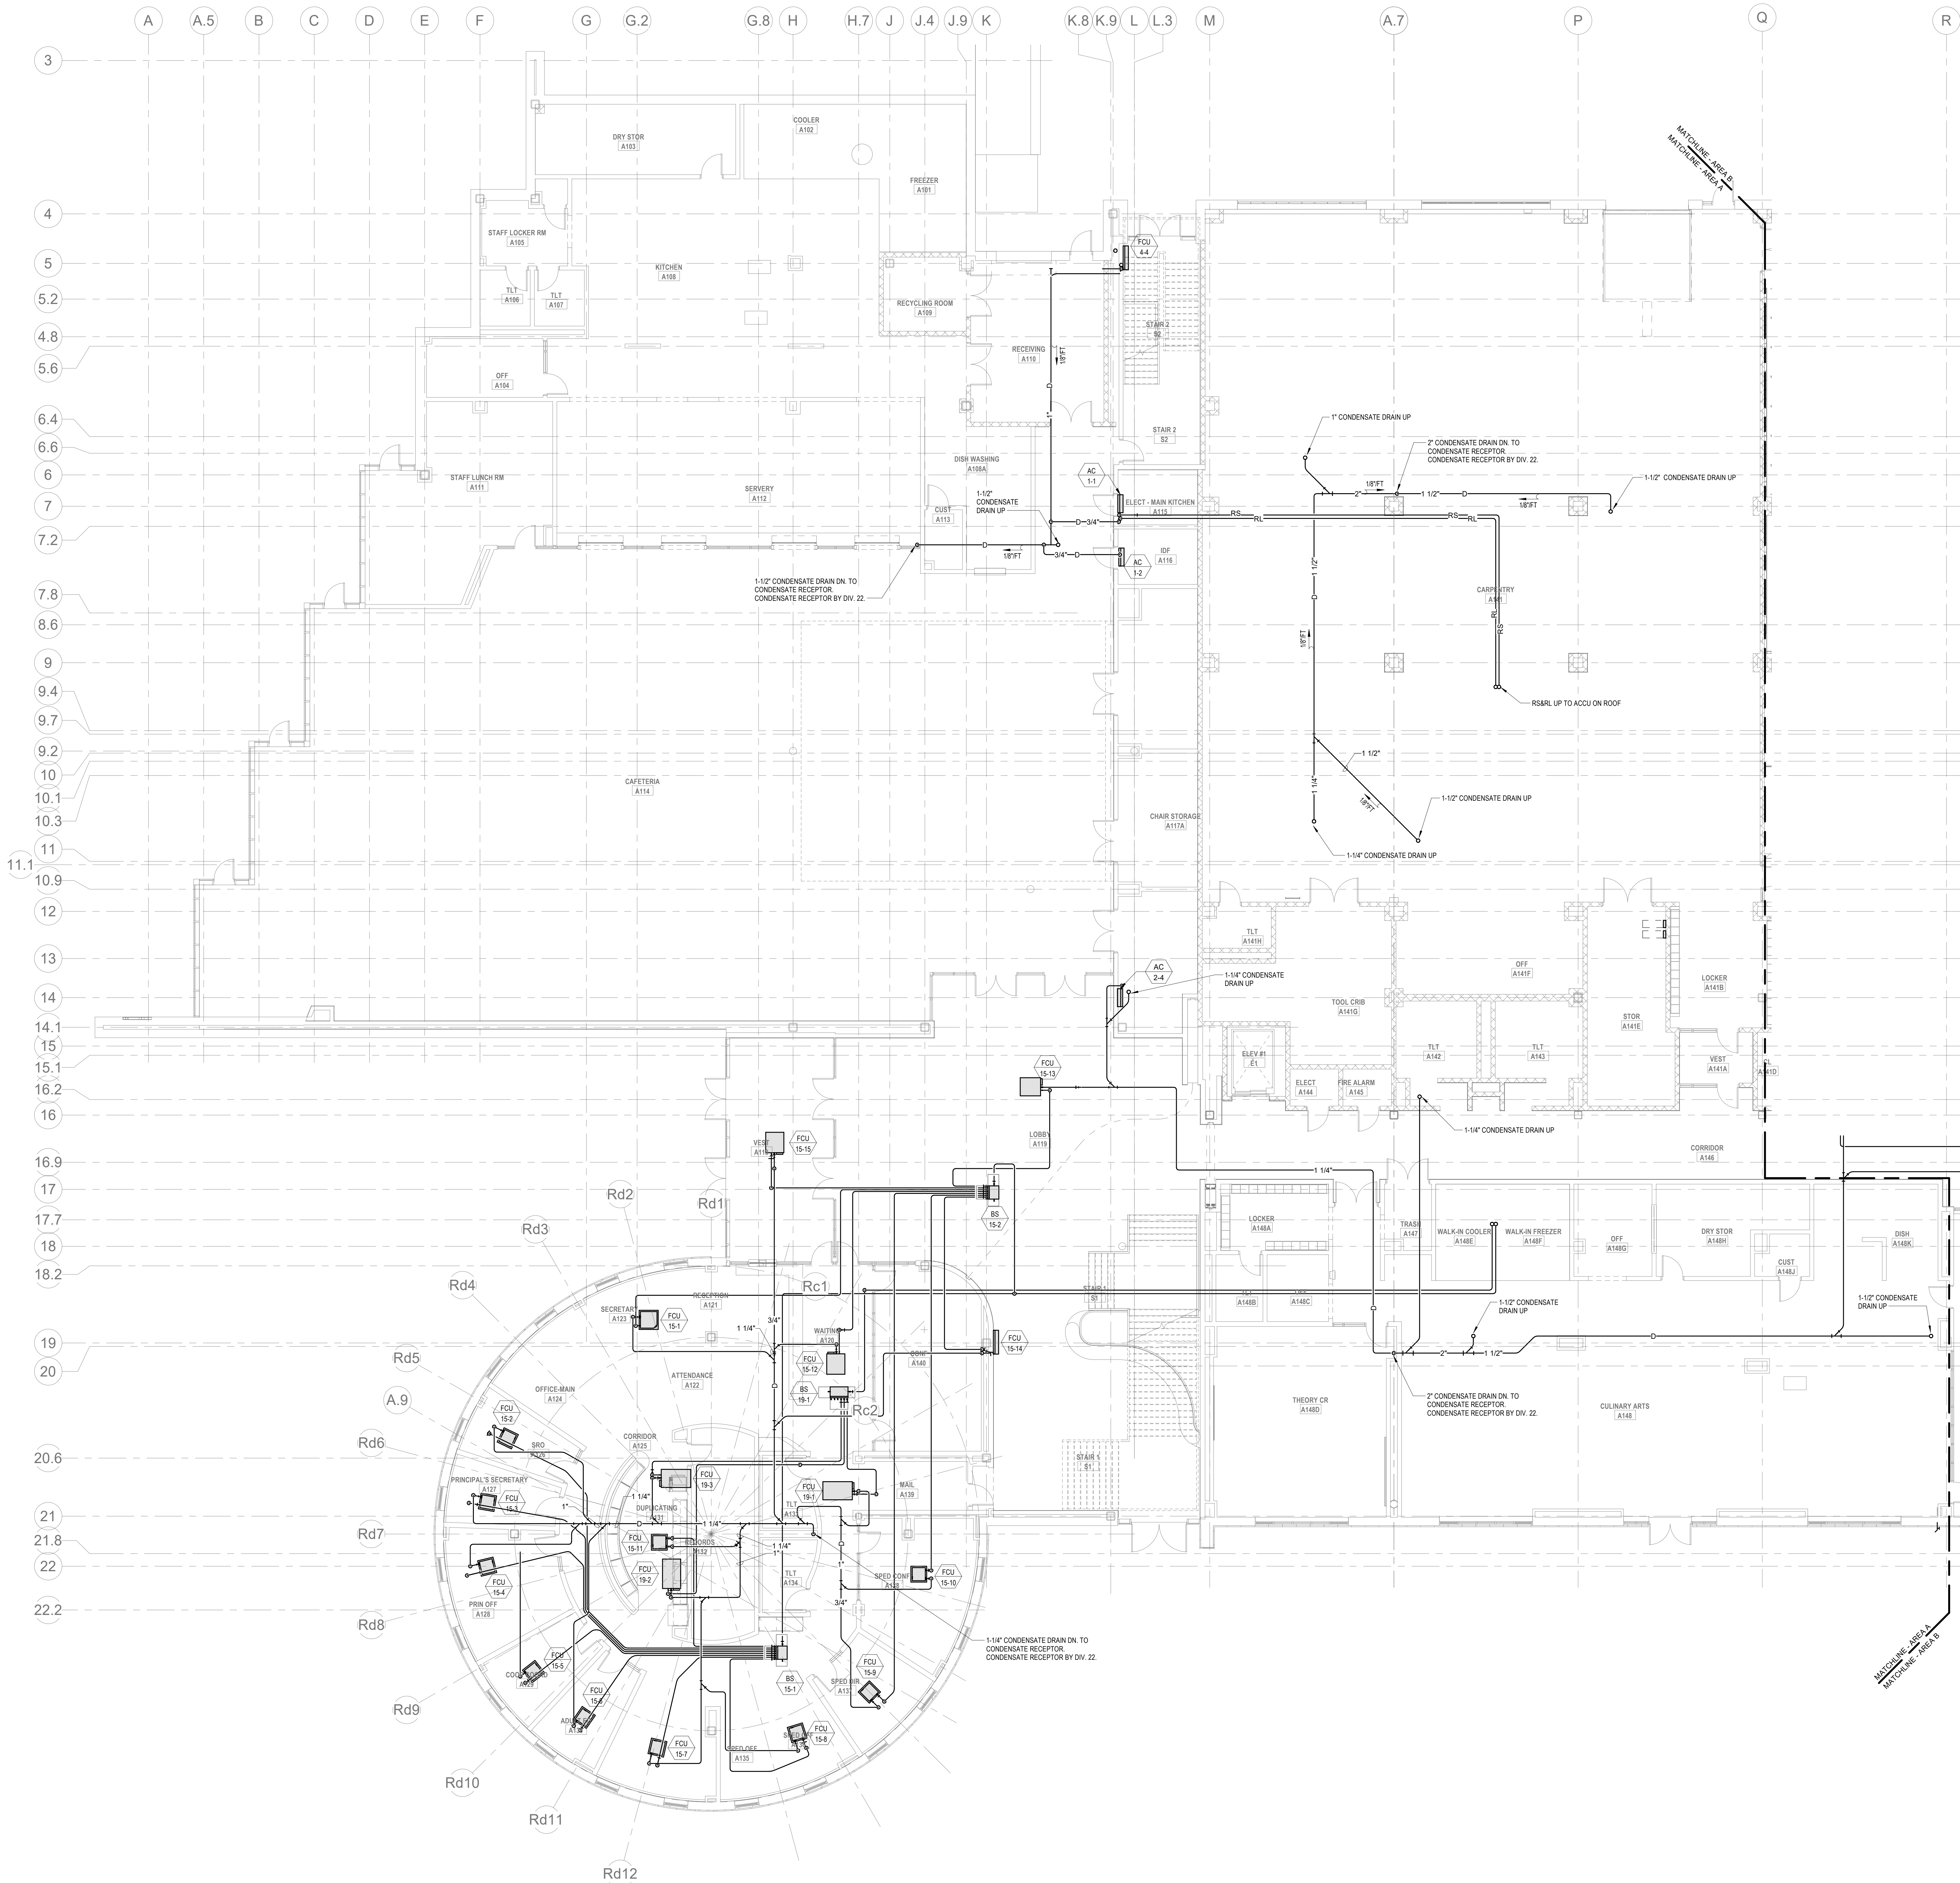

HVAC GENERAL NOTES

1. VRF REFRIGERANT PIPING IS SHOWN IN A SINGLE LINE DIAGRAMATIC LAYOUT FOR CLARITY. REFER TO THE M2 SERIES DRAWINGS FOR DETAILS ON VRF SYSTEM PIPING SIZES AND QUANTITIES. ALL LENGTHS ARE TO BE CONFIRMED IN THE FIELD AND SIZES ARE TO BE COORDINATED WITH THE VRF SYSTEM MANUFACTURER PRIOR TO ORDERING.
2. PROVIDE REFRIGERANT LINE SET FROM EACH AC UNIT TO ASSOCIATED CONDENSING UNIT ON ROOF. INTEGRAL CONDENSATE PUMP AND CONDENSATE DRAIN PIPING TO NEAREST CONDENSATE RECEPTOR. CONDENSATE RECEPTOR BY DIV. 22.

HVAC DRAWING NOTES

1. .

Northeast
Metropolitan
Regional
Vocational High
School

Wakefield, MA 01880


Drumme Rosane Anderson, Inc.
225 Oakland Road
Studio 205
South Windsor, CT
06074
Tel: 817.984.1700
www.dra.com

© COPYRIGHT 2021 DRUMME ROSANE ANDERSON, INC.


BALA
ENGINEERS

MSBA 60% CD
SUBMISSION

January 13, 2023

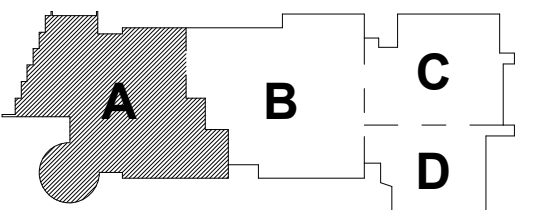

KEY PLAN

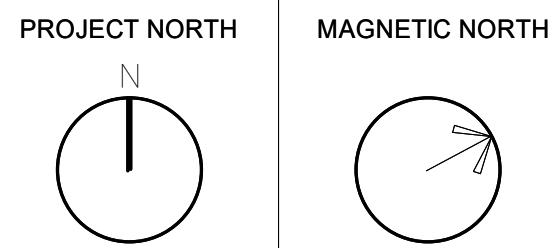

MECHANICAL
PIPING FIRST
FLOOR PLAN -
AREA A

Scale: 1/8" = 1'-0"
Job No.: 20202
Drawn By: DRA
Date: January 13, 2023

M1-3-1A

DRA

Drumme Rosane Anderson, Inc.
225 Oakland Road
Studio 205
South Windsor, CT
06074
Planning | Architecture | Interior Design
Tel: 617.984.1700
www.dra-inc.com

**Northeast
Metropolitan
Regional
Vocational High School**

Wakefield, MA 01880

HVAC GENERAL NOTES

1. PROVIDE REFRIGERANT LINE SET FROM EACH AC UNIT TO ASSOCIATED CONDENSING UNIT ON ROOF. INTEGRAL CONDENSATE PUMP AND CONDENSATE DRAIN PIPING TO NEAREST CONDENSATE RECEPTOR. CONDENSATE RECEPTOR BY DIV. 22.

HVAC DRAWING NOTES


1. PIPING FOR STUDENT TRAINING EQUIPMENT SHALL NOT BE INSTALLED UNDER THIS CONTRACT.
2. VRF REFRIGERANT PIPING IS SHOWN IN A SINGLE LINE DIAGRAMMATIC LAYOUT FOR CLARITY. REFER TO THE M2 SERIES DRAWINGS FOR DETAILS ON VRF SYSTEM PIPING SIZES AND QUANTITIES. ALL LENGTHS ARE TO BE CONFIRMED IN THE FIELD AND SIZES ARE TO BE COORDINATED WITH THE VRF SYSTEM MANUFACTURER PRIOR TO ORDERING.

© COPYRIGHT 2021 DRUMME ROSANE ANDERSON, INC.

BALA
ENGINEERS


MSBA 60% CD
SUBMISSION

January 13, 2023

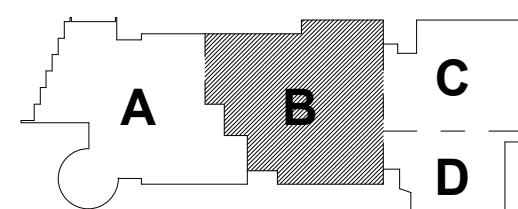


KEY PLAN

PROJECT NORTH

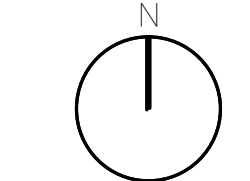

MAGNETIC NORTH

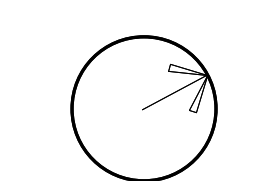

**MECHANICAL
PIPING FIRST
FLOOR PLAN -
AREA B**


Scale: 1/8" = 1'-0"

Job No.: 20202

Drawn By: DRA


Date: January 13, 2023

M1-3-1B

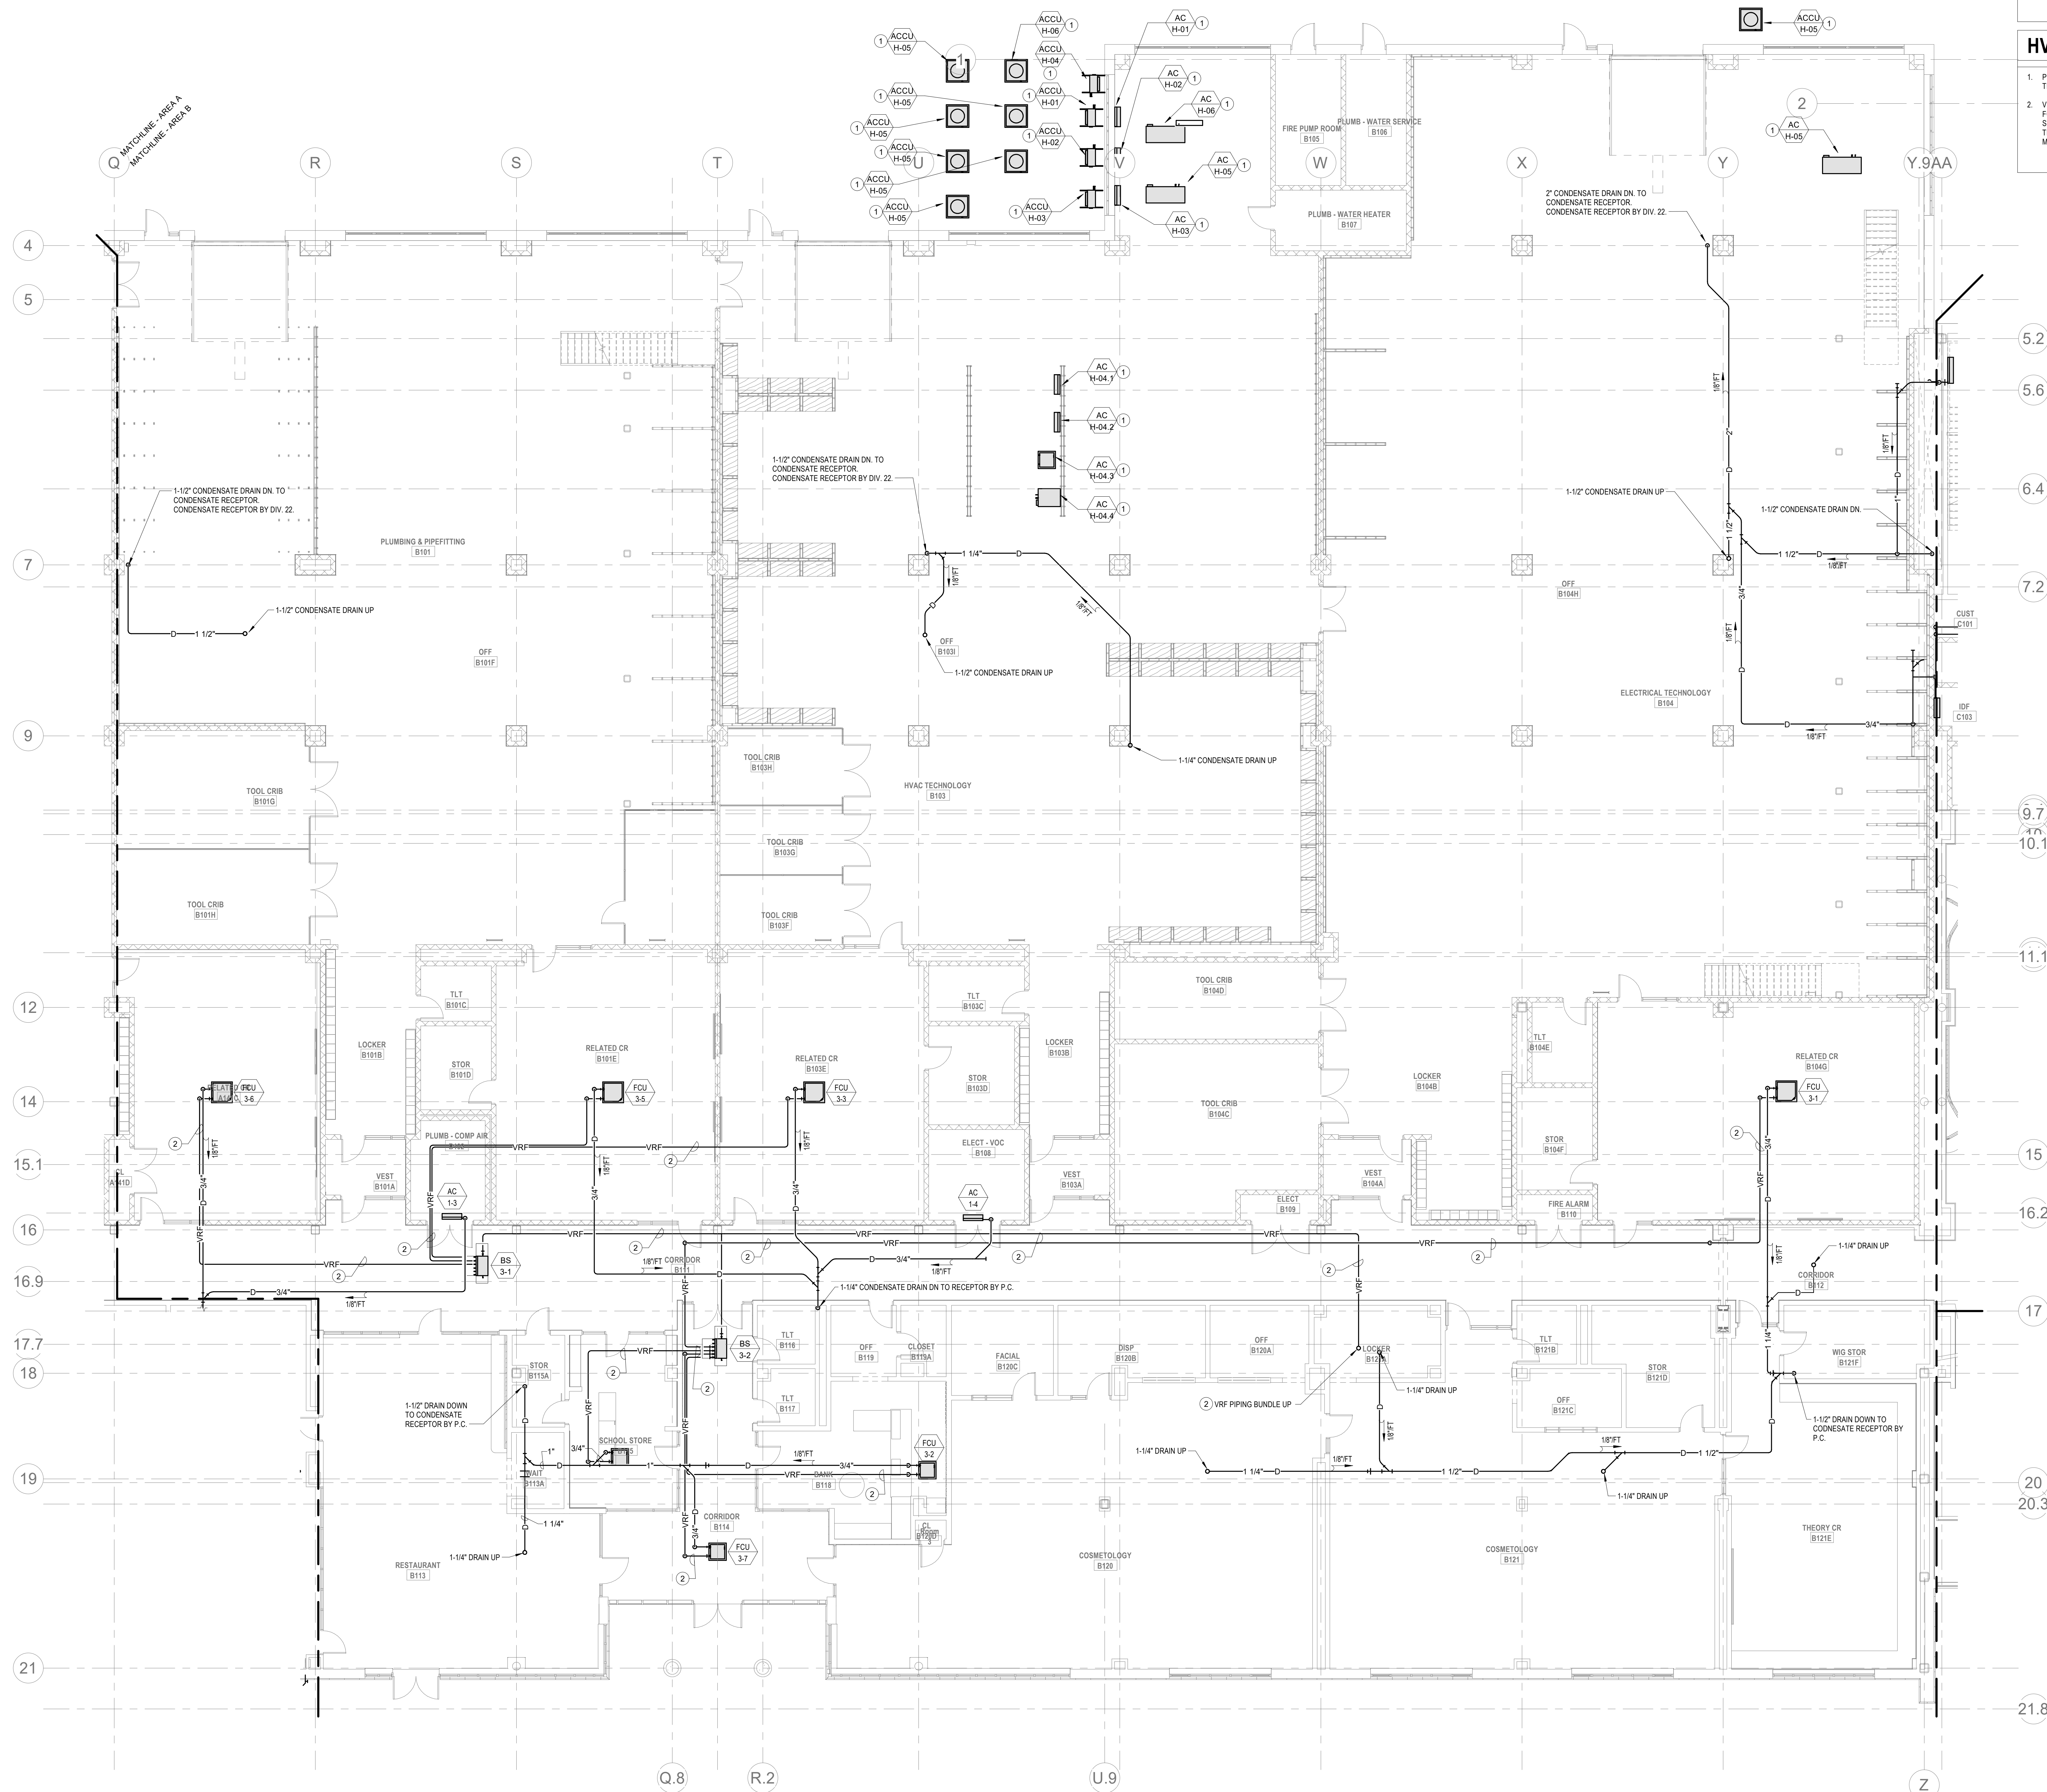

HVAC DRAWING NOTES

1. VRF REFRIGERANT PIPING IS SHOWN IN A SINGLE LINE DIAGRAMATIC LAYOUT FOR CLARITY. REFER TO THE M2 SERIES DRAWINGS FOR DETAILS ON VRF SYSTEM PIPING SIZES AND QUANTITIES. ALL LENGTHS ARE TO BE CONFIRMED IN THE FIELD AND SIZES ARE TO BE COORDINATED WITH THE VRF SYSTEM MANUFACTURER PRIOR TO ORDERING.
2. PROVIDE REFRIGERANT LINE SET FROM EACH AC UNIT TO ASSOCIATED CONDENSING UNIT ON ROOF. INTEGRAL CONDENSATE PUMP AND CONDENSATE DRAIN PIPING TO NEAREST CONDENSATE RECEPTOR. CONDENSATE RECEPTOR BY DIV. 22.

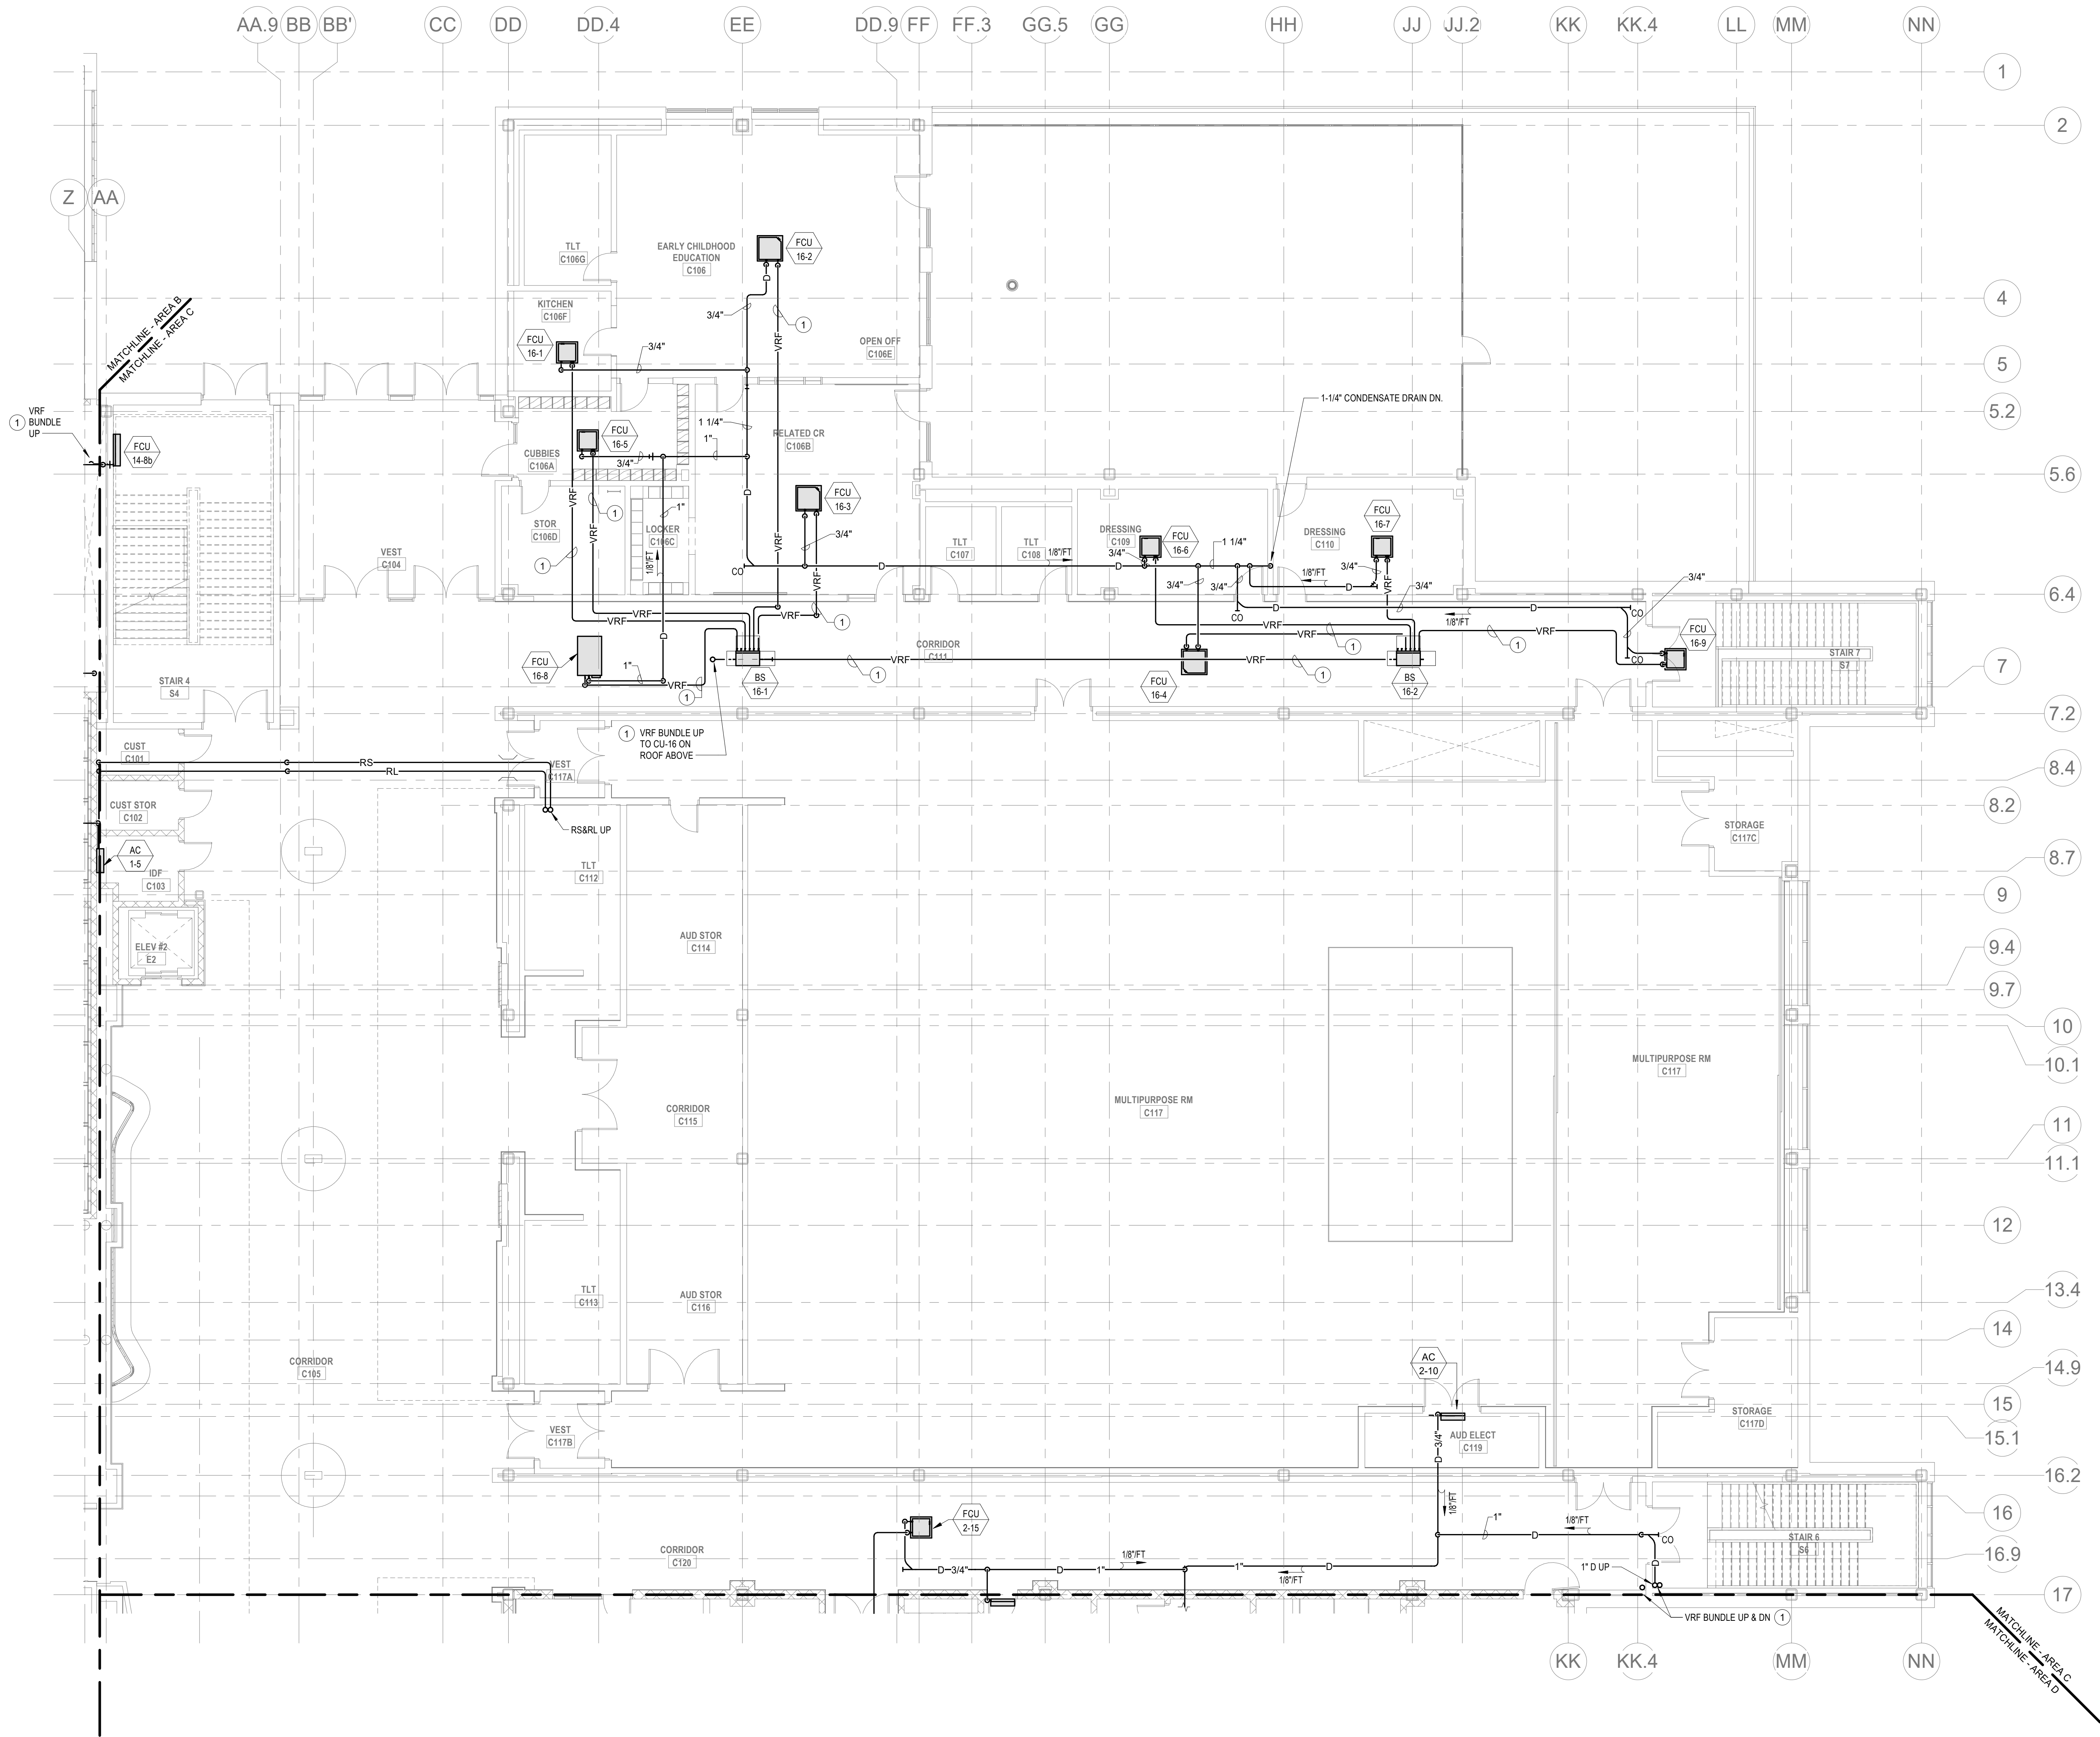

DRA

Drumme Rosane Anderson, Inc.
225 Oakland Road
Studio 205
South Windsor, CT
06074
Tel: 817.984.1700
www.dra.com

280 Charles Street
Studio 300
Waltham, MA
02453

Planning | Architecture | Interior Design



Northeast
Metropolitan
Regional
Vocational High
School

Wakefield, MA 01880

© COPYRIGHT 2021 DRUMME ROSANE ANDERSON, INC.

BALA
ENGINEERS

MSBA 60% CD
SUBMISSION
January 13, 2023

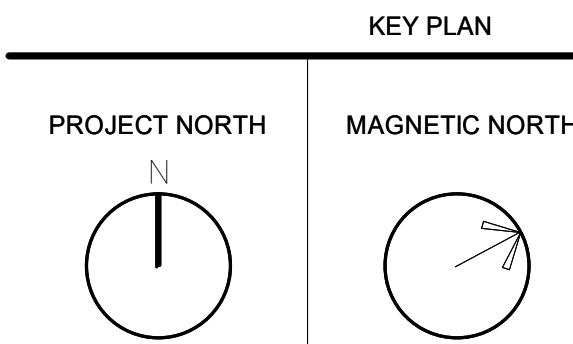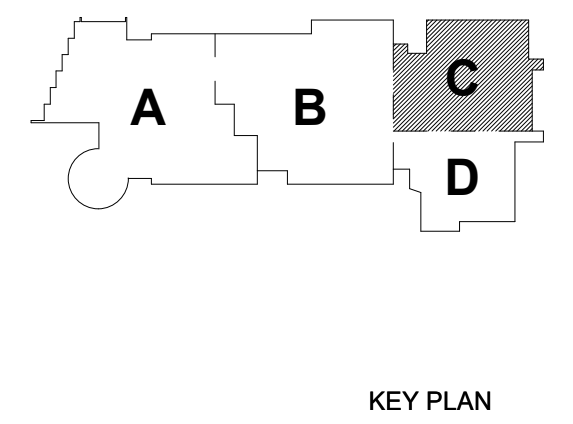


MECHANICAL
PIPING FIRST
FLOOR PLAN -
AREA C

Scale: 1/8" = 1'-0"
Job No.: 20202
Drawn By: DRA
Date: January 13, 2023

M1-3-1C

HVAC DRAWING NOTES

1. VRF REFRIGERANT PIPING IS SHOWN IN A SINGLE LINE DIAGRAMATIC LAYOUT FOR CLARITY. REFER TO THE ME SERIES DRAWINGS FOR DETAILS ON VRF SYSTEM PIPING SIZES AND QUANTITIES. ALL LENGTHS ARE TO BE CONFIRMED IN THE FIELD AND SIZES ARE TO BE COORDINATED WITH THE VRF SYSTEM MANUFACTURER PRIOR TO ORDERING.
2. PROVIDE REFRIGERANT LINE SET FROM EACH AC UNIT TO ASSOCIATED CONDENSING UNIT ON ROOF. INTEGRAL CONDENSATE PUMP, AND CONDENSATE DRAIN PIPING TO NEAREST CONDENSATE RECEPTOR. CONDENSATE RECEPTOR BY DIV. 22.

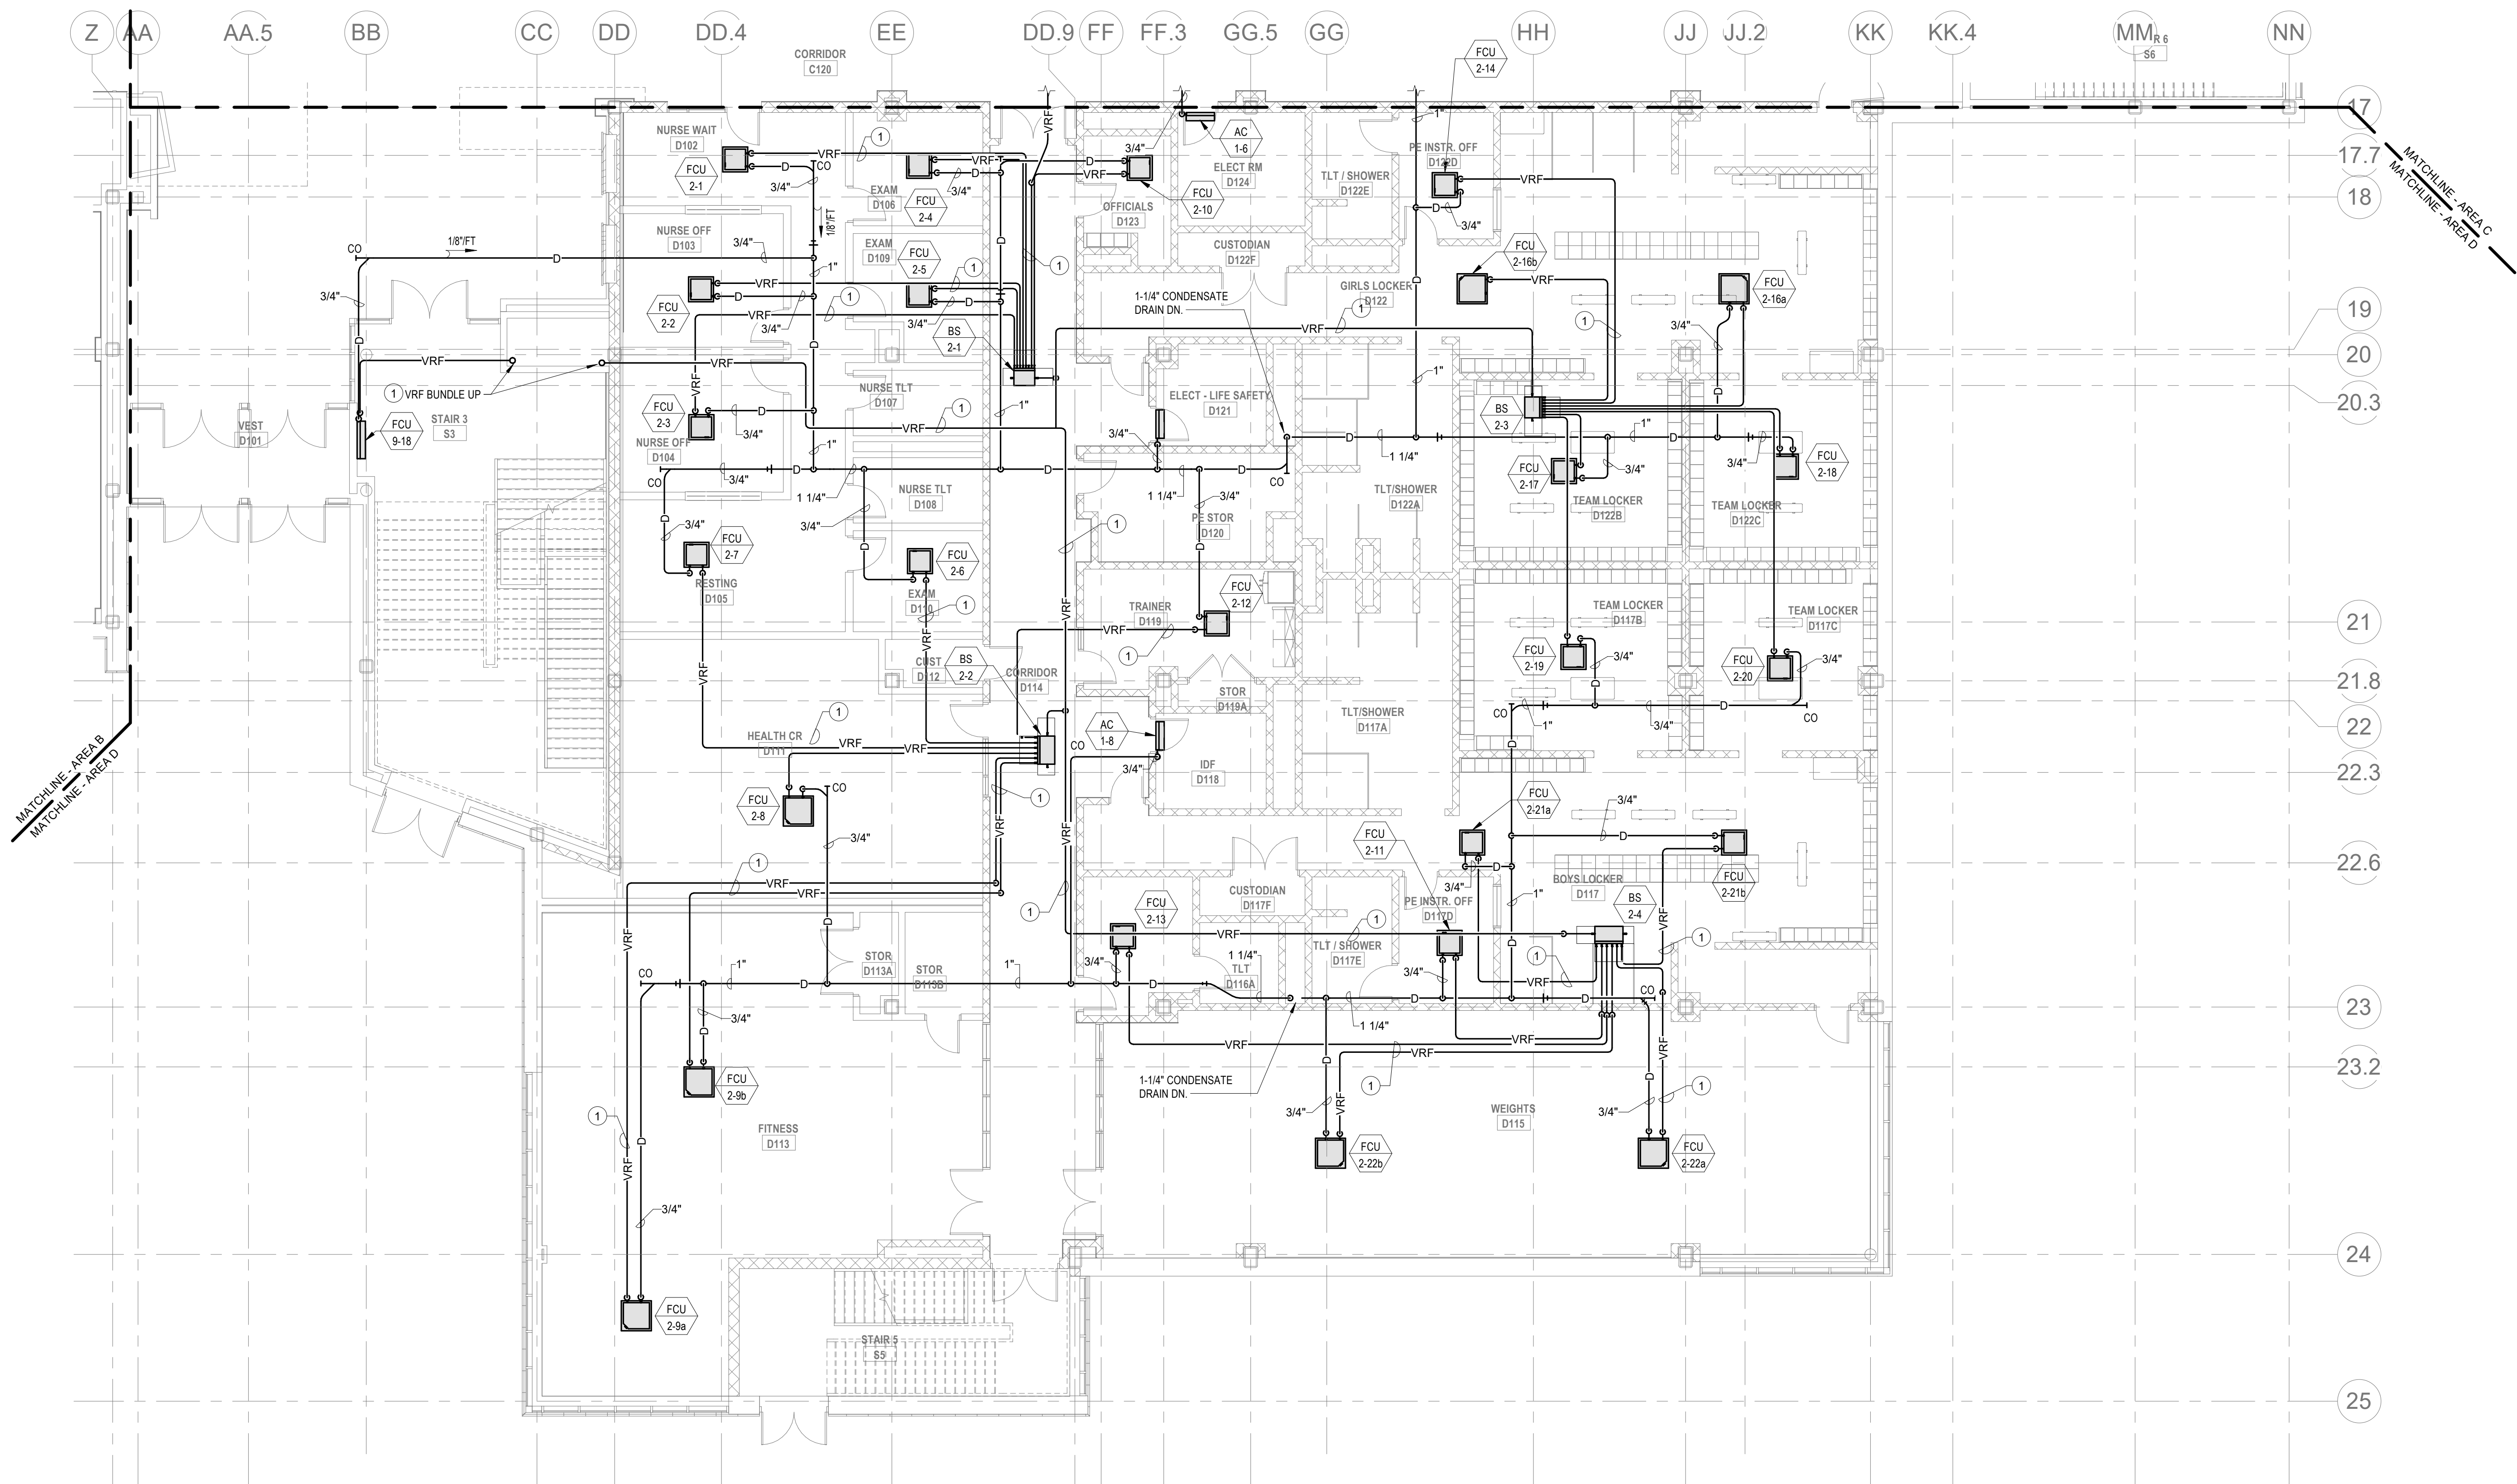


© COPYRIGHT 2021 DRUMMEY ROSANE ANDERSON, INC.

BALA
ENGINEERS

MSBA 60% CD
SUBMISSION



January 13, 2023

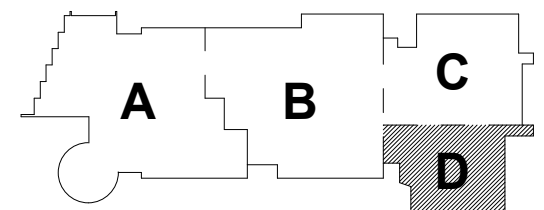

KEY PLAN

PROJECT NORTH

MAGNETIC NORTH

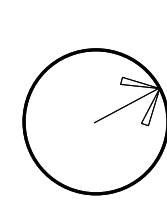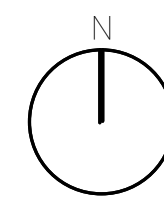

**MECHANICAL
PIPING FIRST
FLOOR PLAN -
AREA D**


Scale: 1/8" = 1'-0"

Job No.: 20202

Drawn By: DRA

Date: January 13, 2023

M1-3-1D

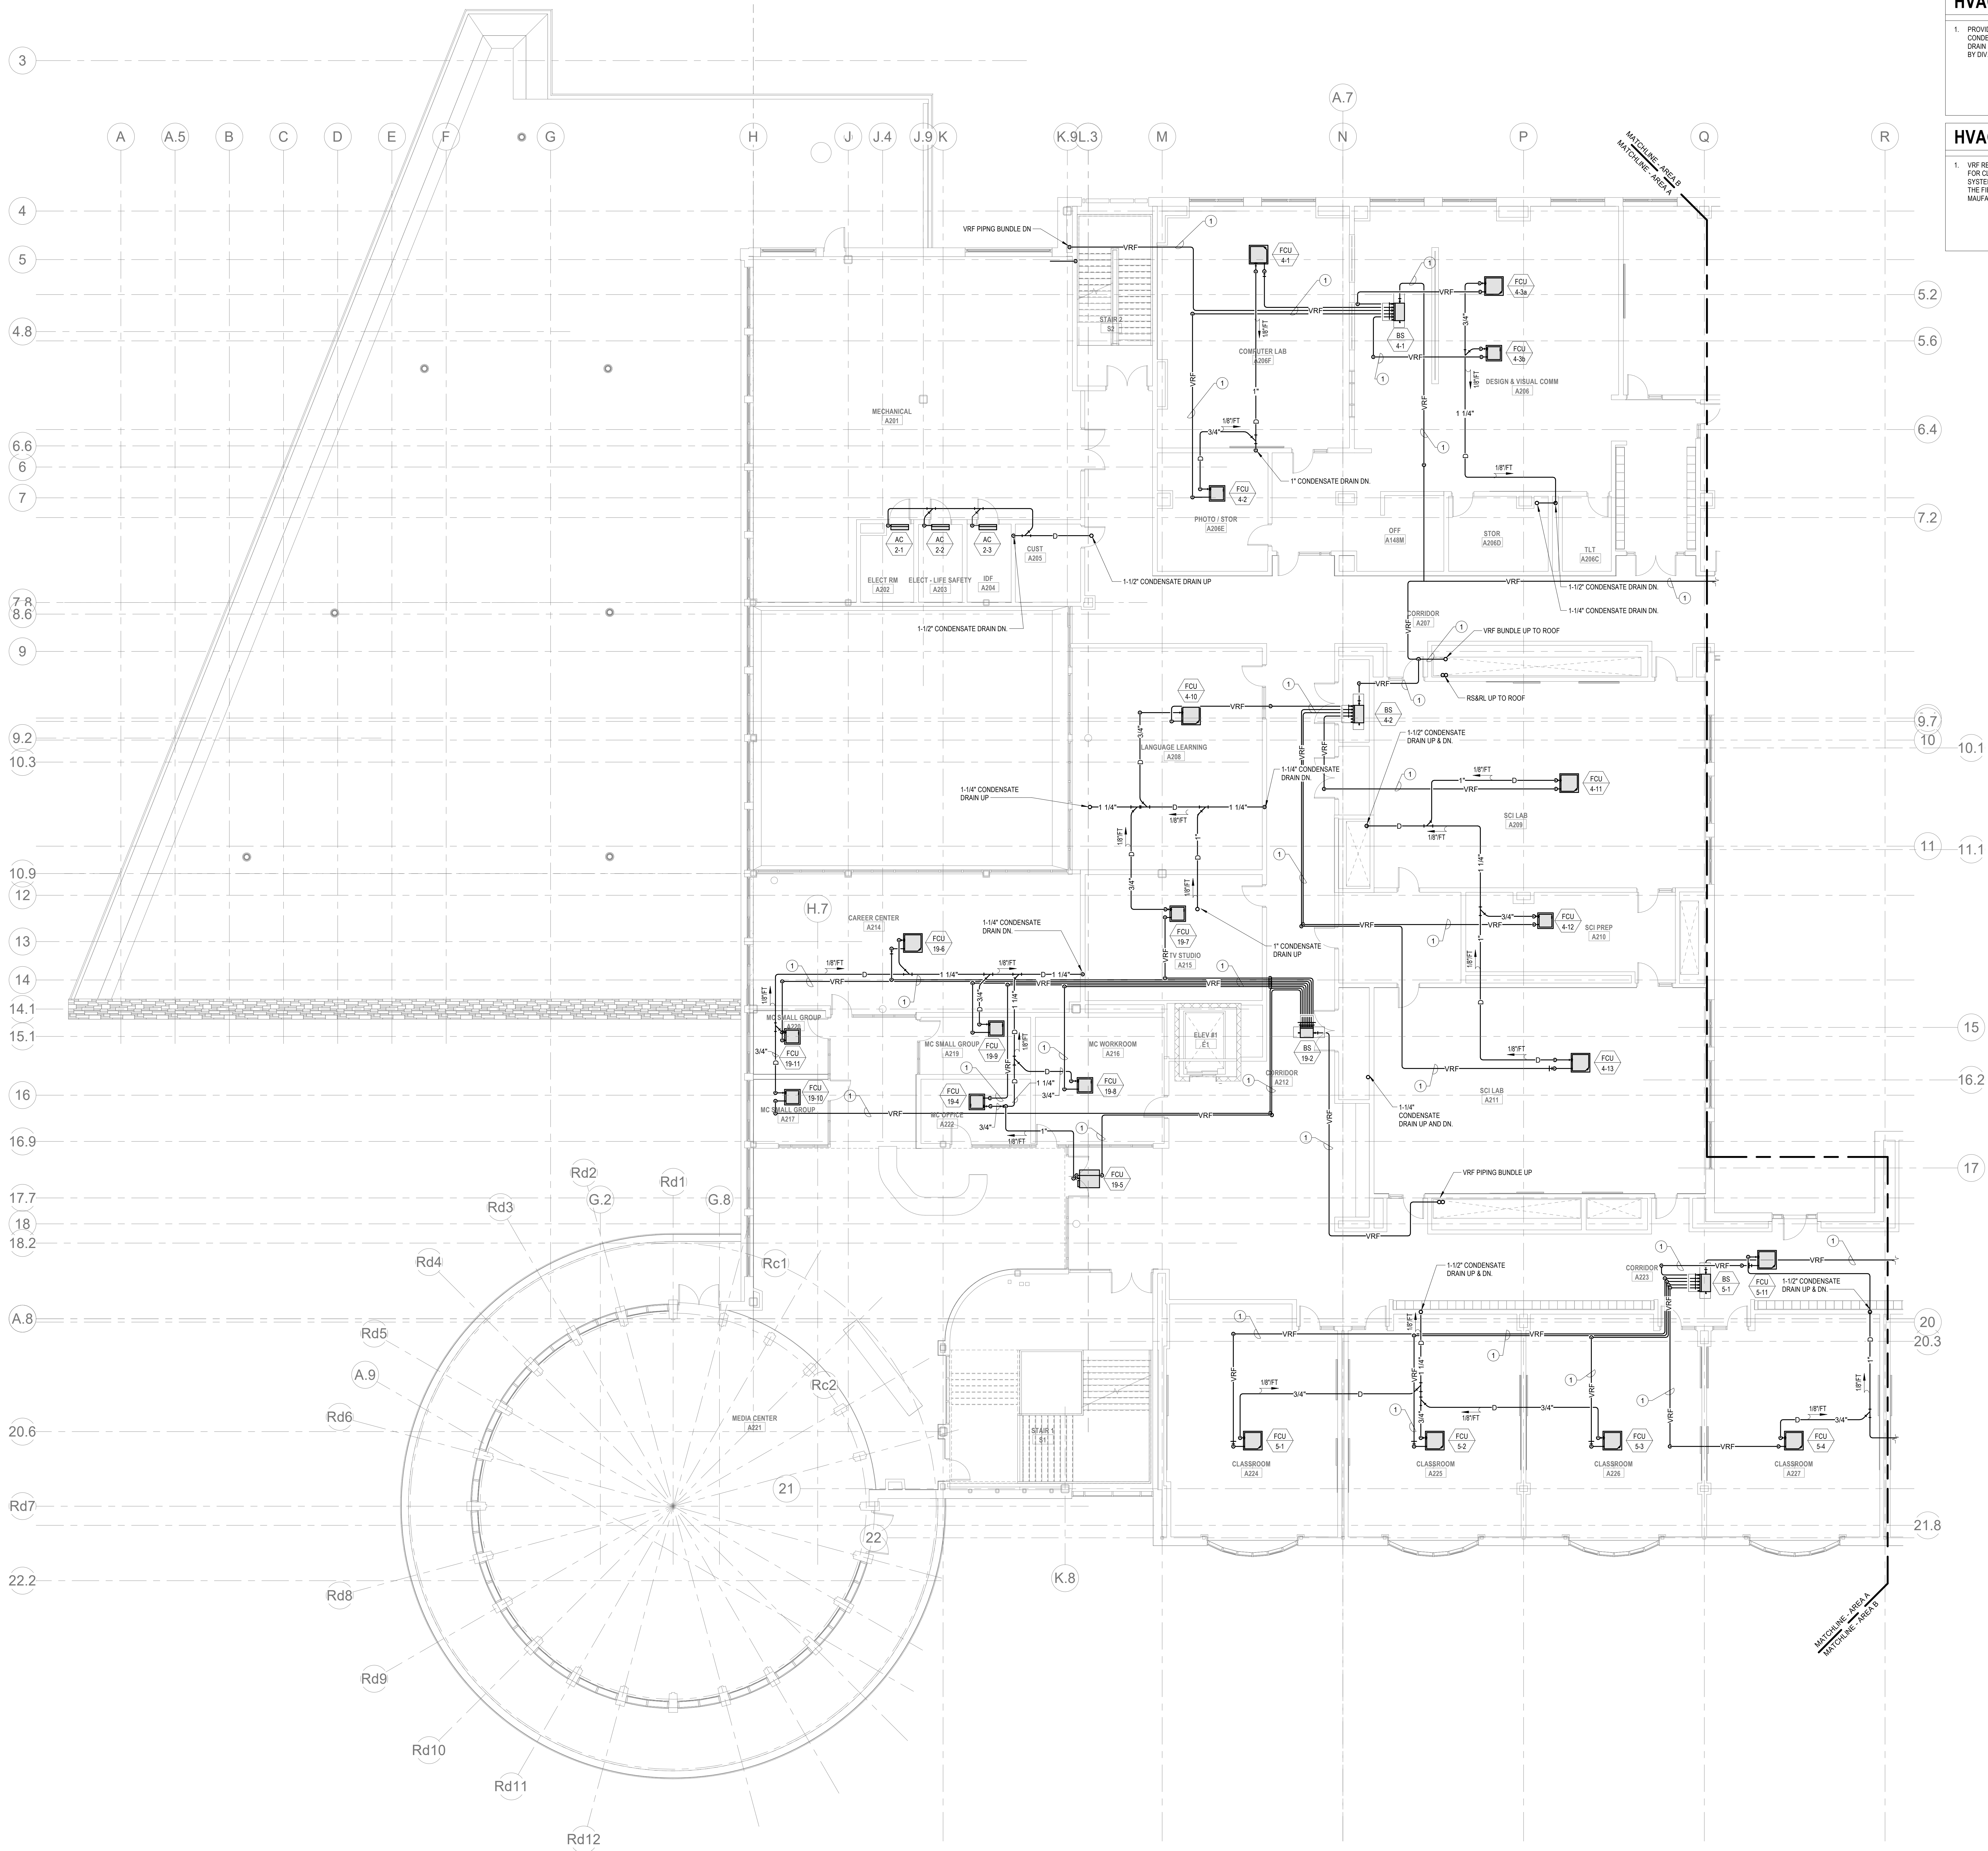

HVAC GENERAL NOTES

1. PROVIDE REFRIGERANT LINE SET FROM EACH AC UNIT TO ASSOCIATED CONDENSING UNIT ON ROOF. INTEGRAL CONDENSATE PUMP AND CONDENSATE DRAIN PIPING TO NEAREST CONDENSATE RECEPTOR. CONDENSATE RECEPTOR BY DIV. 22

HVAC DRAWING NOTES

1. VRF REFRIGERANT PIPING IS SHOWN IN A SINGLE LINE DIAGRAMATIC LAYOUT FOR CLARITY. REFER TO THE M2 SERIES DRAWINGS FOR DETAILS ON VRF SYSTEM PIPING SIZES AND QUANTITIES. ALL LENGTHS ARE TO BE CONFIRMED IN THE FIELD AND SIZES ARE TO BE COORDINATED WITH THE VRF SYSTEM MANUFACTURER PRIOR TO ORDERING.

DRA

Drummett Rosane Anderson, Inc.
225 Oakland Road
Studio 205
South Windsor, CT
06074
Planning | Architecture | Interior Design
Tel: 817.984.1700
www.dra.com

**Northeast
Metropolitan
Regional
Vocational High School**


Wakefield, MA 01880

© COPYRIGHT 2021 DRUMMETT ROSANE ANDERSON, INC.

BALA
ENGINEERS


MSBA 60% CD
SUBMISSION

January 13, 2023

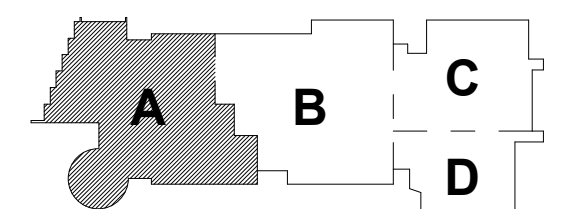

KEY PLAN

PROJECT NORTH MAGNETIC NORTH

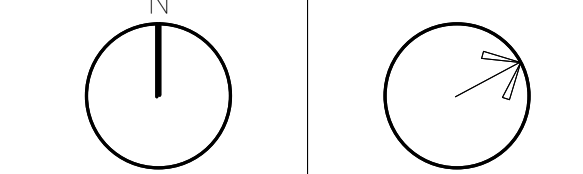

**MECHANICAL
PIPING SECOND
FLOOR PLAN -
AREA A**

Scale: 1/8" = 1'-0"
Job No.: 20202
Drawn By: DRA
Date: January 13, 2023


M1-3-2A

HVAC GENERAL NOTES

1. PROVIDE REFRIGERANT LINE SET FROM EACH AC UNIT TO ASSOCIATED CONDENSING UNIT ON ROOF. INTEGRAL CONDENSATE PUMP AND CONDENSATE DRAIN PIPING TO NEAREST CONDENSATE RECEPTOR. CONDENSATE RECEPTOR BY DIV. 22


HVAC DRAWING NOTES

1. VRF REFRIGERANT PIPING IS SHOWN IN A SINGLE LINE DIAGRAMATIC LAYOUT FOR CLARITY. REFER TO THE M2 SERIES DRAWINGS FOR DETAILS ON VRF SYSTEM PIPING SIZES AND QUANTITIES. ALL LENGTHS ARE TO BE CONFIRMED IN THE FIELD AND SIZES ARE TO BE COORDINATED WITH THE VRF SYSTEM MANUFACTURER PRIOR TO ORDERING.

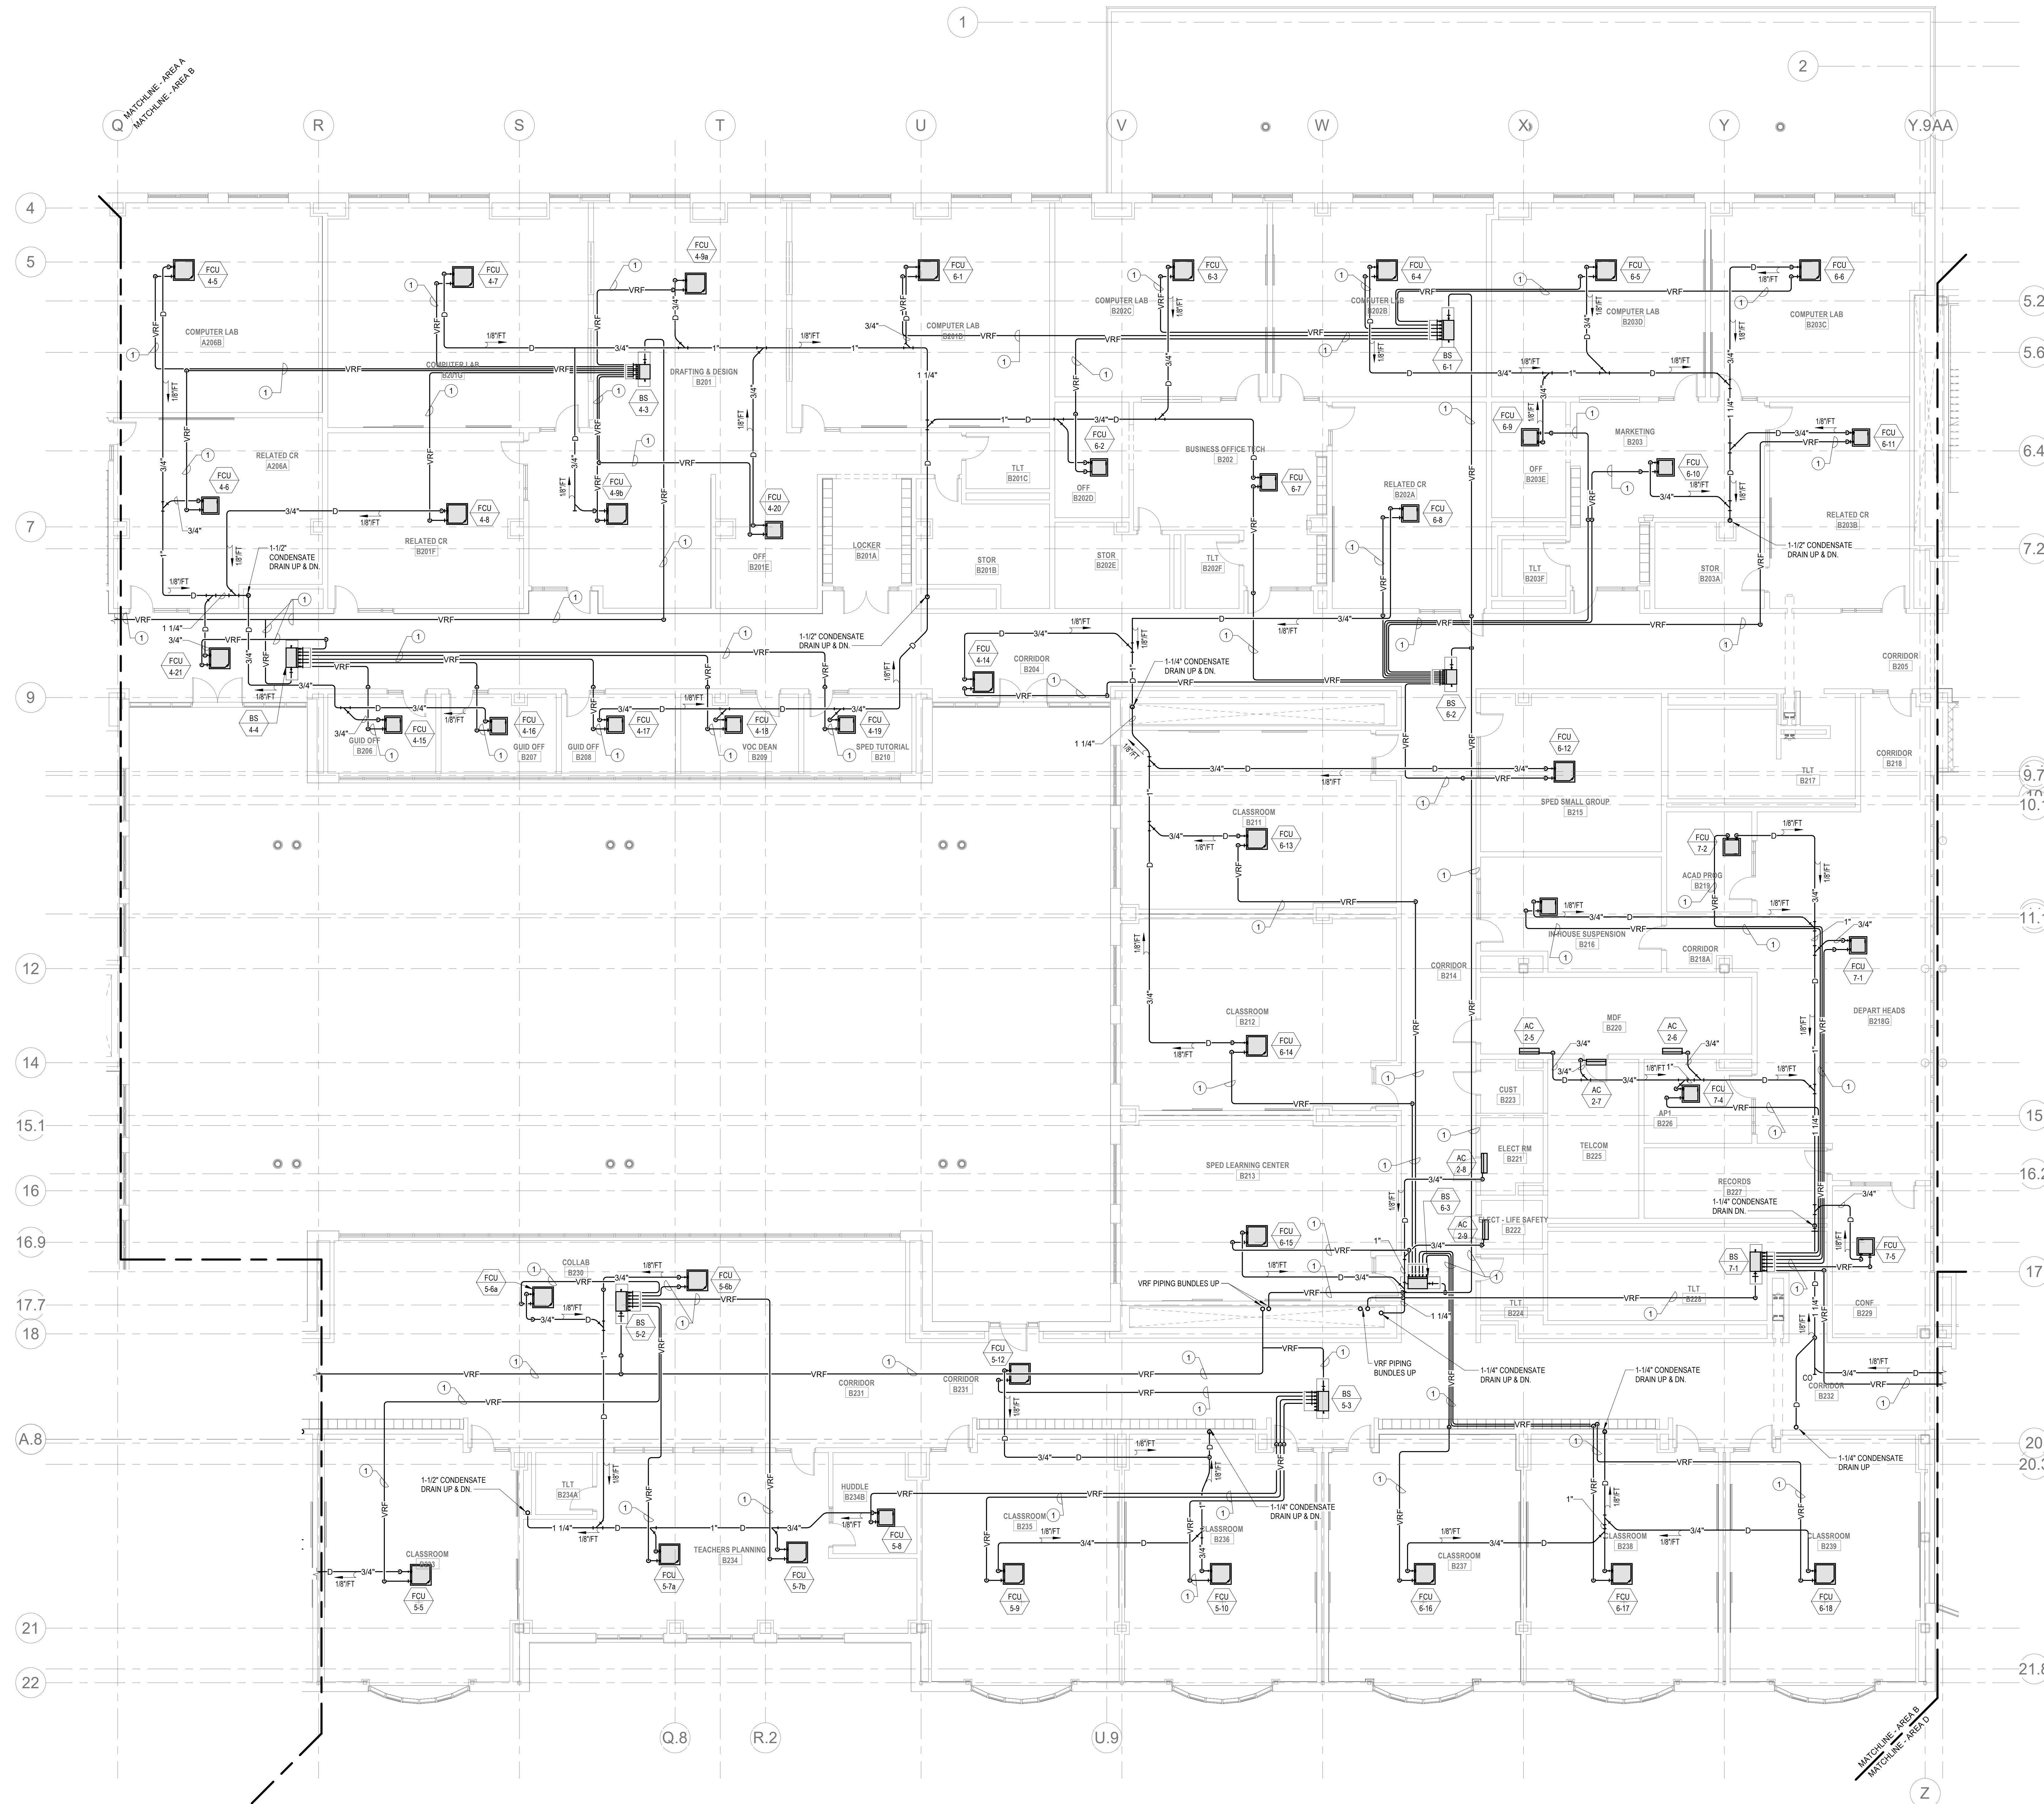

HVAC DRAWING NOTES

1. VRF REFRIGERANT PIPING IS SHOWN IN A SINGLE LINE DIAGRAMATIC LAYOUT FOR CLARITY. REFER TO THE M2 SERIES DRAWINGS FOR DETAILS ON VRF SYSTEM PIPING SIZES AND QUANTITIES. ALL LENGTHS ARE TO BE CONFIRMED IN THE FIELD AND SIZES ARE TO BE COORDINATED WITH THE VRF SYSTEM MANUFACTURER PRIOR TO ORDERING.
2. PROVIDE REFRIGERANT LINE SET FROM AG UNIT TO ASSOCIATED CONDENSING UNIT ON ROOF. INTEGRAL CONDENSATE PUMP, AND CONDENSATE DRAIN PIPING TO NEAREST CONDENSATE RECEPTOR. CONDENSATE RECEPTOR BY DIV. 22.

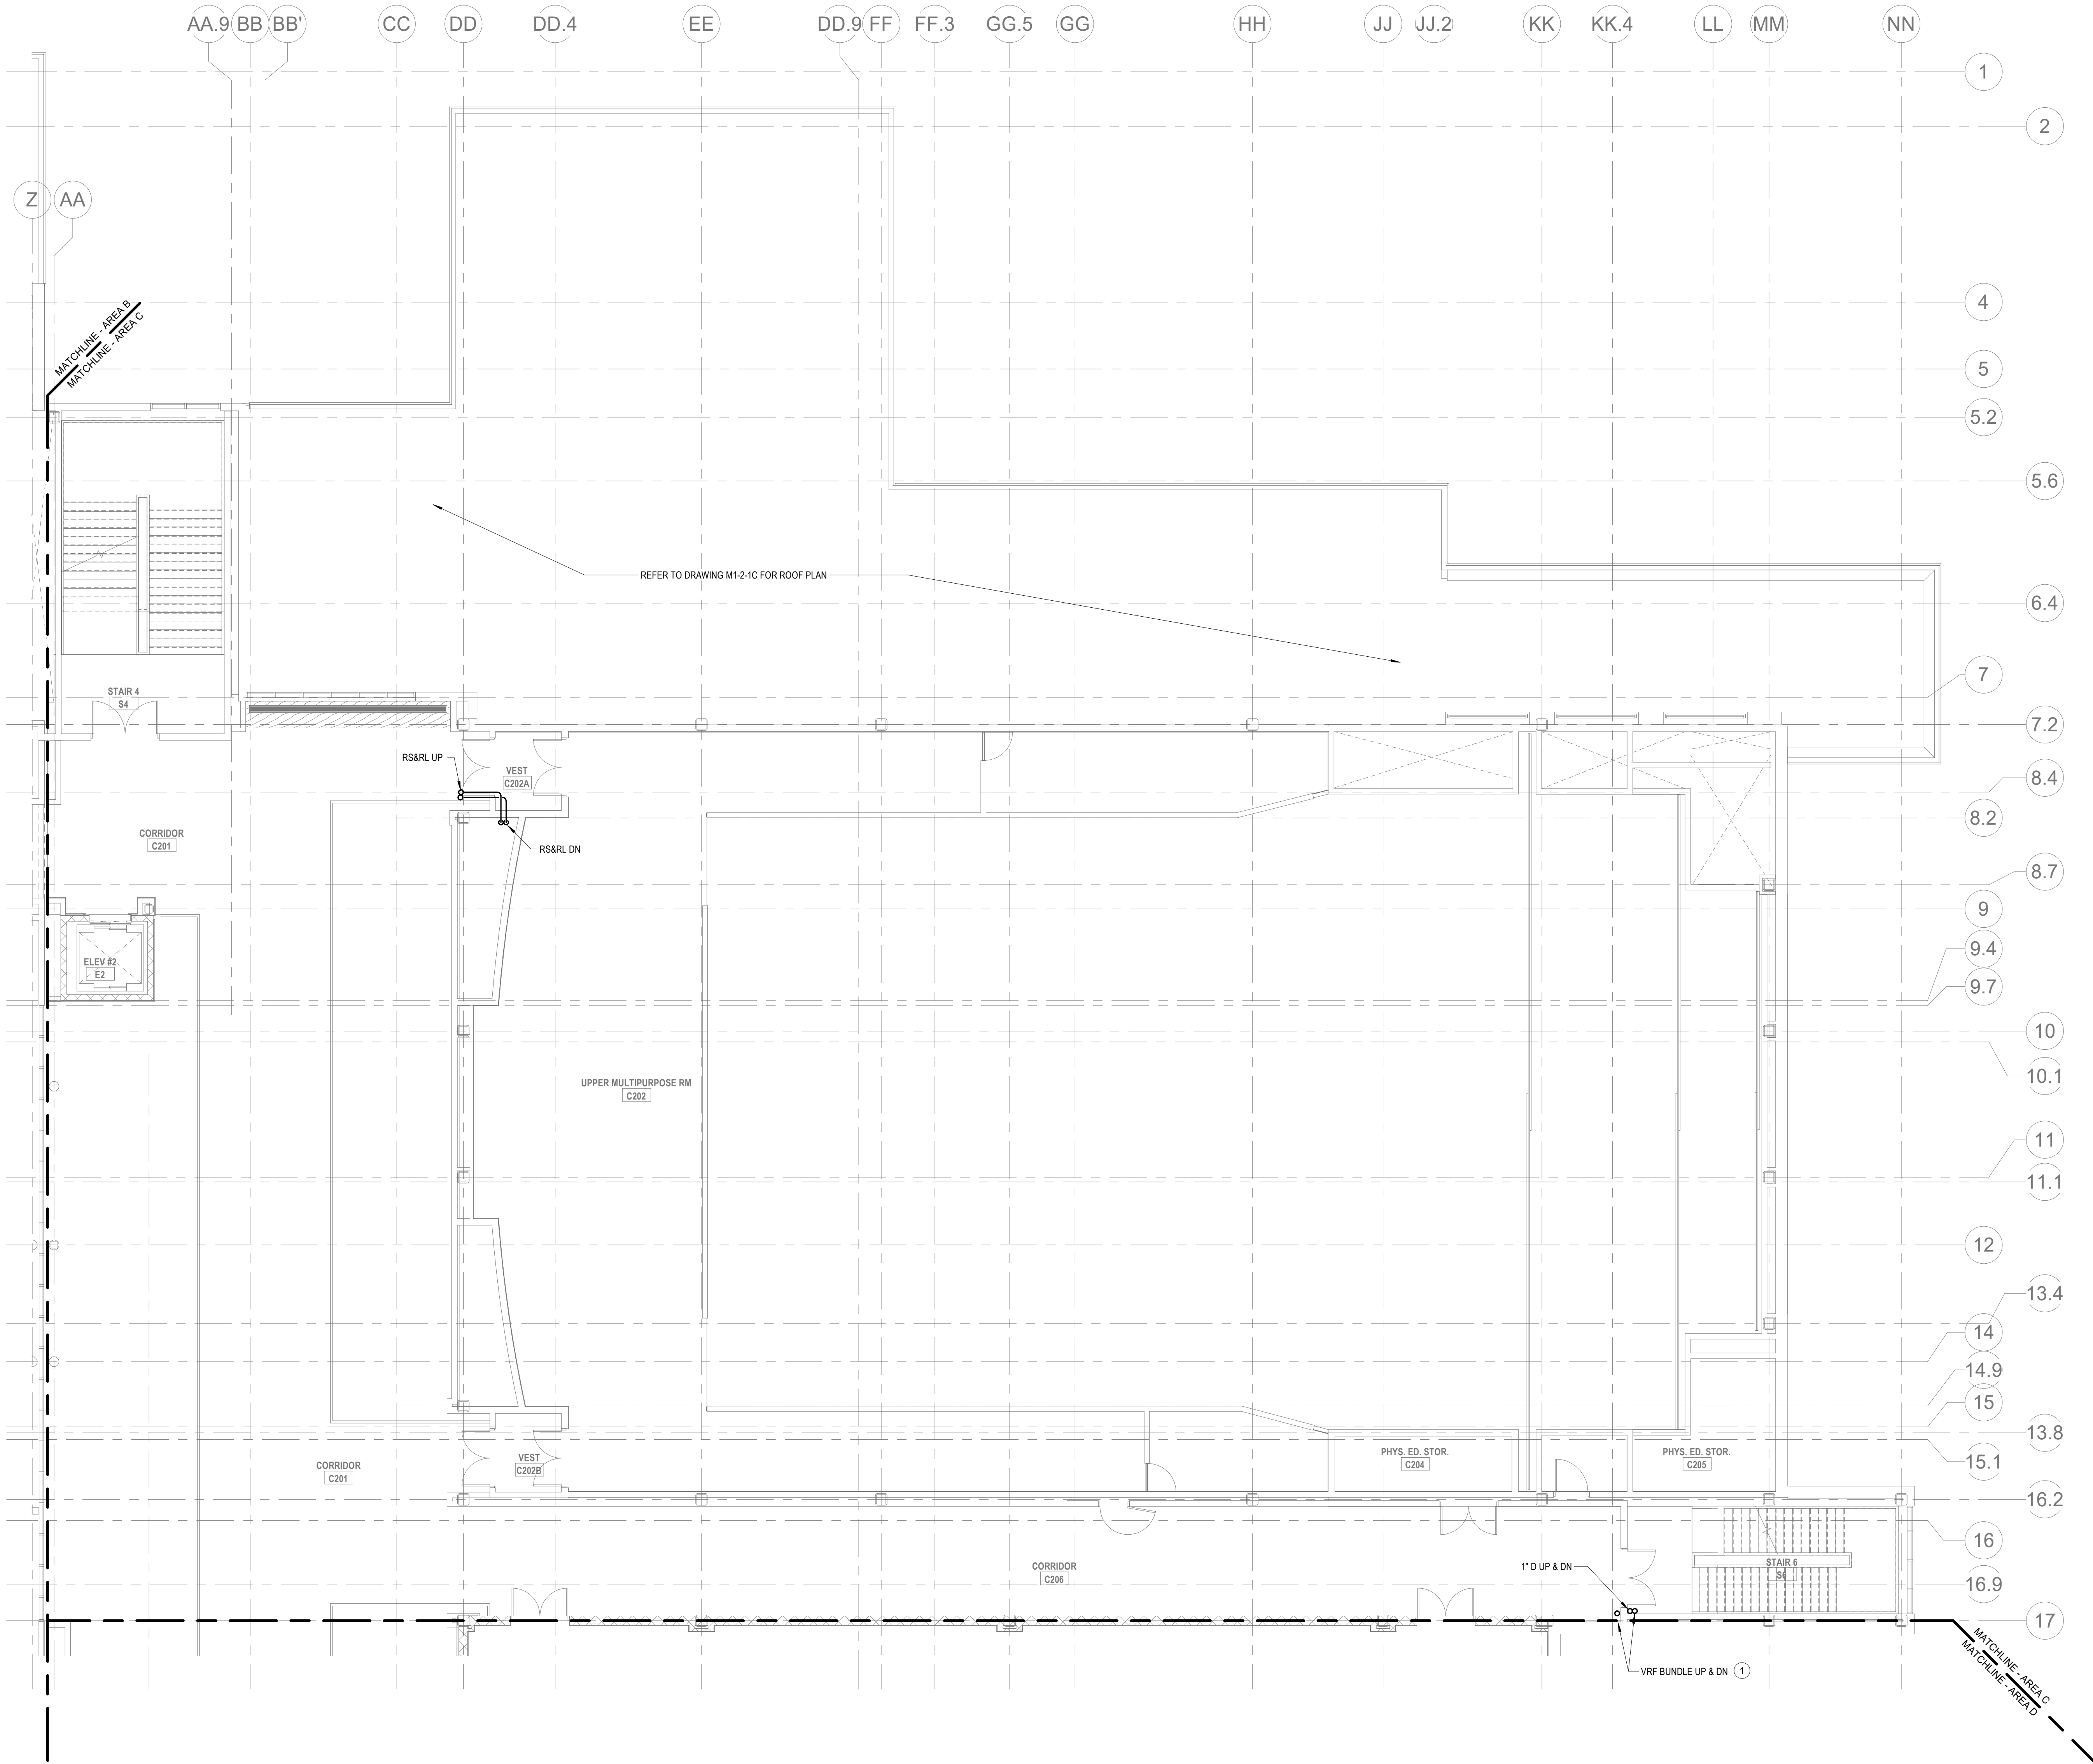

DRA

Drumme Rosane Anderson, Inc.
225 Oakland Road
Studio 205
South Windsor, CT
06074
260 Charles Street
Studio 300
Waltham, MA
02453
Planning | Architecture | Interior Design
Tel: 617.984.1700
www.draa.com


Northeast
Metropolitan
Regional
Vocational High
School

Wakefield, MA 01880


BALA
ENGINEERS
BALA CONSULTING ENGINEERS, INC.
300 WILSON ST., SUITE 200
WILSON, MA 01890
TEL: 978.267.1000 FAX: 978.267.1005
WWW.BALA-ENGINEERS.COM
ARCHITECTS, ENGINEERS, PLANNERS, INTERIORS
DESIGNERS, CONSTRUCTORS

MSBA 60% CD
SUBMISSION

January 13, 2023

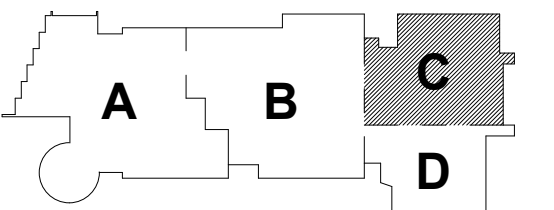

KEY PLAN

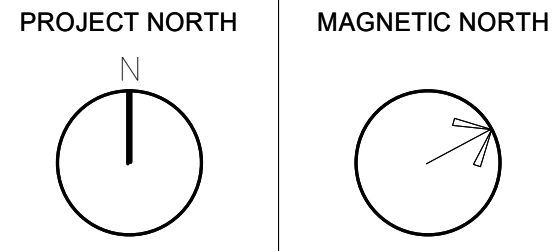


MECHANICAL
PIPING SECOND
FLOOR PLAN -
AREA C

Scale: 1/8" = 1'-0"
Job No.: 20202
Drawn By: DRA
Date: January 13, 2023
M1-3-2C

HVAC DRAWING NOTES

1. VRF REFRIGERANT PIPING IS SHOWN IN A SINGLE LINE DIAGRAMATIC LAYOUT FOR CLARITY. REFER TO THE M2 SERIES DRAWINGS FOR DETAILS ON VRF SYSTEM PIPING SIZES AND QUANTITIES. ALL LENGTHS ARE TO BE CONFIRMED IN THE FIELD AND SIZES ARE TO BE COORDINATED WITH THE VRF SYSTEM MANUFACTURER PRIOR TO ORDERING.
2. PROVIDE REFRIGERANT LINE SET FROM AG UNIT TO ASSOCIATED CONDENSING UNIT ON ROOF. INTEGRAL CONDENSATE PUMP, AND CONDENSATE DRAIN PIPING TO NEAREST CONDENSATE RECEPTOR. CONDENSATE RECEPTOR BY DIV. 22.

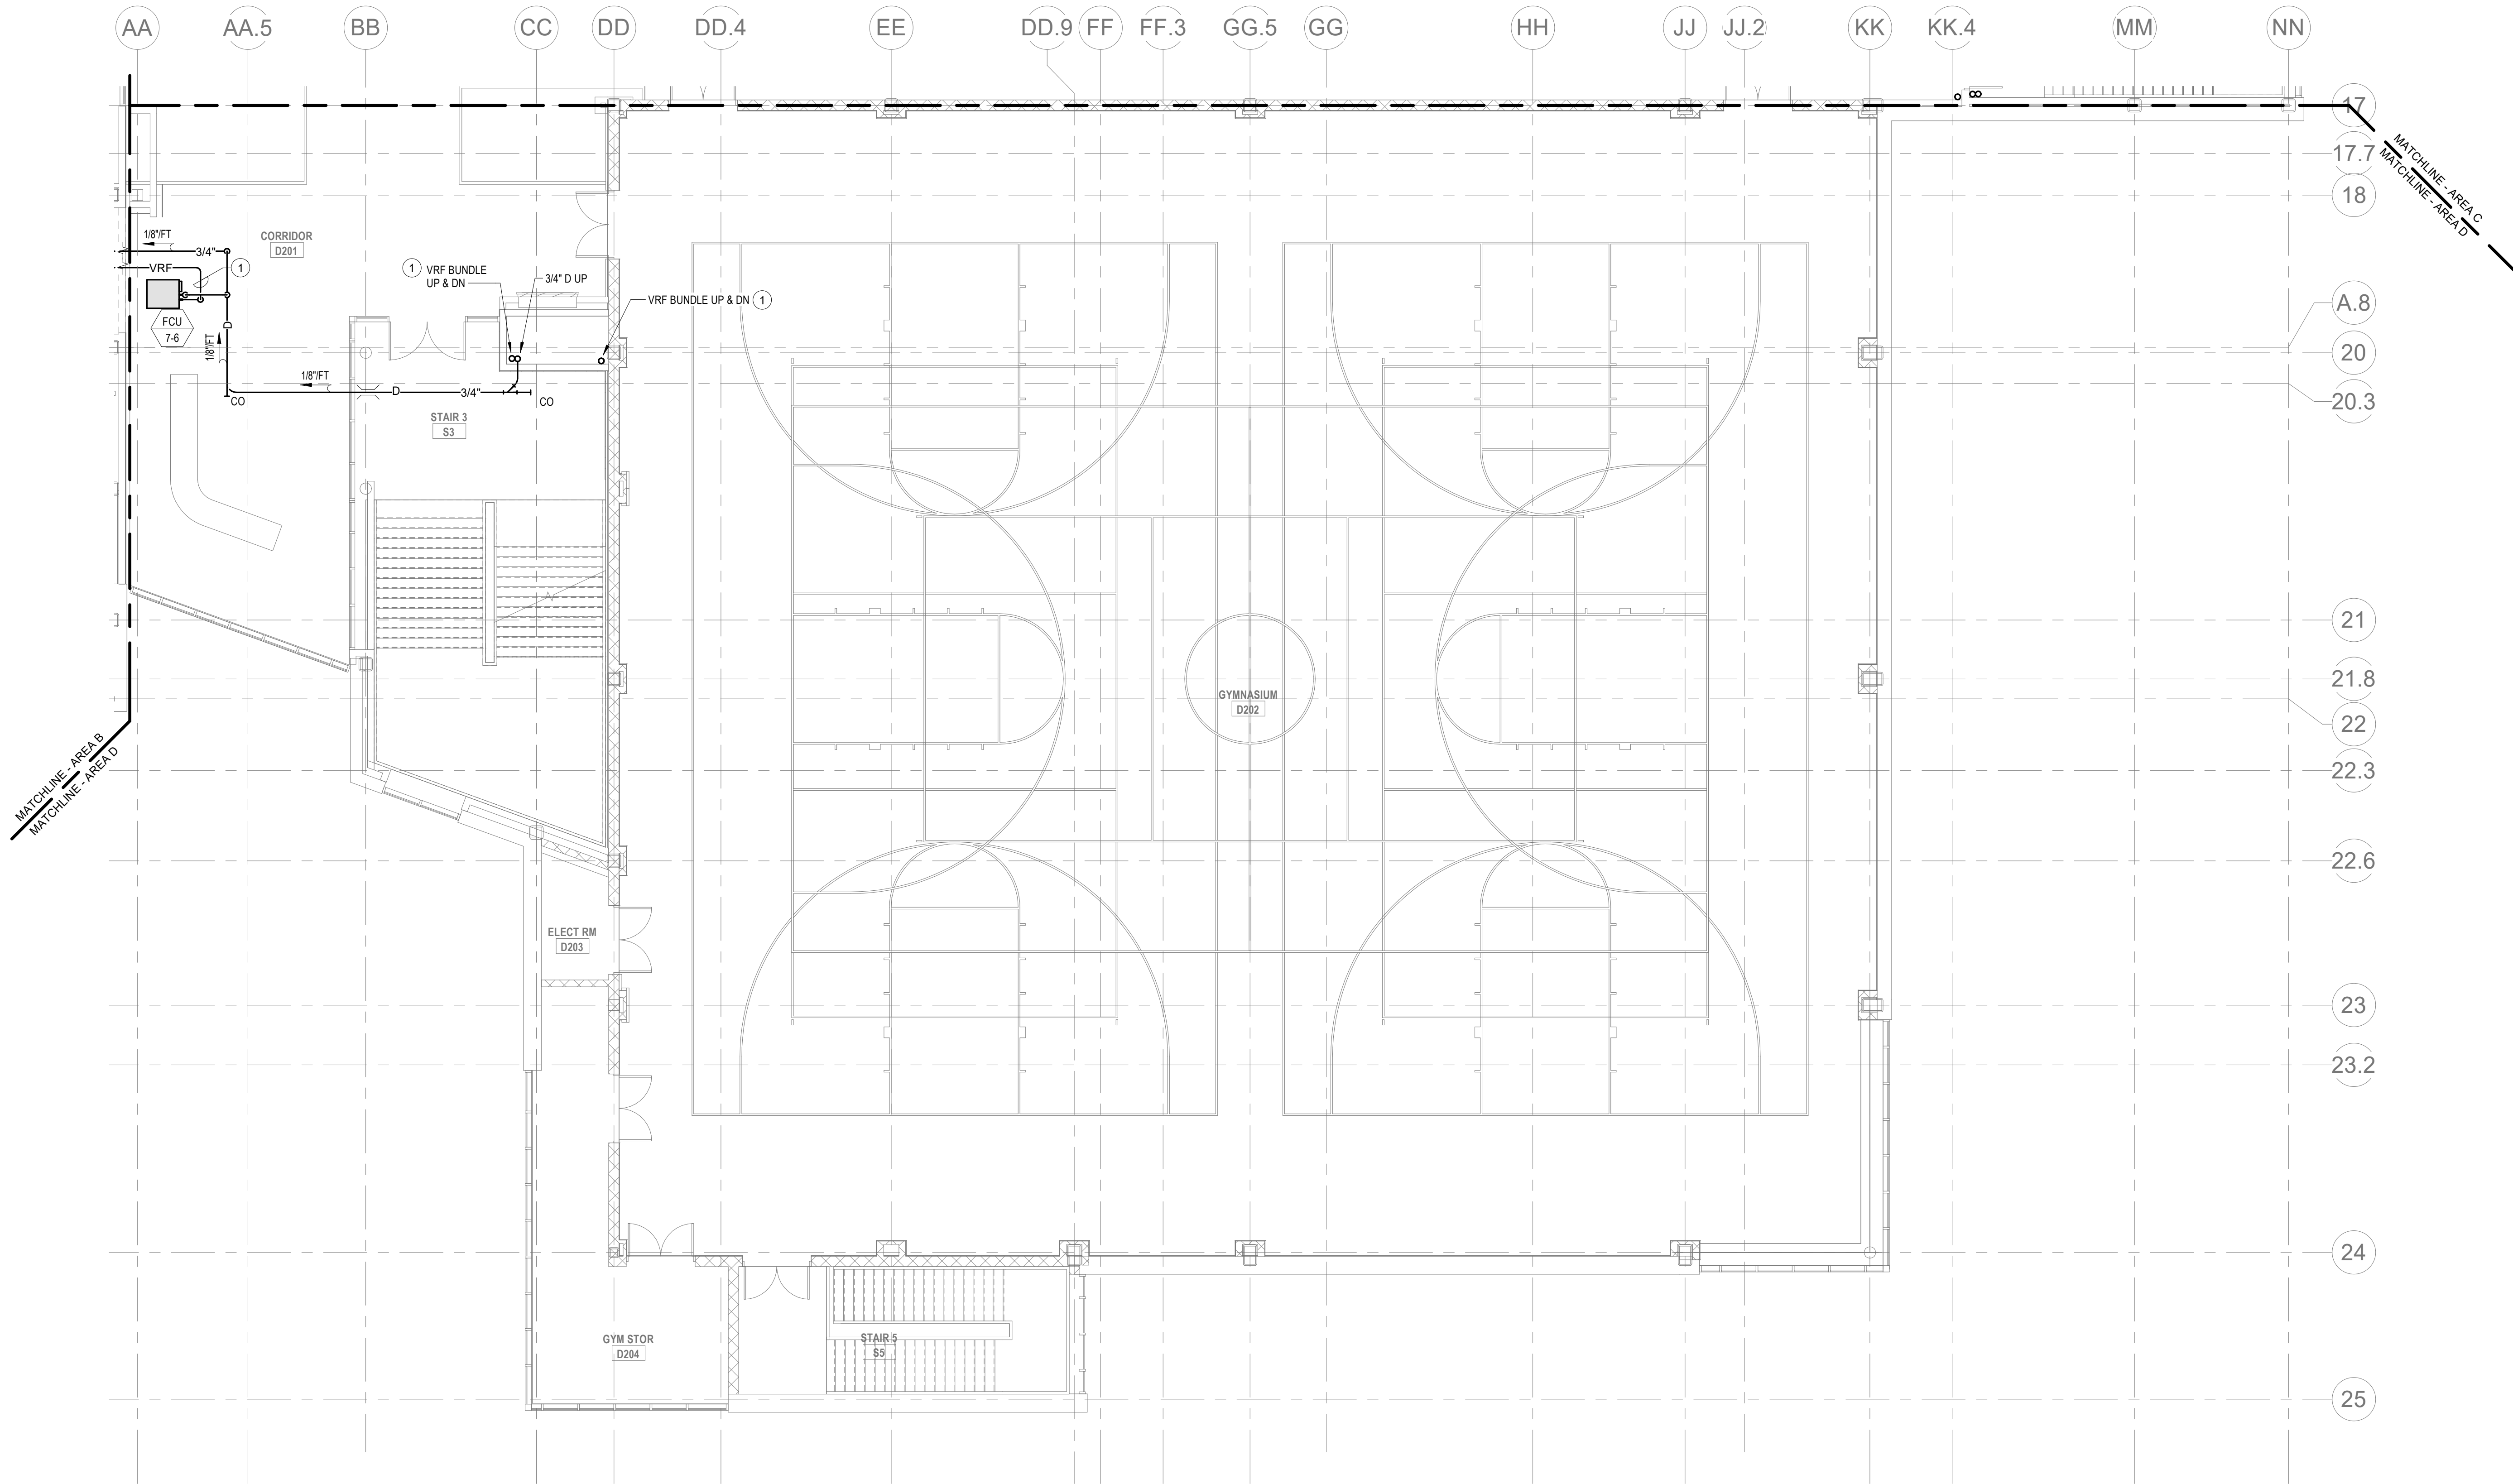

DRA

Drummeey Rosane Anderson, Inc.
225 Oakland Road
Studio 205
South Windsor, CT
06074
Planning | Architecture | Interior Design
Tel: 817.984.1700
www.dra.com

Northeast
Metropolitan
Regional
Vocational High
School


Wakefield, MA 01880

© COPYRIGHT 2021 DRUMMEY ROSANE ANDERSON, INC.


BALA
ENGINEERS
BALA CONSULTING ENGINEERS, INC.
300 WEST 10TH STREET
SUITE 200
DALLAS, TEXAS 75201
TEL: 214.760.1000 FAX: 214.760.1001
WWW.BALA-ENGINEERS.COM

MSBA 60% CD
SUBMISSION

January 13, 2023

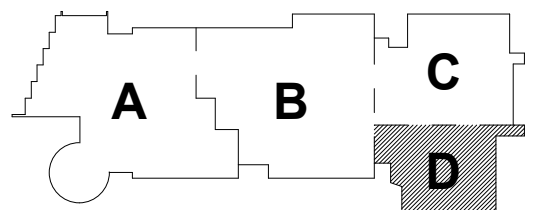


KEY PLAN

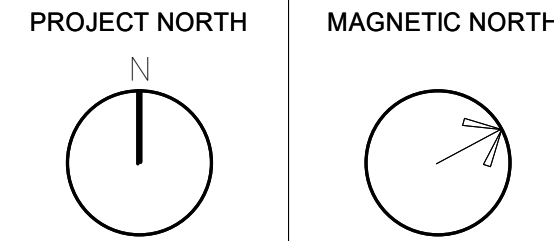

MECHANICAL
PIPING SECOND
FLOOR PLAN -
AREA D

Scale: 1/8" = 1'-0"
Job No.: 20202
Drawn By: DRA
Date: January 13, 2023

M1-3-2D

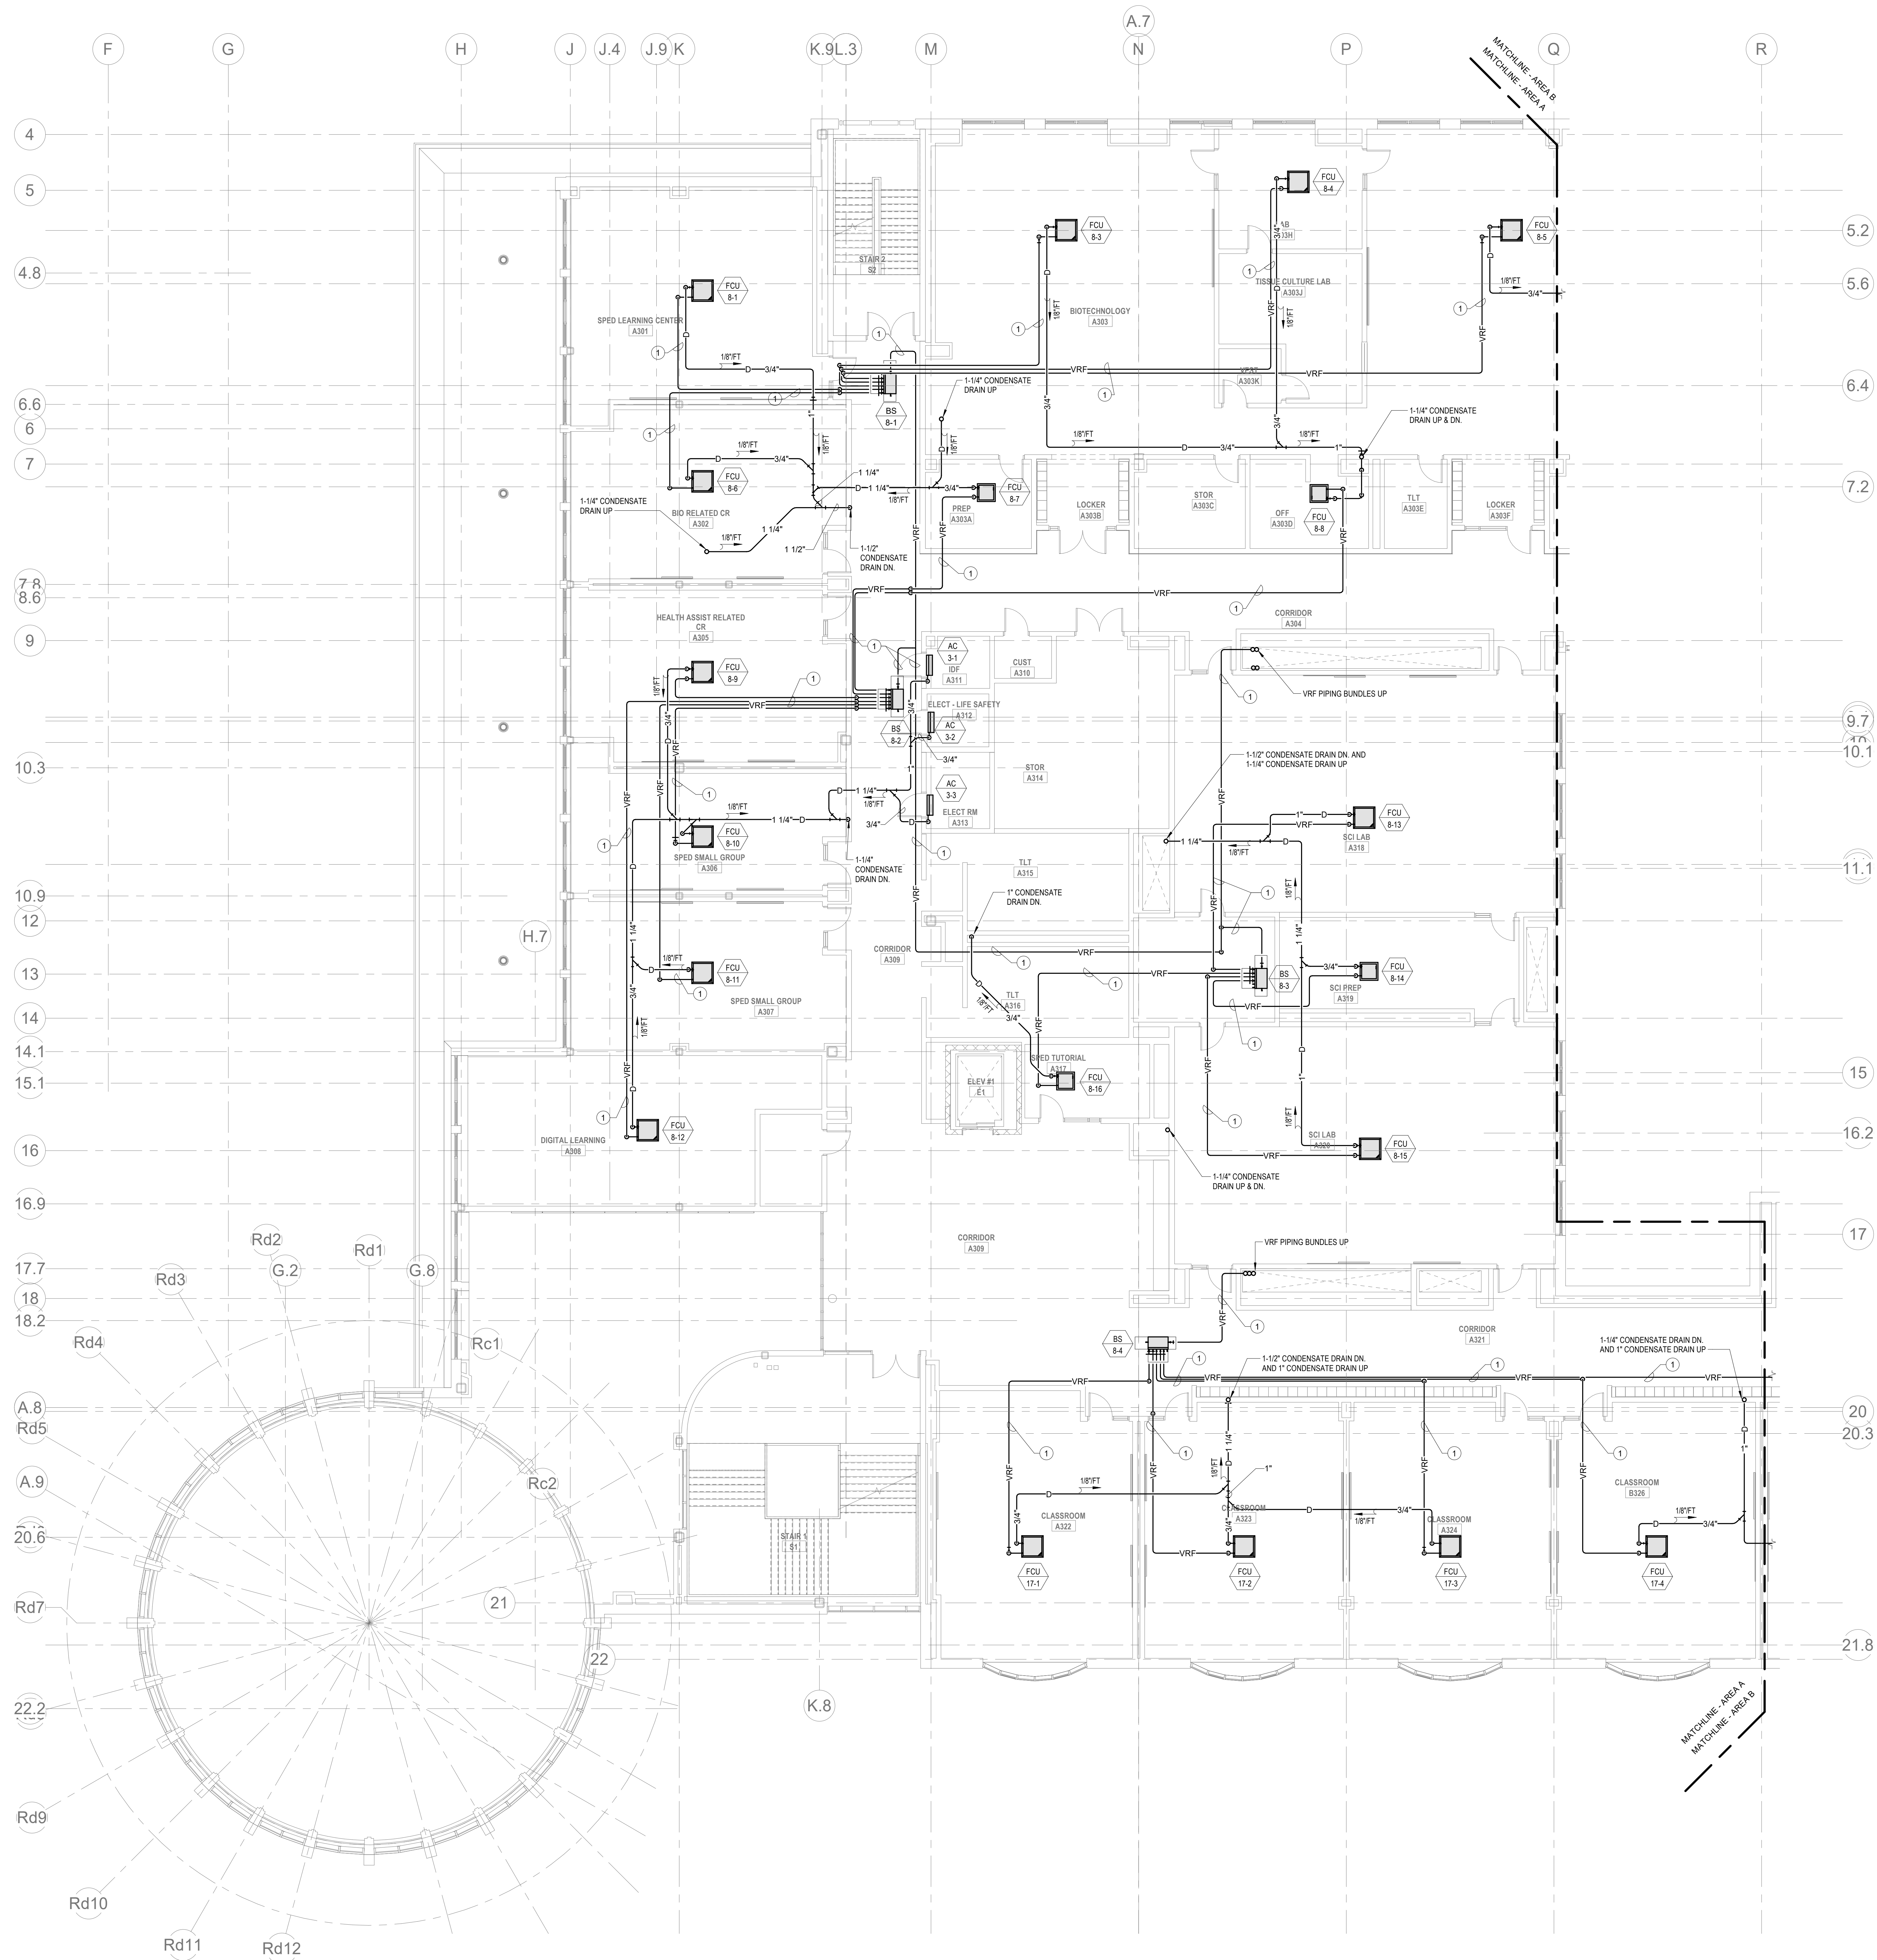

HVAC GENERAL NOTES

1. PROVIDE REFRIGERANT LINE SET FROM EACH AC UNIT TO ASSOCIATED CONDENSING UNIT ON ROOF. INTEGRAL CONDENSATE PUMP AND CONDENSATE DRAIN PIPING TO NEAREST CONDENSATE RECEPTOR. CONDENSATE RECEPTOR BY DIV. 22

HVAC DRAWING NOTES

1. VRF REFRIGERANT PIPING IS SHOWN IN A SINGLE LINE DIAGRAMATIC LAYOUT FOR CLARITY. REFER TO THE M2 SERIES DRAWINGS FOR DETAILS ON VRF SYSTEM PIPING SIZES AND QUANTITIES. ALL LENGTHS ARE TO BE CONFIRMED IN THE FIELD AND SIZES ARE TO BE COORDINATED WITH THE VRF SYSTEM MANUFACTURER PRIOR TO ORDERING.

DRA

Drumme Rosane Anderson, Inc.
225 Oakland Road
Studio 205
South Windsor, CT
06074
Planning | Architecture | Interior Design
Tel: 817.984.1700
www.dra.com

Northeast
Metropolitan
Regional
Vocational High
School


Wakefield, MA 01880

© COPYRIGHT 2021 DRUMME ROSANE ANDERSON, INC.

BALA
ENGINEERS
BALA CONSULTING ENGINEERS, INC.
300 WEST 10TH STREET
SUITE 200
DALLAS, TEXAS 75201
TEL: 214.766.1100 FAX: 214.766.1101
WWW.BALA-ENGINEERS.COM


MSBA 60% CD
SUBMISSION

January 13, 2023

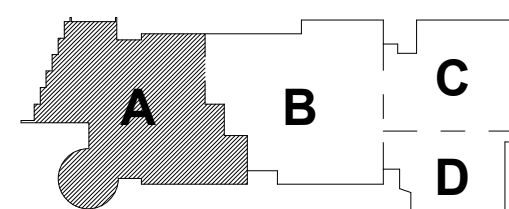


KEY PLAN

PROJECT NORTH

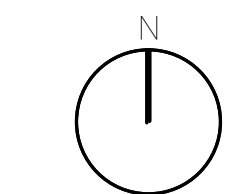

MAGNETIC NORTH

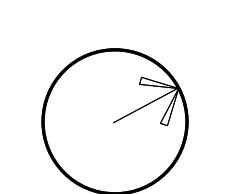

MECHANICAL
PIPING THIRD
FLOOR PLAN -
AREA A

Scale: 1/8" = 1'-0"
Job No.: 20202
Drawn By: DRA
Date: January 13, 2023


M1-3-3A

HVAC GENERAL NOTES

1. PROVIDE REFRIGERANT LINE SET FROM EACH AC UNIT TO ASSOCIATED CONDENSING UNIT ON ROOF. INTEGRAL CONDENSATE PUMP AND CONDENSATE DRAIN PIPING TO NEAREST CONDENSATE RECEPTOR. CONDENSATE RECEPTOR BY DIV. 22.

HVAC DRAWING NOTES

1. VRF REFRIGERANT PIPING IS SHOWN IN A SINGLE LINE DIAGRAMMATIC LAYOUT FOR CLARITY. REFER TO THE ME SERIES DRAWINGS FOR DETAILS ON VRF SYSTEM PIPING SIZES AND QUANTITIES. ALL LENGTHS ARE TO BE CONFIRMED IN THE FIELD AND SIZES ARE TO BE COORDINATED WITH THE VRF SYSTEM MANUFACTURER PRIOR TO ORDERING.

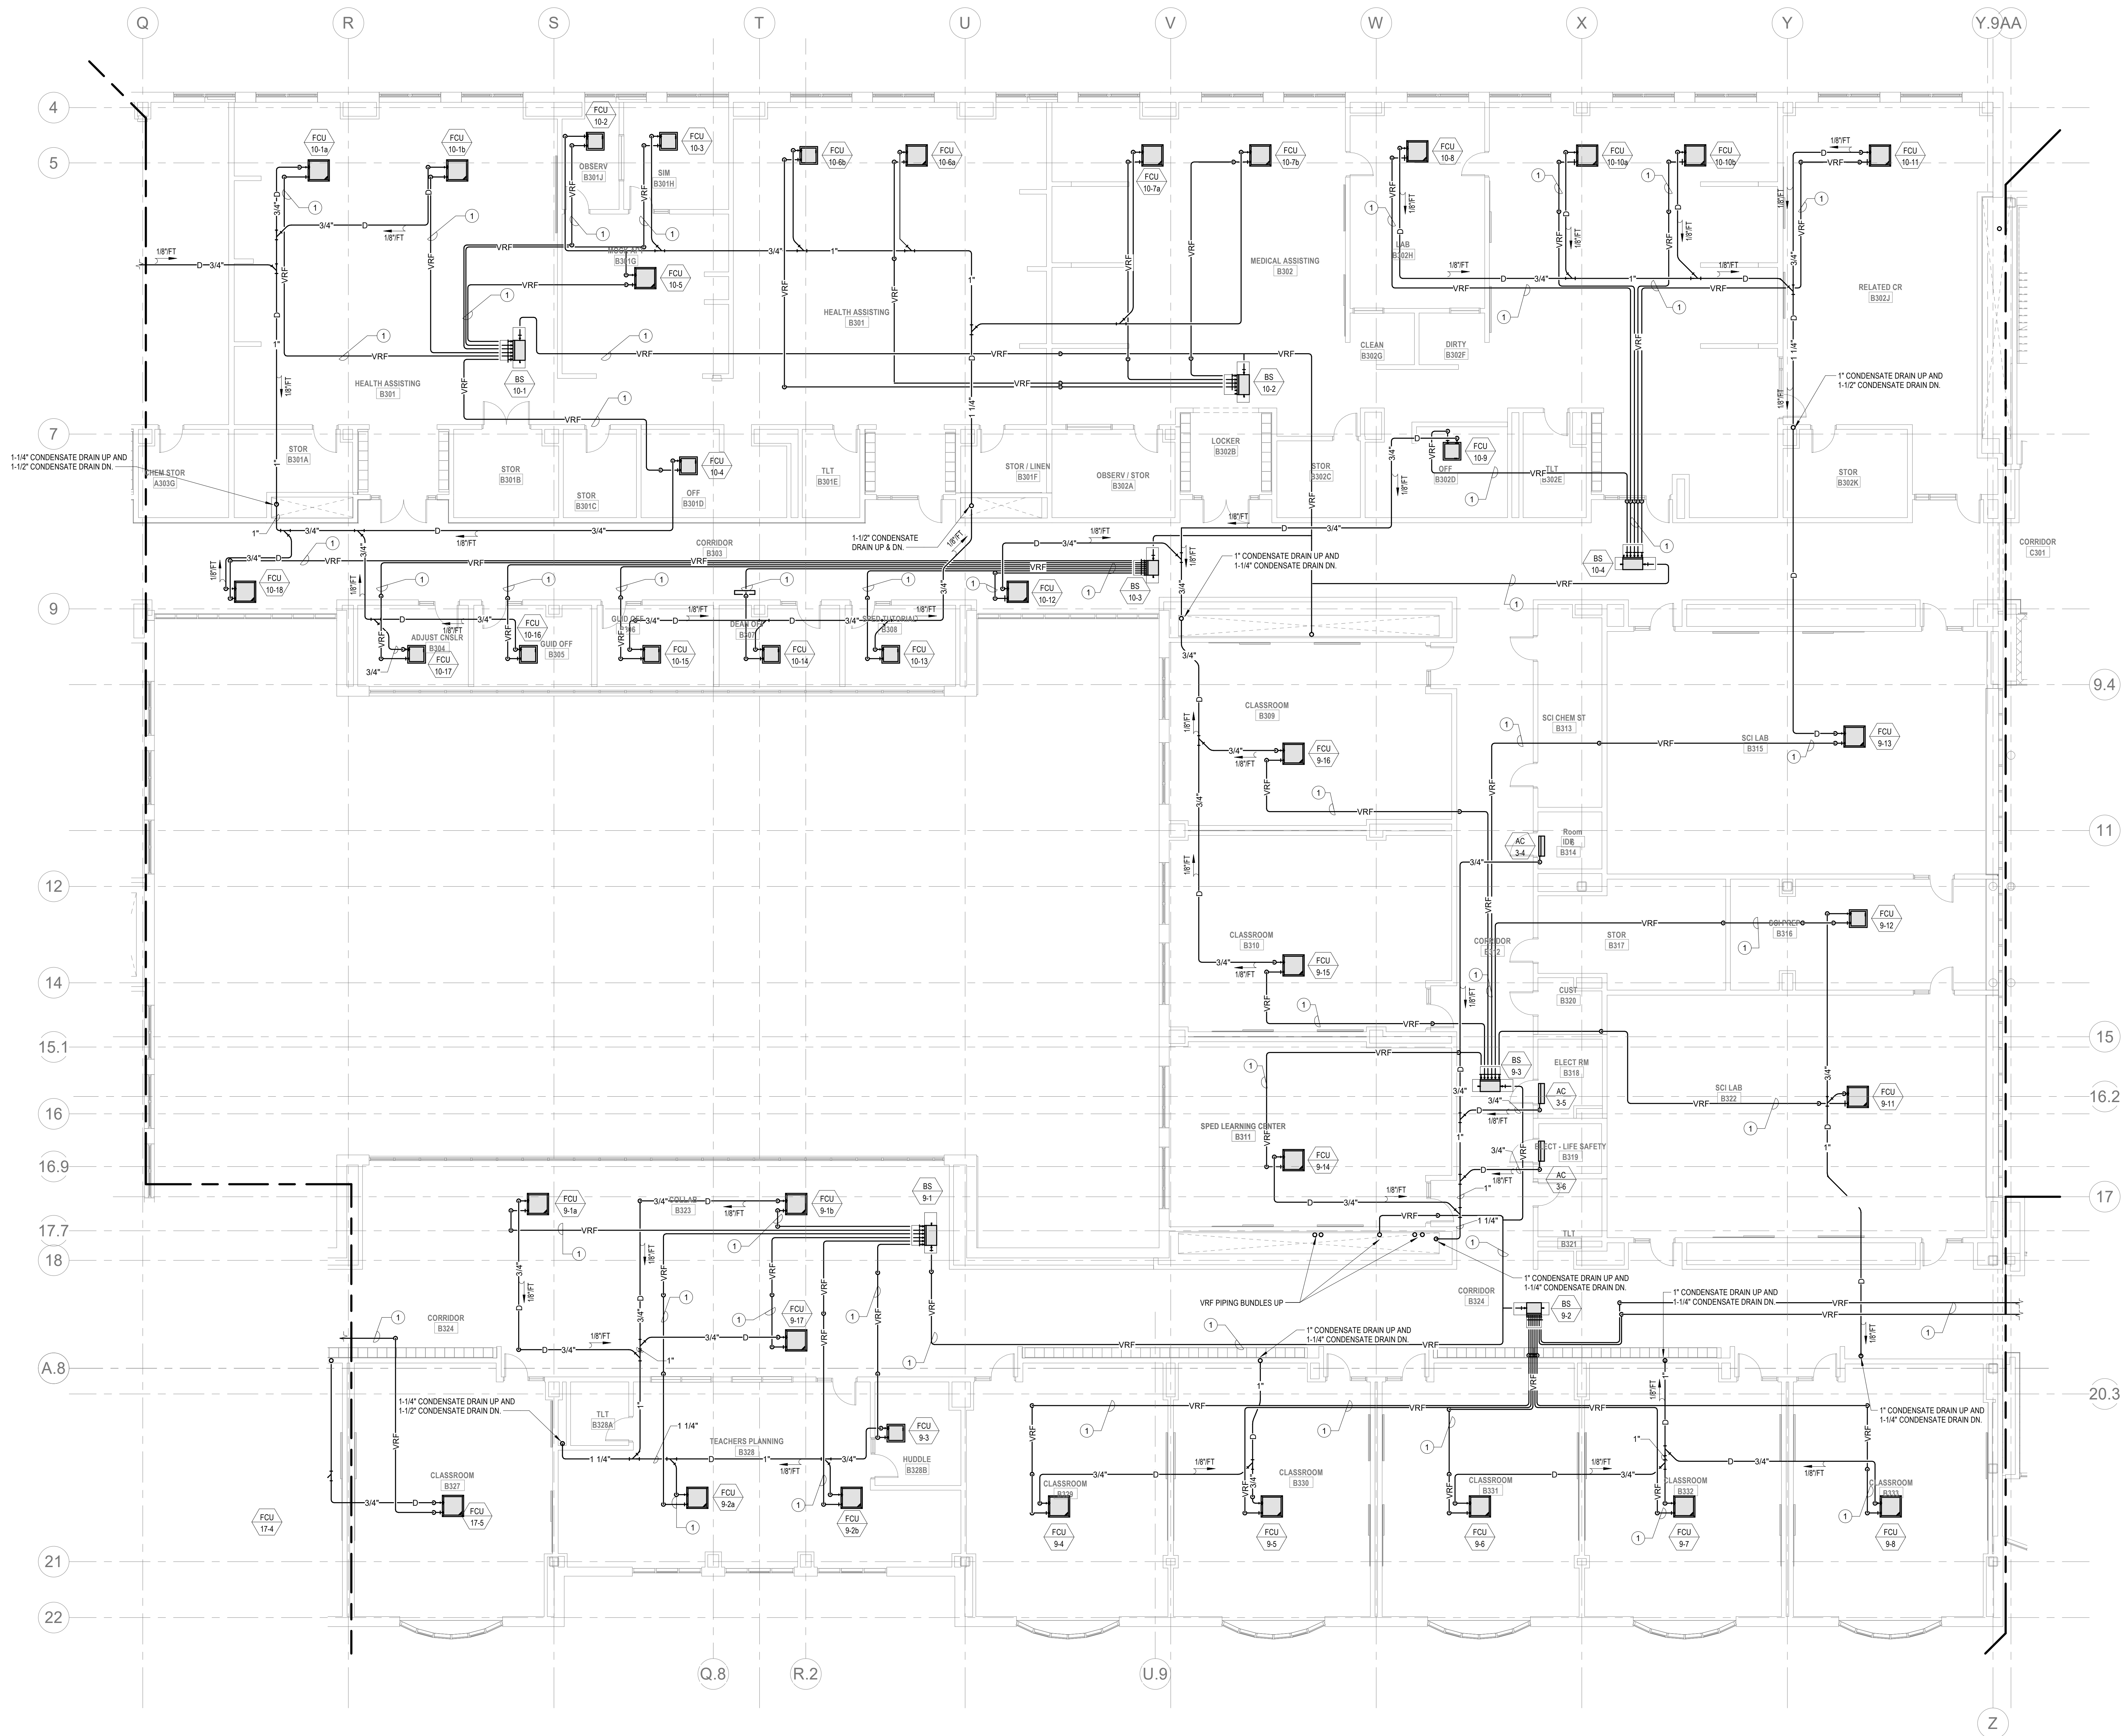

DRA

Drumme Rosane Anderson, Inc.
225 Oakland Road
Studio 205
South Windsor, CT
06074
Planning | Architecture | Interior Design
Tel: 817.984.1702
www.dra.com

Northeast
Metropolitan
Regional
Vocational High
School


Wakefield, MA 01880

© COPYRIGHT 2021 DRUMME ROSANE ANDERSON, INC.

BALA
ENGINEERS


MSBA 60% CD
SUBMISSION

January 13, 2023

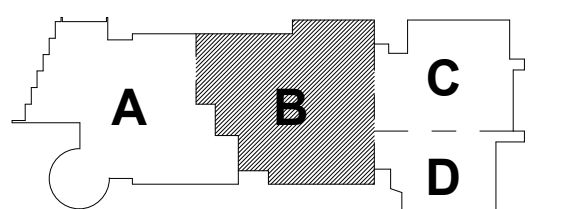

KEY PLAN

PROJECT NORTH MAGNETIC NORTH

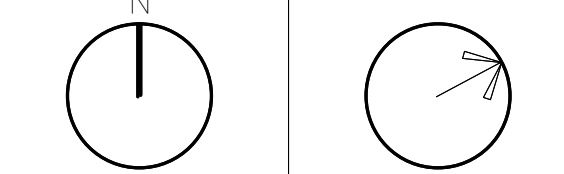

MECHANICAL
PIPING THIRD
FLOOR PLAN -
AREA B

Scale: 1/8" = 1'-0"
Job No.: 20202
Drawn By: DRA
Date: January 13, 2023

M1-3-3B

HVAC DRAWING NOTES

1. VRF REFRIGERANT PIPING IS SHOWN IN A SINGLE LINE DIAGRAMATIC LAYOUT FOR CLARITY. REFER TO THE M2 SERIES DRAWINGS FOR DETAILS ON VRF SYSTEM PIPING SIZES AND QUANTITIES. ALL LENGTHS ARE TO BE CONFIRMED IN THE FIELD AND SIZES ARE TO BE COORDINATED WITH THE VRF SYSTEM MANUFACTURER PRIOR TO ORDERING.
2. PROVIDE REFRIGERANT LINE SET FROM AG UNIT TO ASSOCIATED CONDENSING UNIT ON ROOF. INTEGRAL CONDENSATE PUMP AND CONDENSATE DRAIN PIPING TO NEAREST CONDENSATE RECEPTOR. CONDENSATE RECEPTOR BY DIV. 22.

DRA


Drummeey Rosane Anderson, Inc.
225 Oakland Road
Studio 205
South Windsor, CT 06074

280 Charles Street
Studio 300
Waltham, MA 02453

Planning | Architecture | Interior Design
Tel: 617.984.1700
www.draan.com

Northeast
Metropolitan
Regional
Vocational High
School

Wakefield, MA 01880

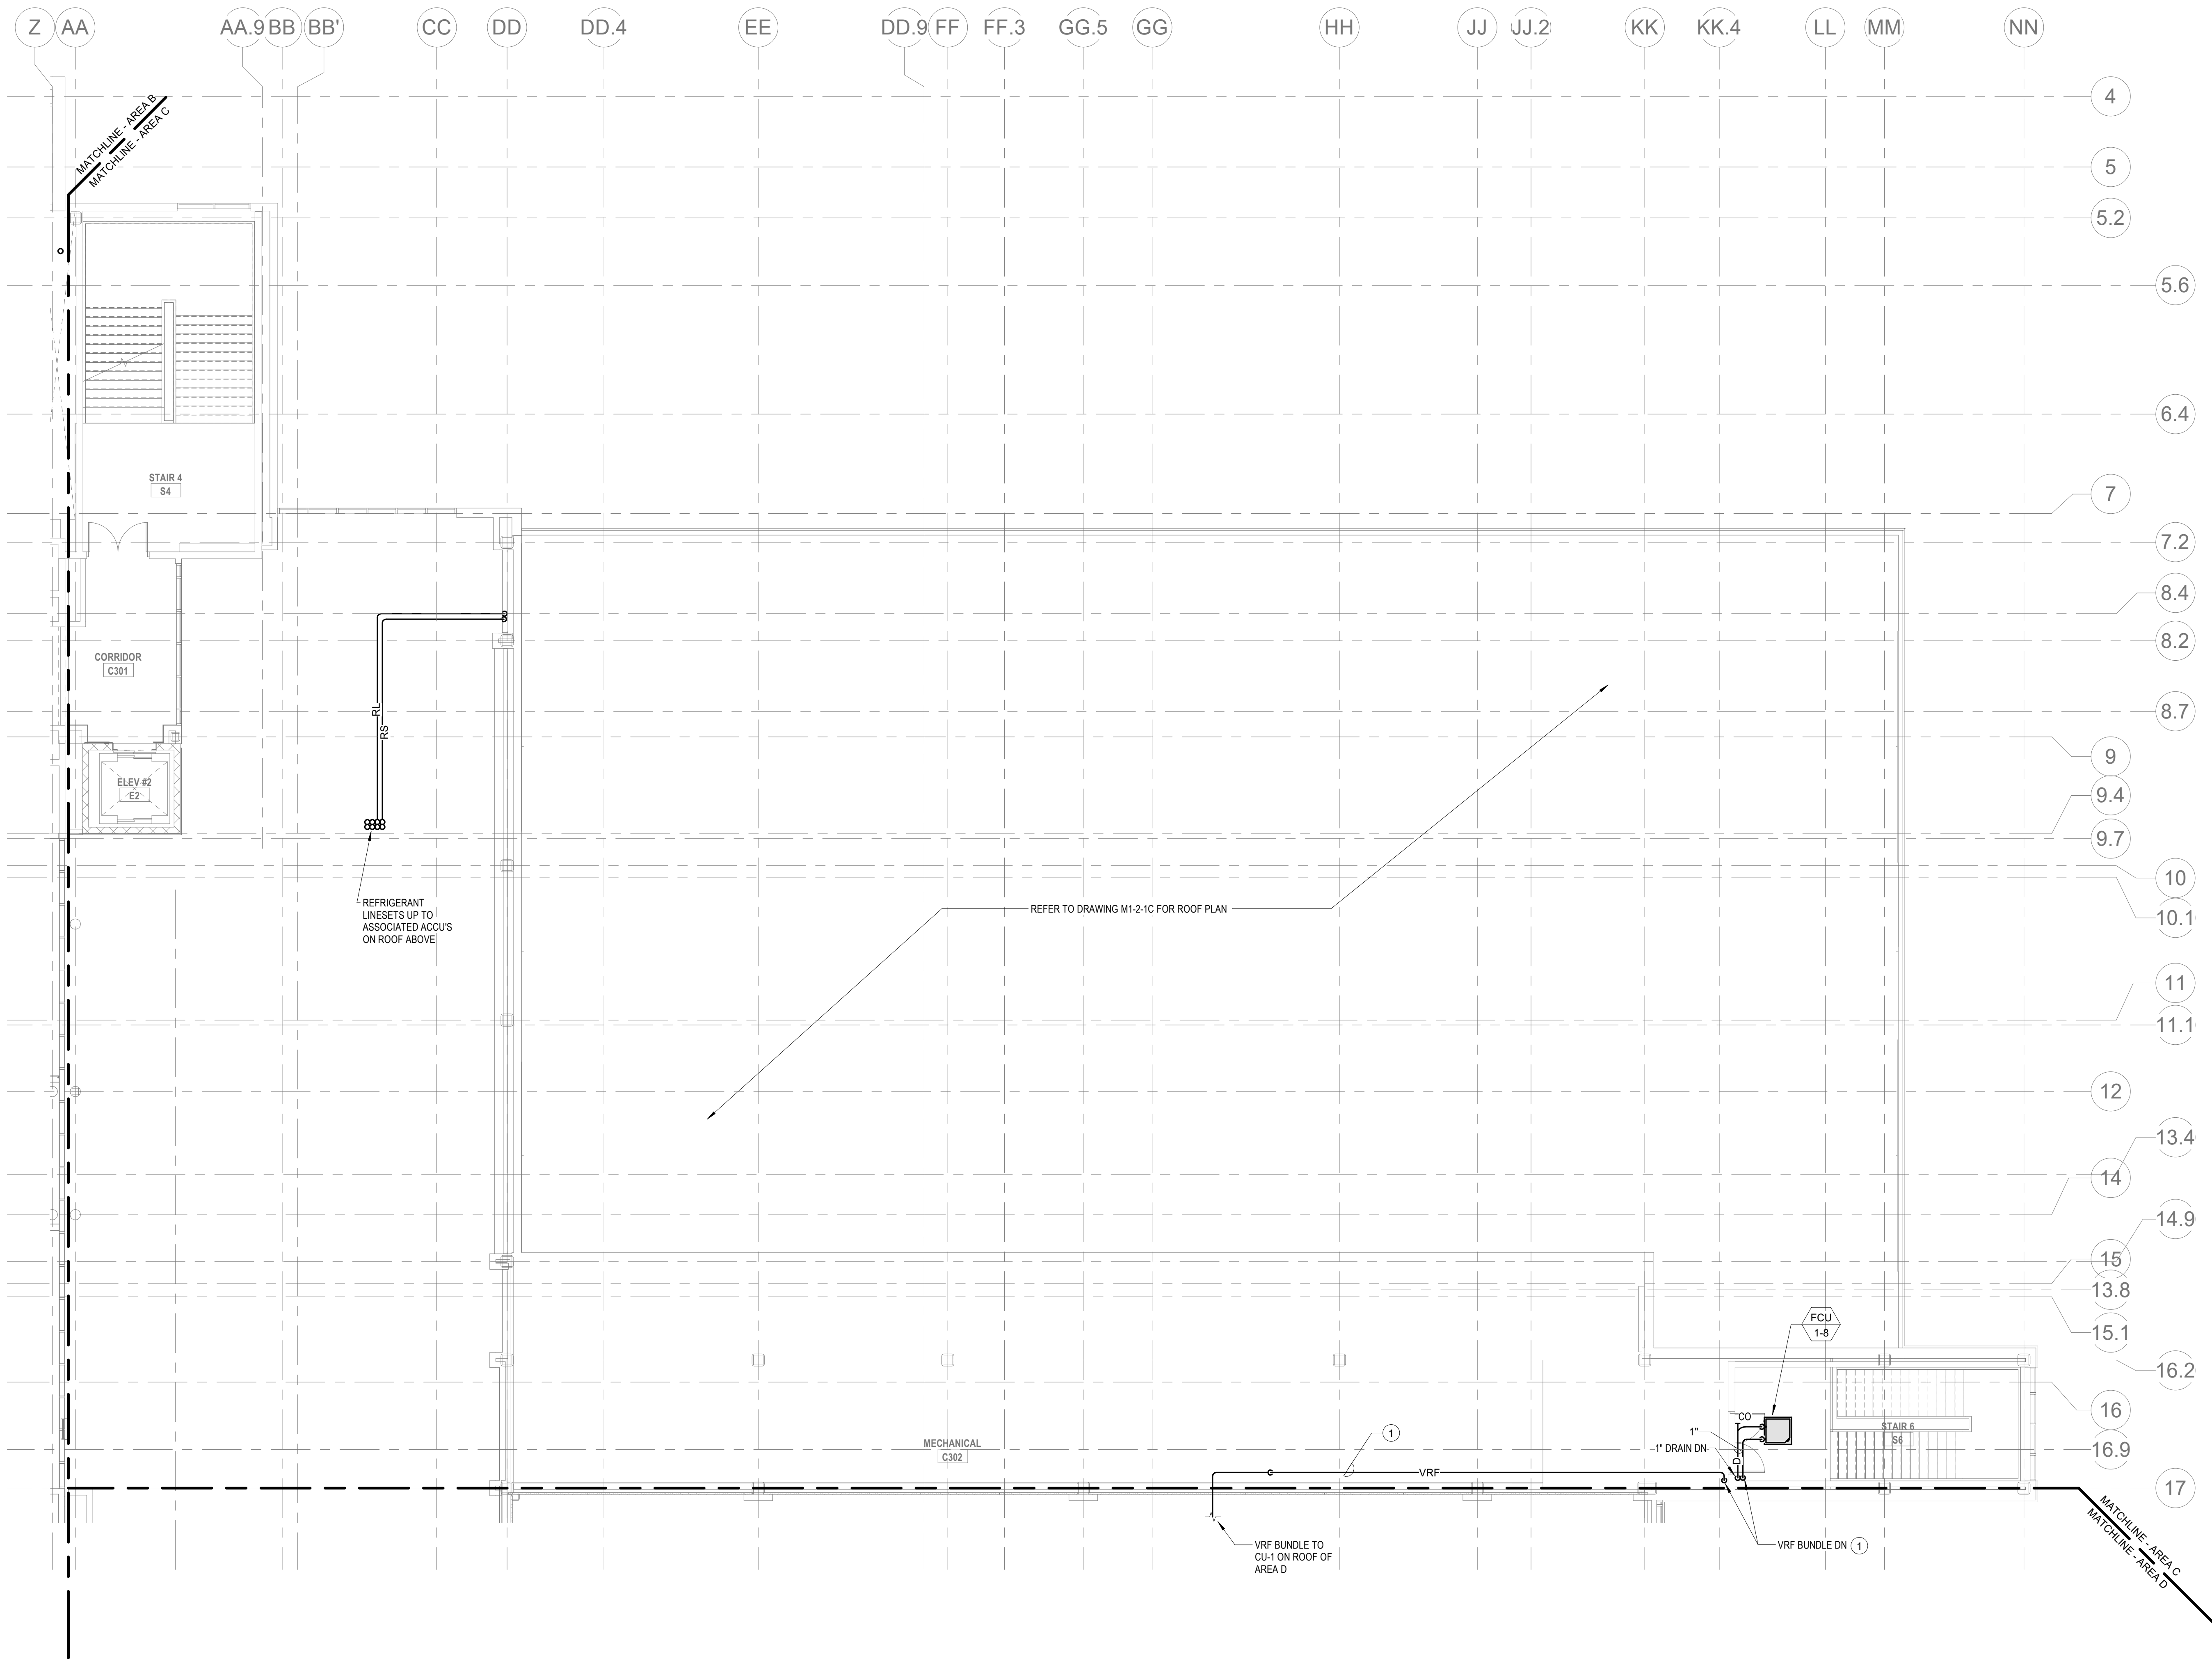


© COPYRIGHT 2021 DRUMMEY ROSANE ANDERSON, INC.

BALA
ENGINEERS
BALA CONSULTING ENGINEERS, INC.
300 WASHINGTON STREET
SUITE 200
WALTHAM, MA 02453
TEL: 617.984.1700 FAX: 617.984.1701
WWW.BALA-ENGINEERS.COM


MSBA 60% CD
SUBMISSION

January 13, 2023

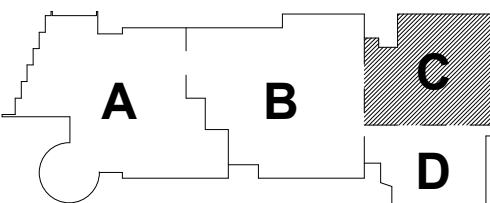


KEY PLAN

PROJECT NORTH

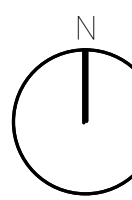

MAGNETIC NORTH

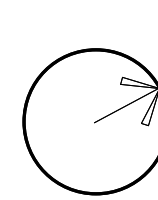

MECHANICAL
PIPING THIRD
FLOOR PLAN -
AREA C

Scale: 1/8" = 1'-0"

Job No.: 20202


Drawn By: DRA

Date: January 13, 2023

M1-3-3C

HVAC DRAWING NOTES

1. VRF REFRIGERANT PIPING IS SHOWN IN A SINGLE LINE DIAGRAMATIC LAYOUT FOR CLARITY. REFER TO THE M2 SERIES DRAWINGS FOR DETAILS ON VRF SYSTEM PIPING SIZES AND QUANTITIES. ALL LENGTHS ARE TO BE CONFIRMED IN THE FIELD AND SIZES ARE TO BE COORDINATED WITH THE VRF SYSTEM MANUFACTURER PRIOR TO ORDERING.
2. PROVIDE REFRIGERANT LINE SET FROM AG UNIT TO ASSOCIATED CONDENSING UNIT ON ROOF. INTEGRAL CONDENSATE PUMP, AND CONDENSATE DRAIN PIPING TO NEAREST CONDENSATE RECEPTOR. CONDENSATE RECEPTOR BY DIV. 22.

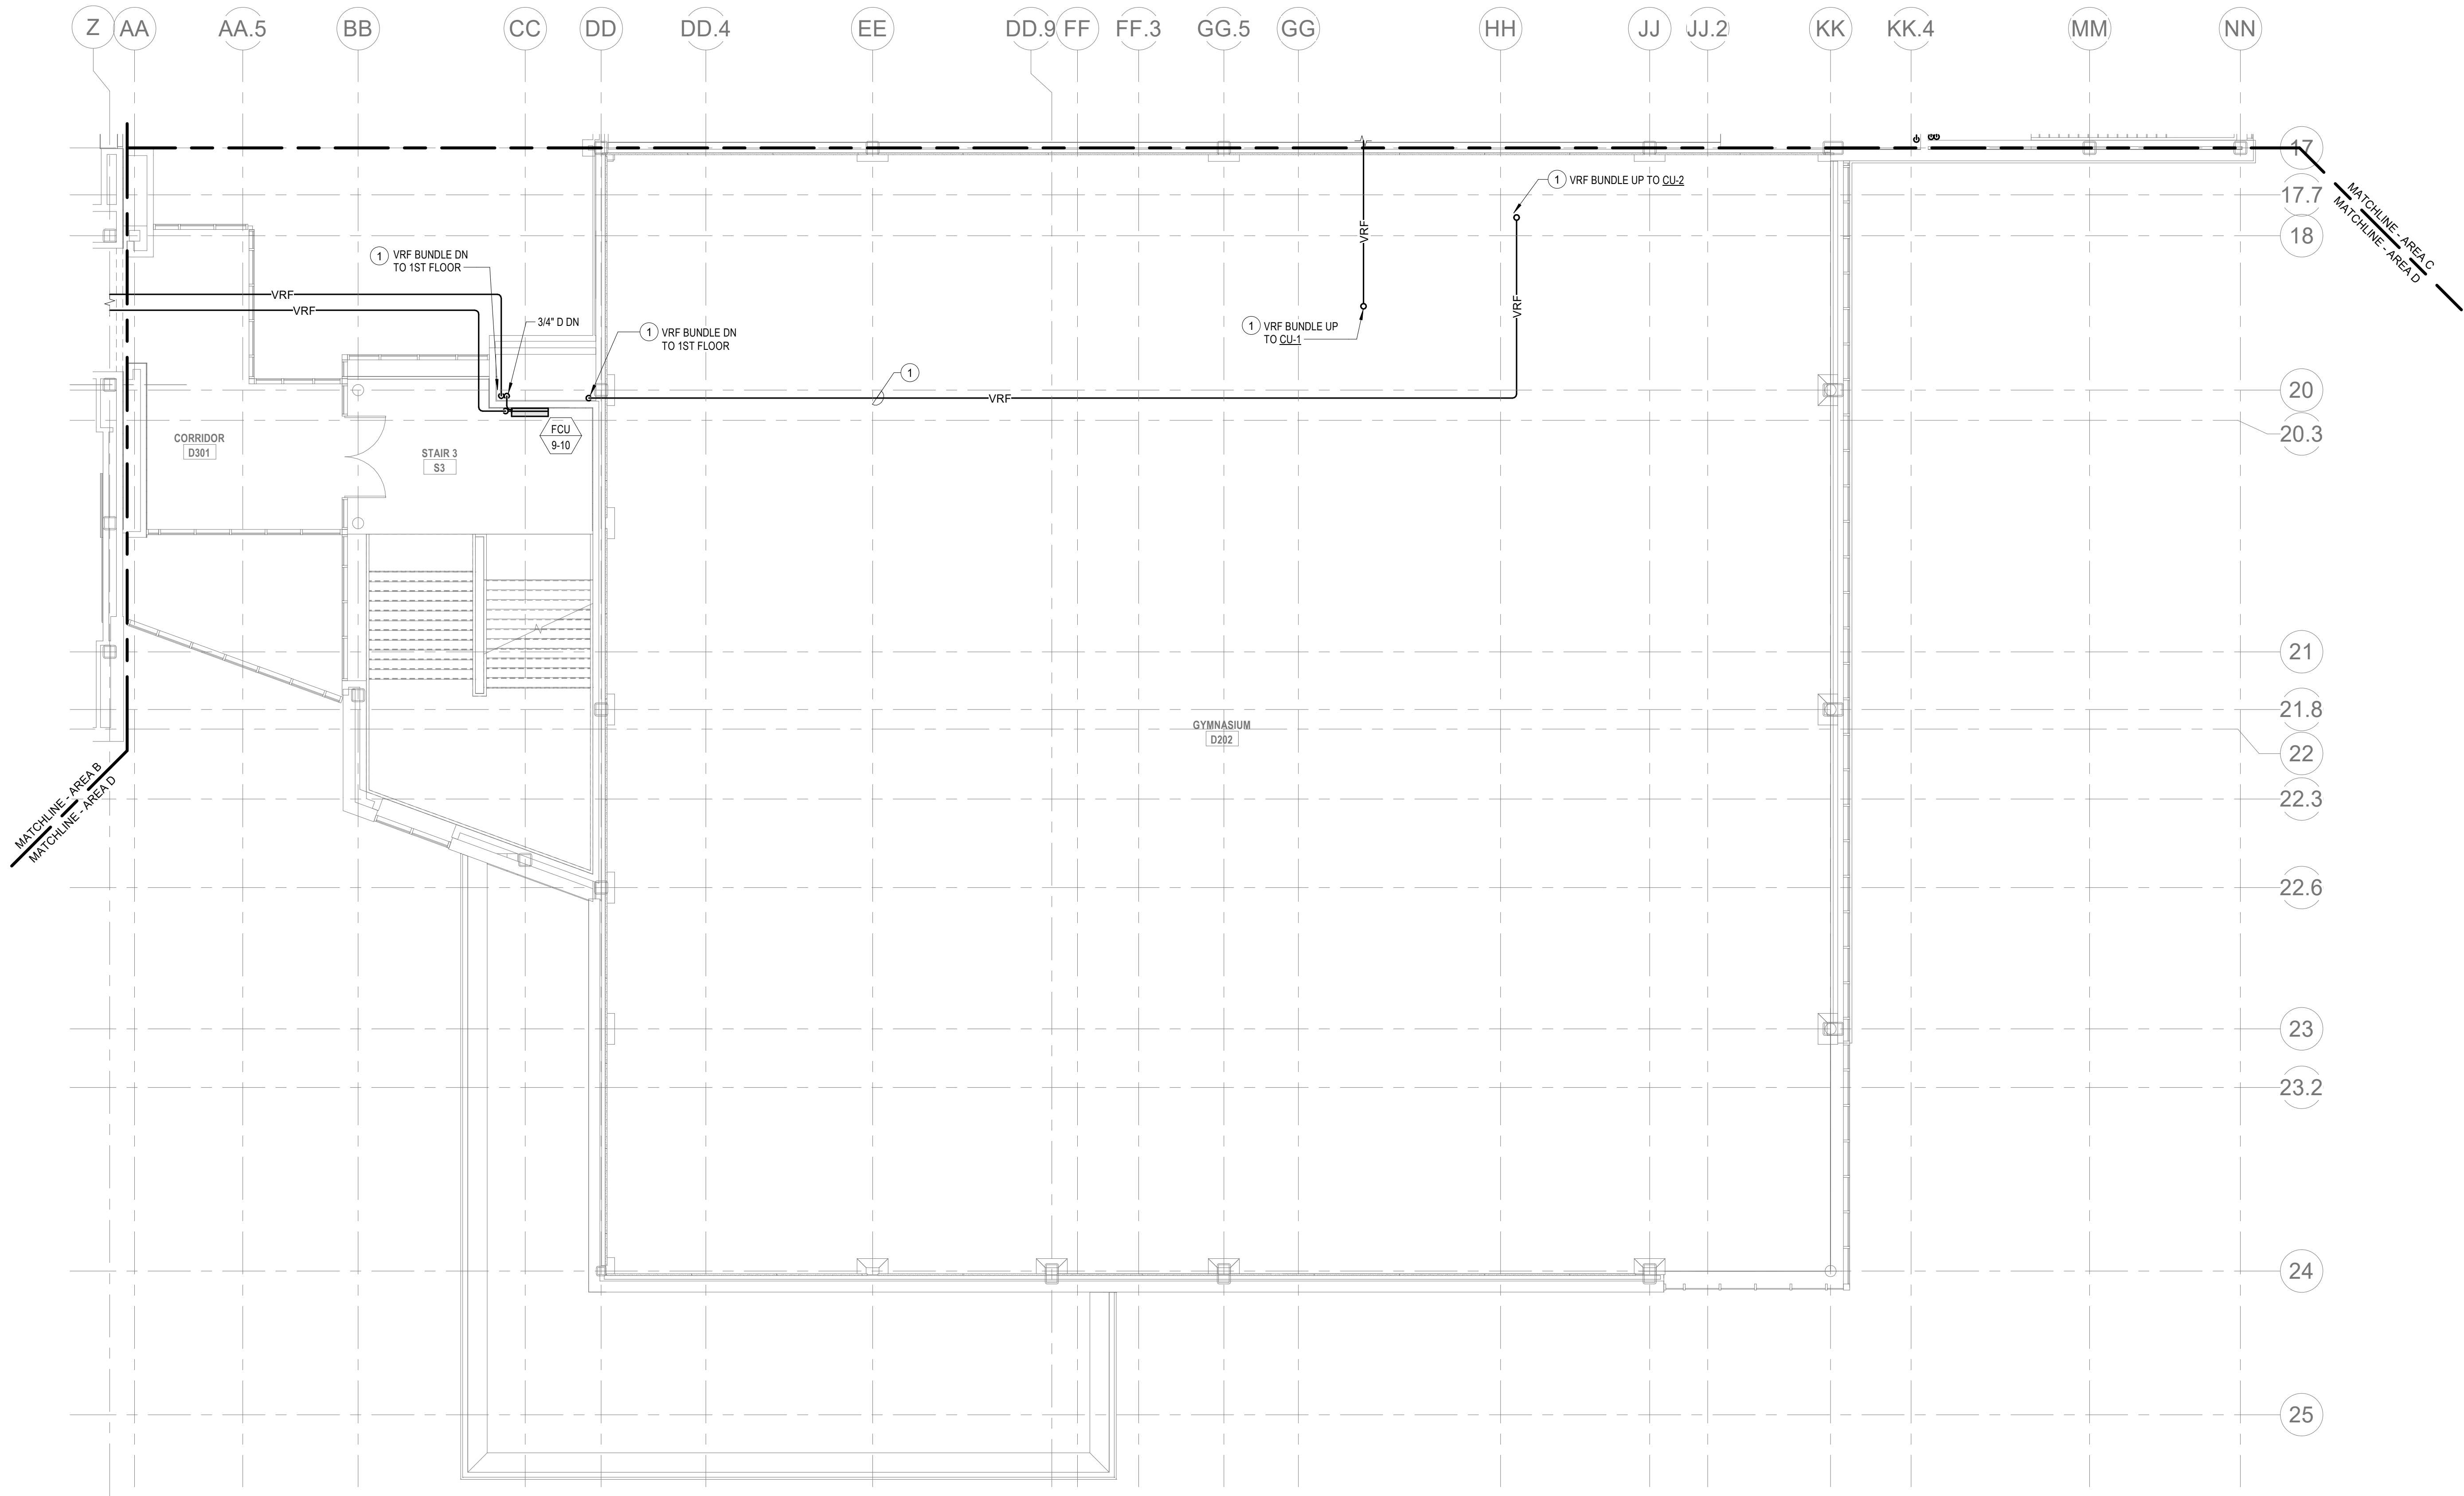

DrummeY Rosane Anderson, Inc.
225 Oakland Road
Studio 205
South Windsor, CT 06074
Tel: 817.984.1700
www.draan.com

280 Charles Street
Studio 300
Waltham, MA 02453
Planning | Architecture | Interior Design

Northeast
Metropolitan
Regional
Vocational High
School


Wakefield, MA 01880

© COPYRIGHT 2021 DRUMMEY ROSANE ANDERSON, INC.




MSBA 60% CD
SUBMISSION

January 13, 2023

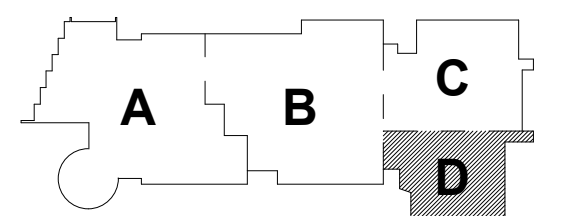


KEY PLAN

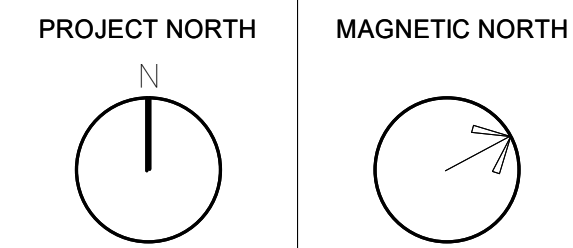

MECHANICAL
PIPING THIRD
FLOOR PLAN -
AREA D

Scale: 1/8" = 1'-0"
Job No.: 20202
Drawn By: DRA
Date: January 13, 2023

M1-3-3D

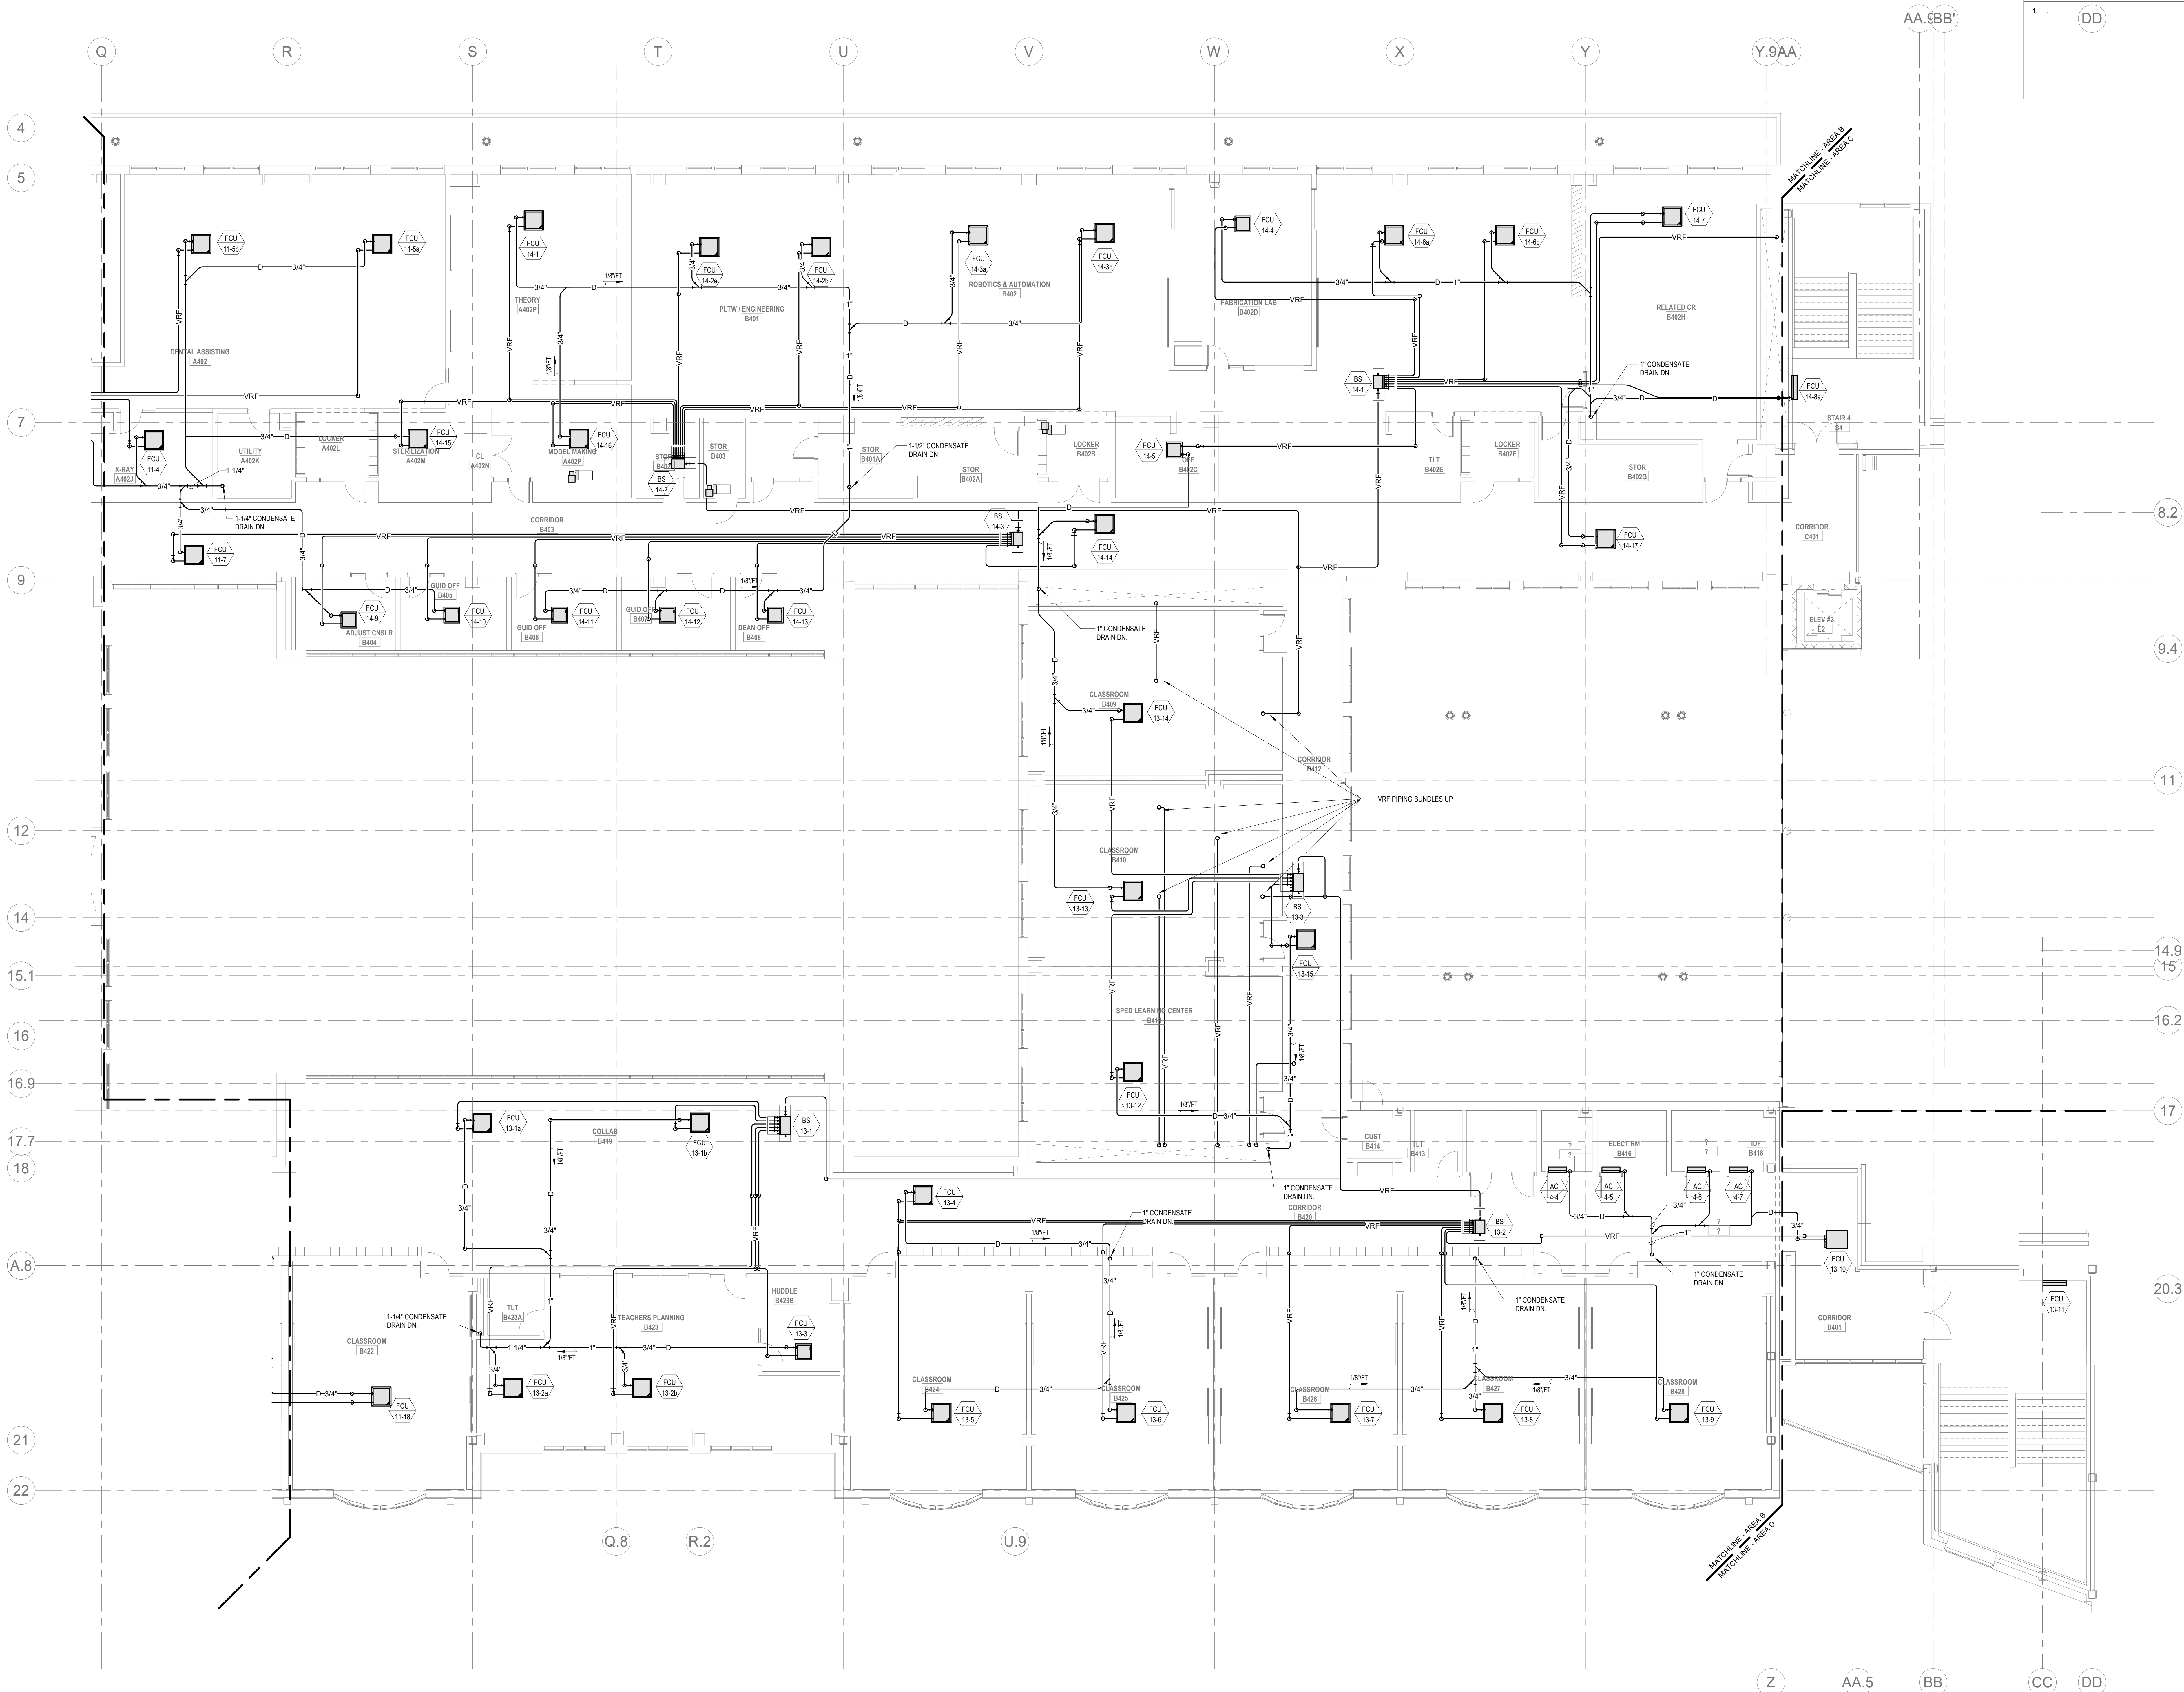

HVAC GENERAL NOTES

1. REFER TO VRF PIPING DIAGRAMS ON THE M2 SERIES DRAWINGS FOR REFRIGERANT PIPING DISTRIBUTION. PROVIDE A CONDENSATE DRAIN FROM EACH FAN COIL UNIT TO THE NEAREST CONDENSATE RECEPTOR. CONDENSATE RECEPTOR BY DIV. 22.
2. PROVIDE REFRIGERANT LINE SET FROM EACH AC UNIT TO ASSOCIATED CONDENSING UNIT ON ROOF. INTEGRAL CONDENSATE PUMP. AND CONDENSATE DRAIN PIPING TO NEAREST CONDENSATE RECEPTOR. CONDENSATE RECEPTOR BY DIV. 22.

HVAC DRAWING NOTES

1. DD

DRA

Drumrey Rosane Anderson, Inc.
225 Oakland Road
Studio 205
South Windsor, CT
06074
Tel: 817.984.1700
www.dra.com

280 Charles Street
Studio 300
Waltham, MA
02453

Planning | Architecture | Interior Design


Northeast
Metropolitan
Regional
Vocational High
School

Wakefield, MA 01880

© COPYRIGHT 2021 DRUMREY ROSANE ANDERSON, INC.


BALA
ENGINEERS

MSBA 60% CD
SUBMISSION
January 13, 2023

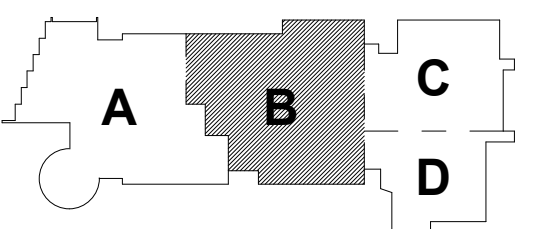

KEY PLAN

PROJECT NORTH
MAGNETIC NORTH

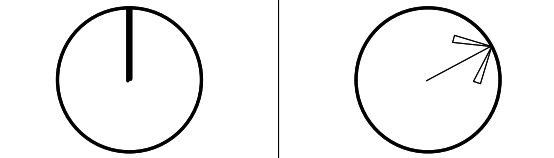



MECHANICAL
PIPING FOURTH
FLOOR PLAN -
AREA B

Scale: 1/8" = 1'-0"
Job No.: 20202
Drawn By: DRA
Date: January 13, 2023

M1-3-4B

HVAC GENERAL NOTES

1. PROVIDE A LITTLE GIANT VCM-15ULS OR EQUAL CONDENSATE PUMP WITH CONDENSATE PIPING FROM AHU CONDENSATE DISCHARGE TO NEAREST CONDENSATE RECEPTOR. TYPICAL FOR EACH AHU.

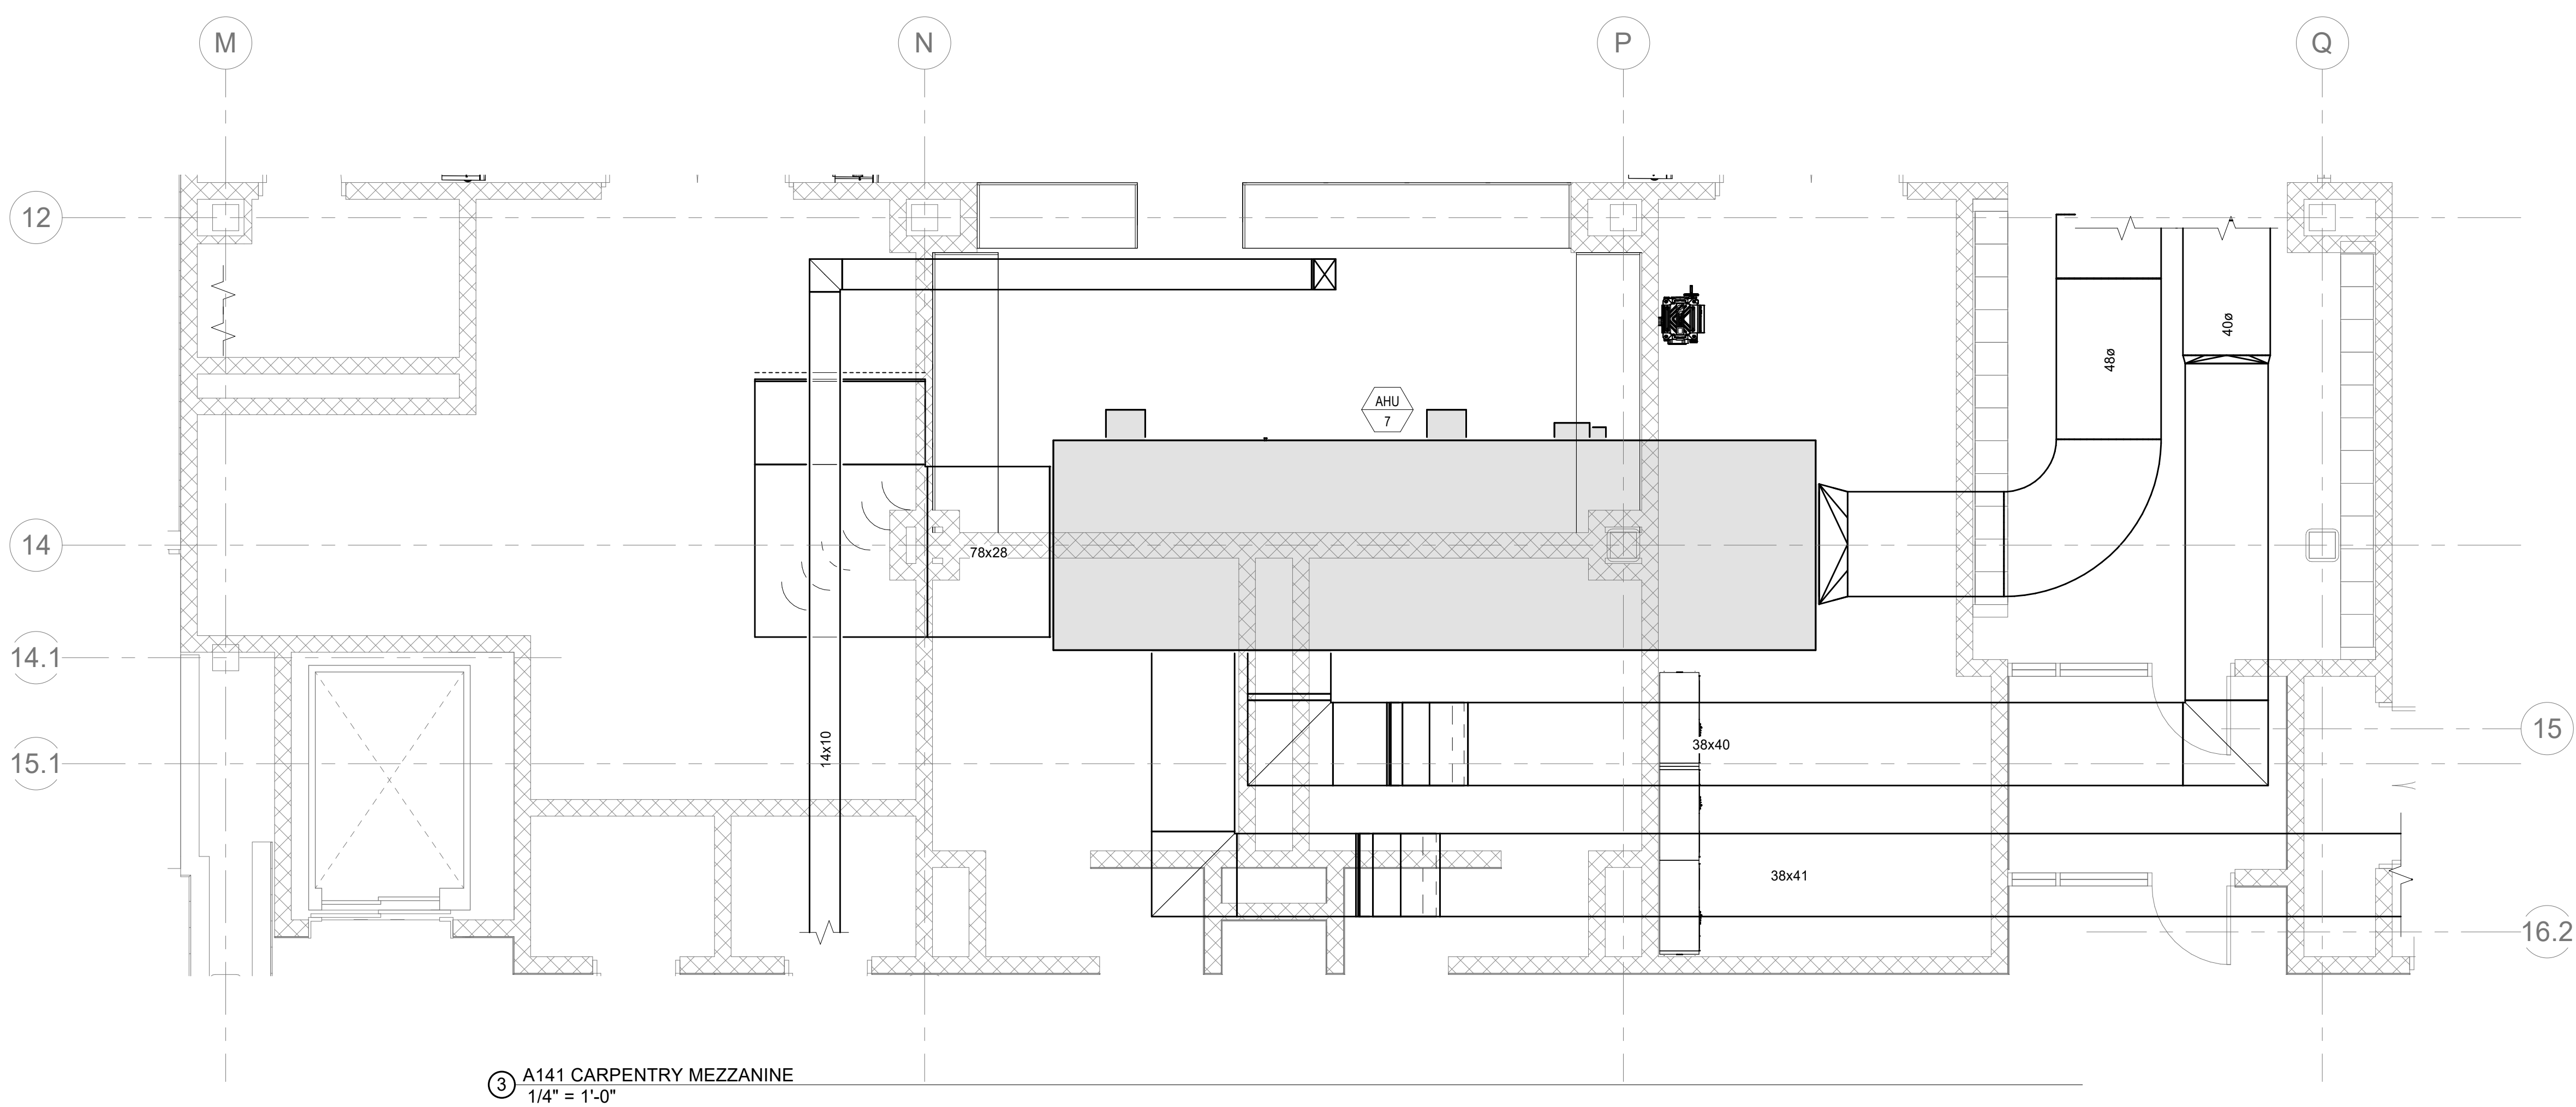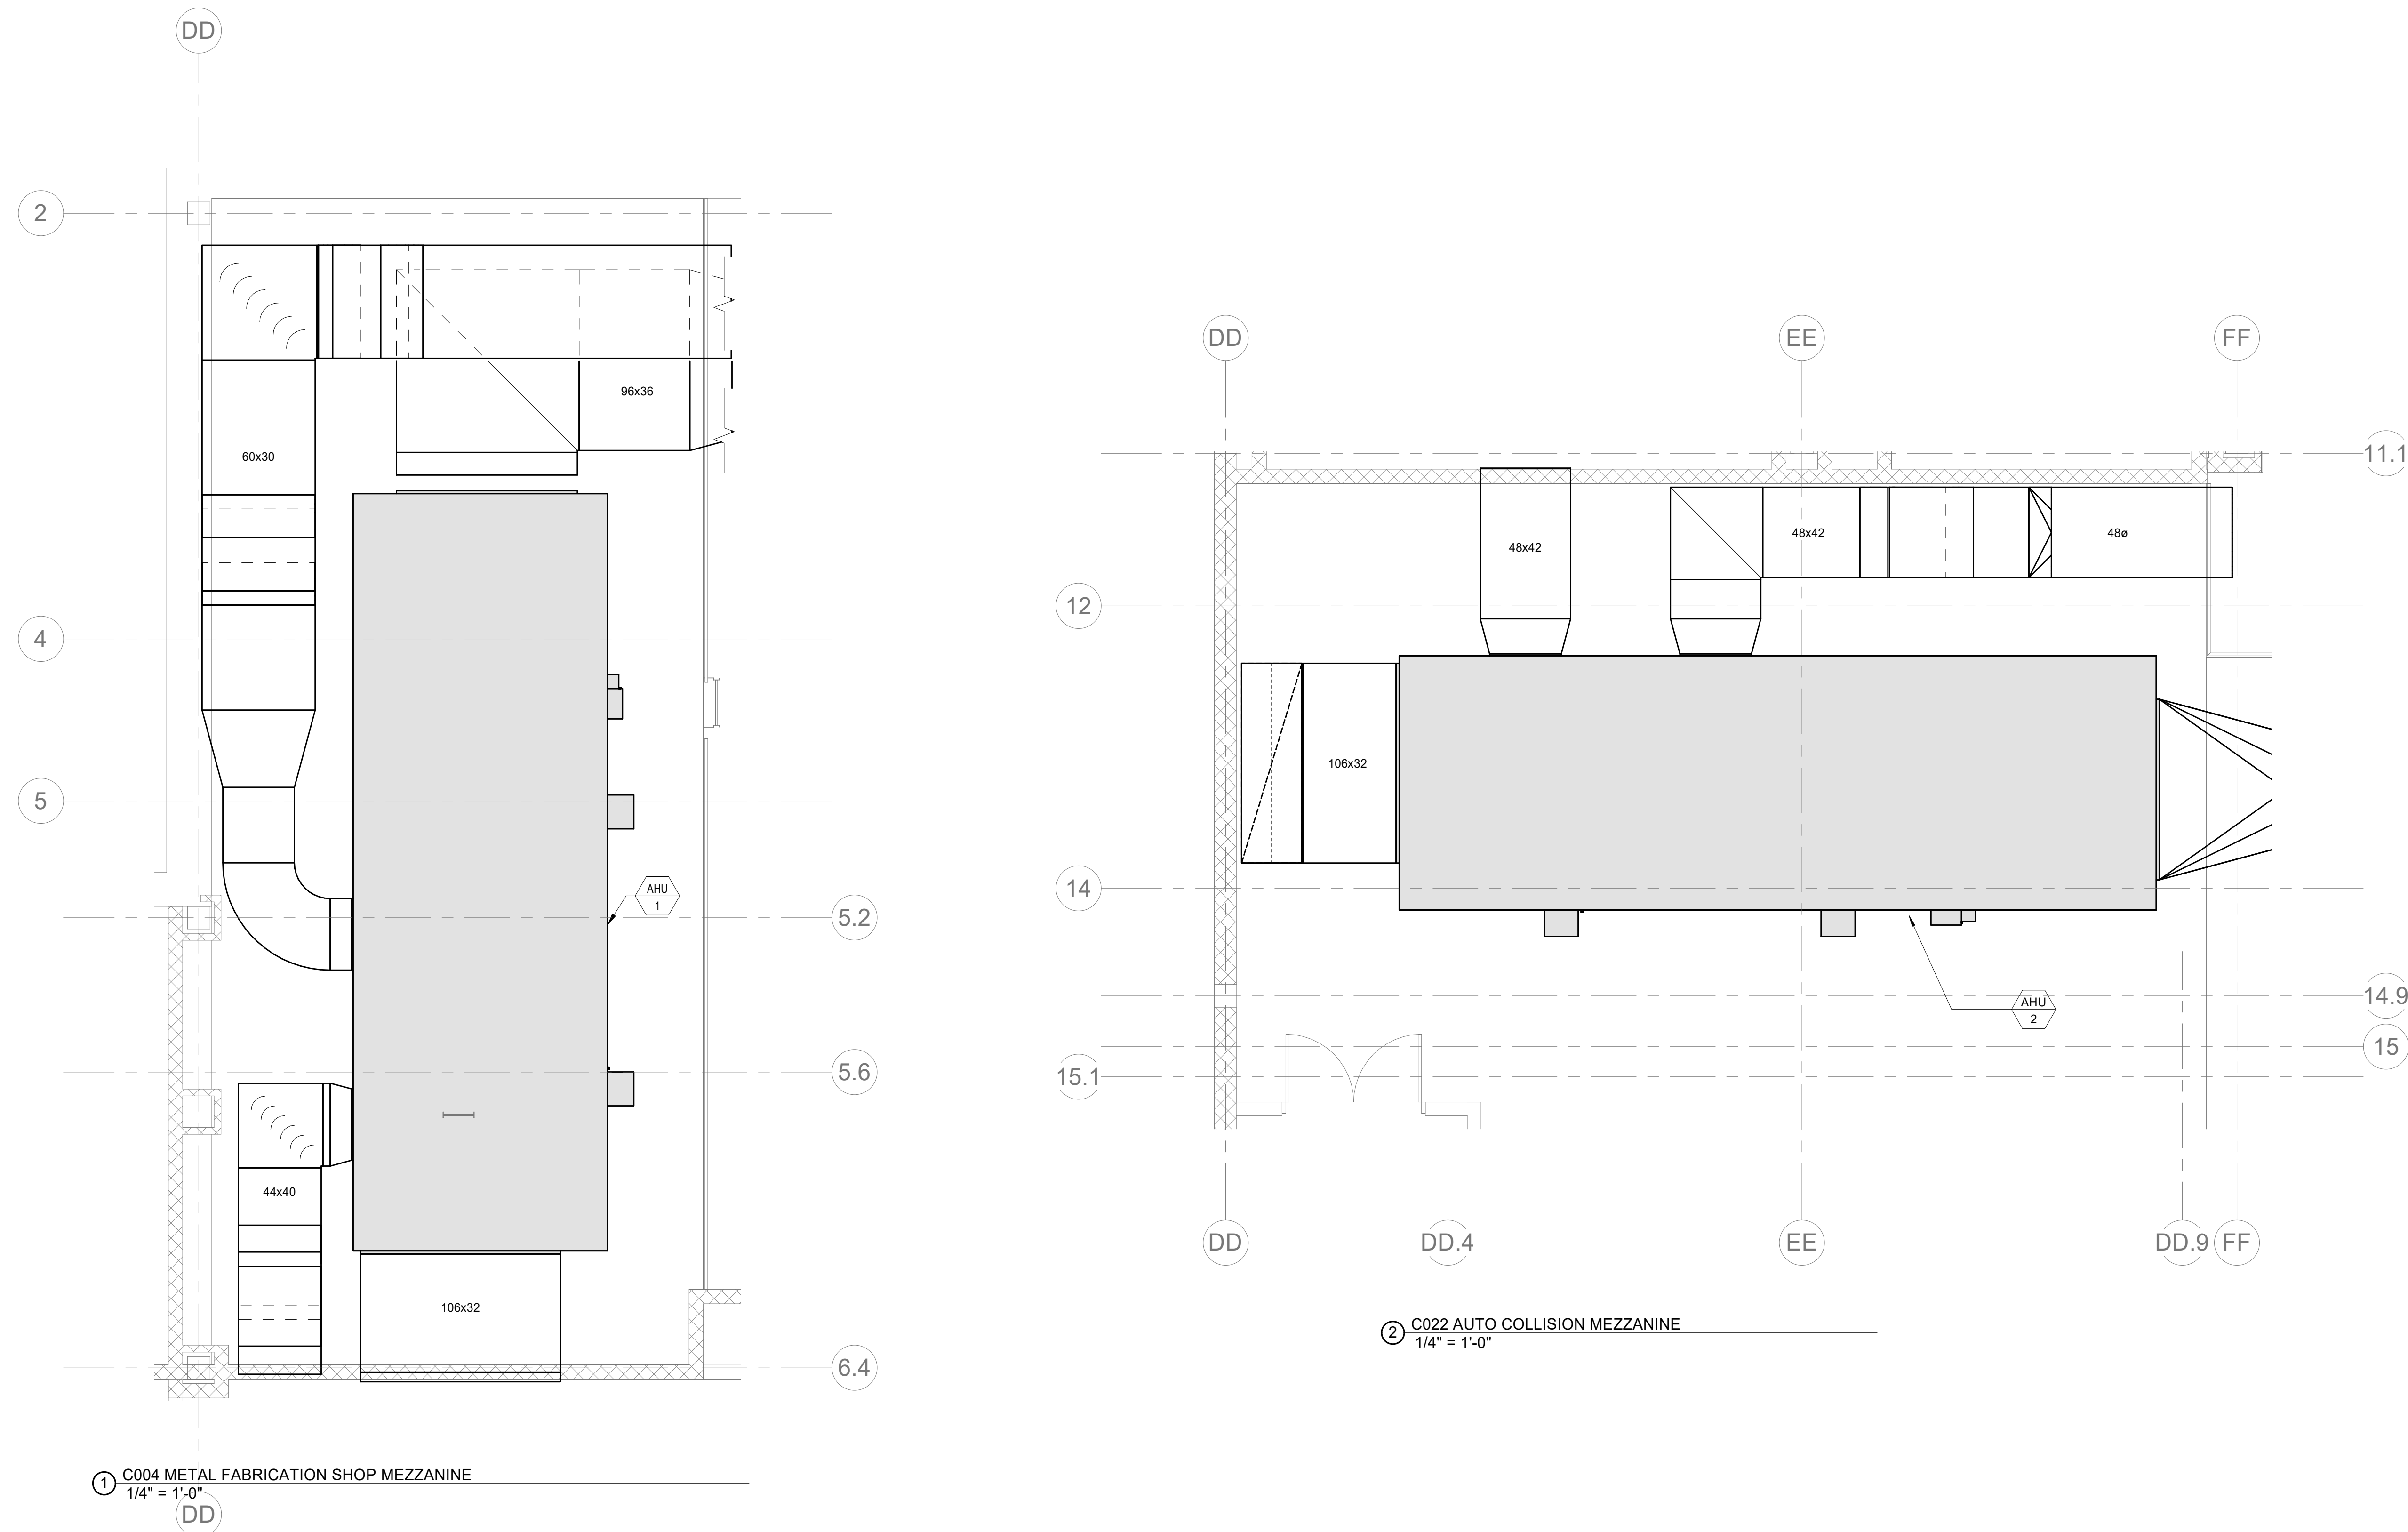

DRA

Drumme Rosane Anderson, Inc.
225 Oakland Road
Studio 205
South Windsor, CT
06074
260 Charles Street
Studio 300
Waltham, MA
02453
Planning | Architecture | Interior Design
Tel: 817.984.1700
www.draa.com

Northeast
Metropolitan
Regional
Vocational High
School

Wakefield, MA 01880


BALA
ENGINEERS
BALA CONSULTING ENGINEERS, INC.
300 WEST 10TH STREET
NEW YORK, NY 10014
TEL: 212.693.1200 FAX: 212.693.1201
WWW.BALA.COM

MSBA 60% CD
SUBMISSION
January 13, 2023


PROJECT NORTH
MAGNETIC NORTH

MECHANICAL
ENLARGED
PLANS


Scale: 1/4\" = 1'-0"
Job No.: 20202
Drawn By: DRA
Date: January 13, 2023
M2-0-1

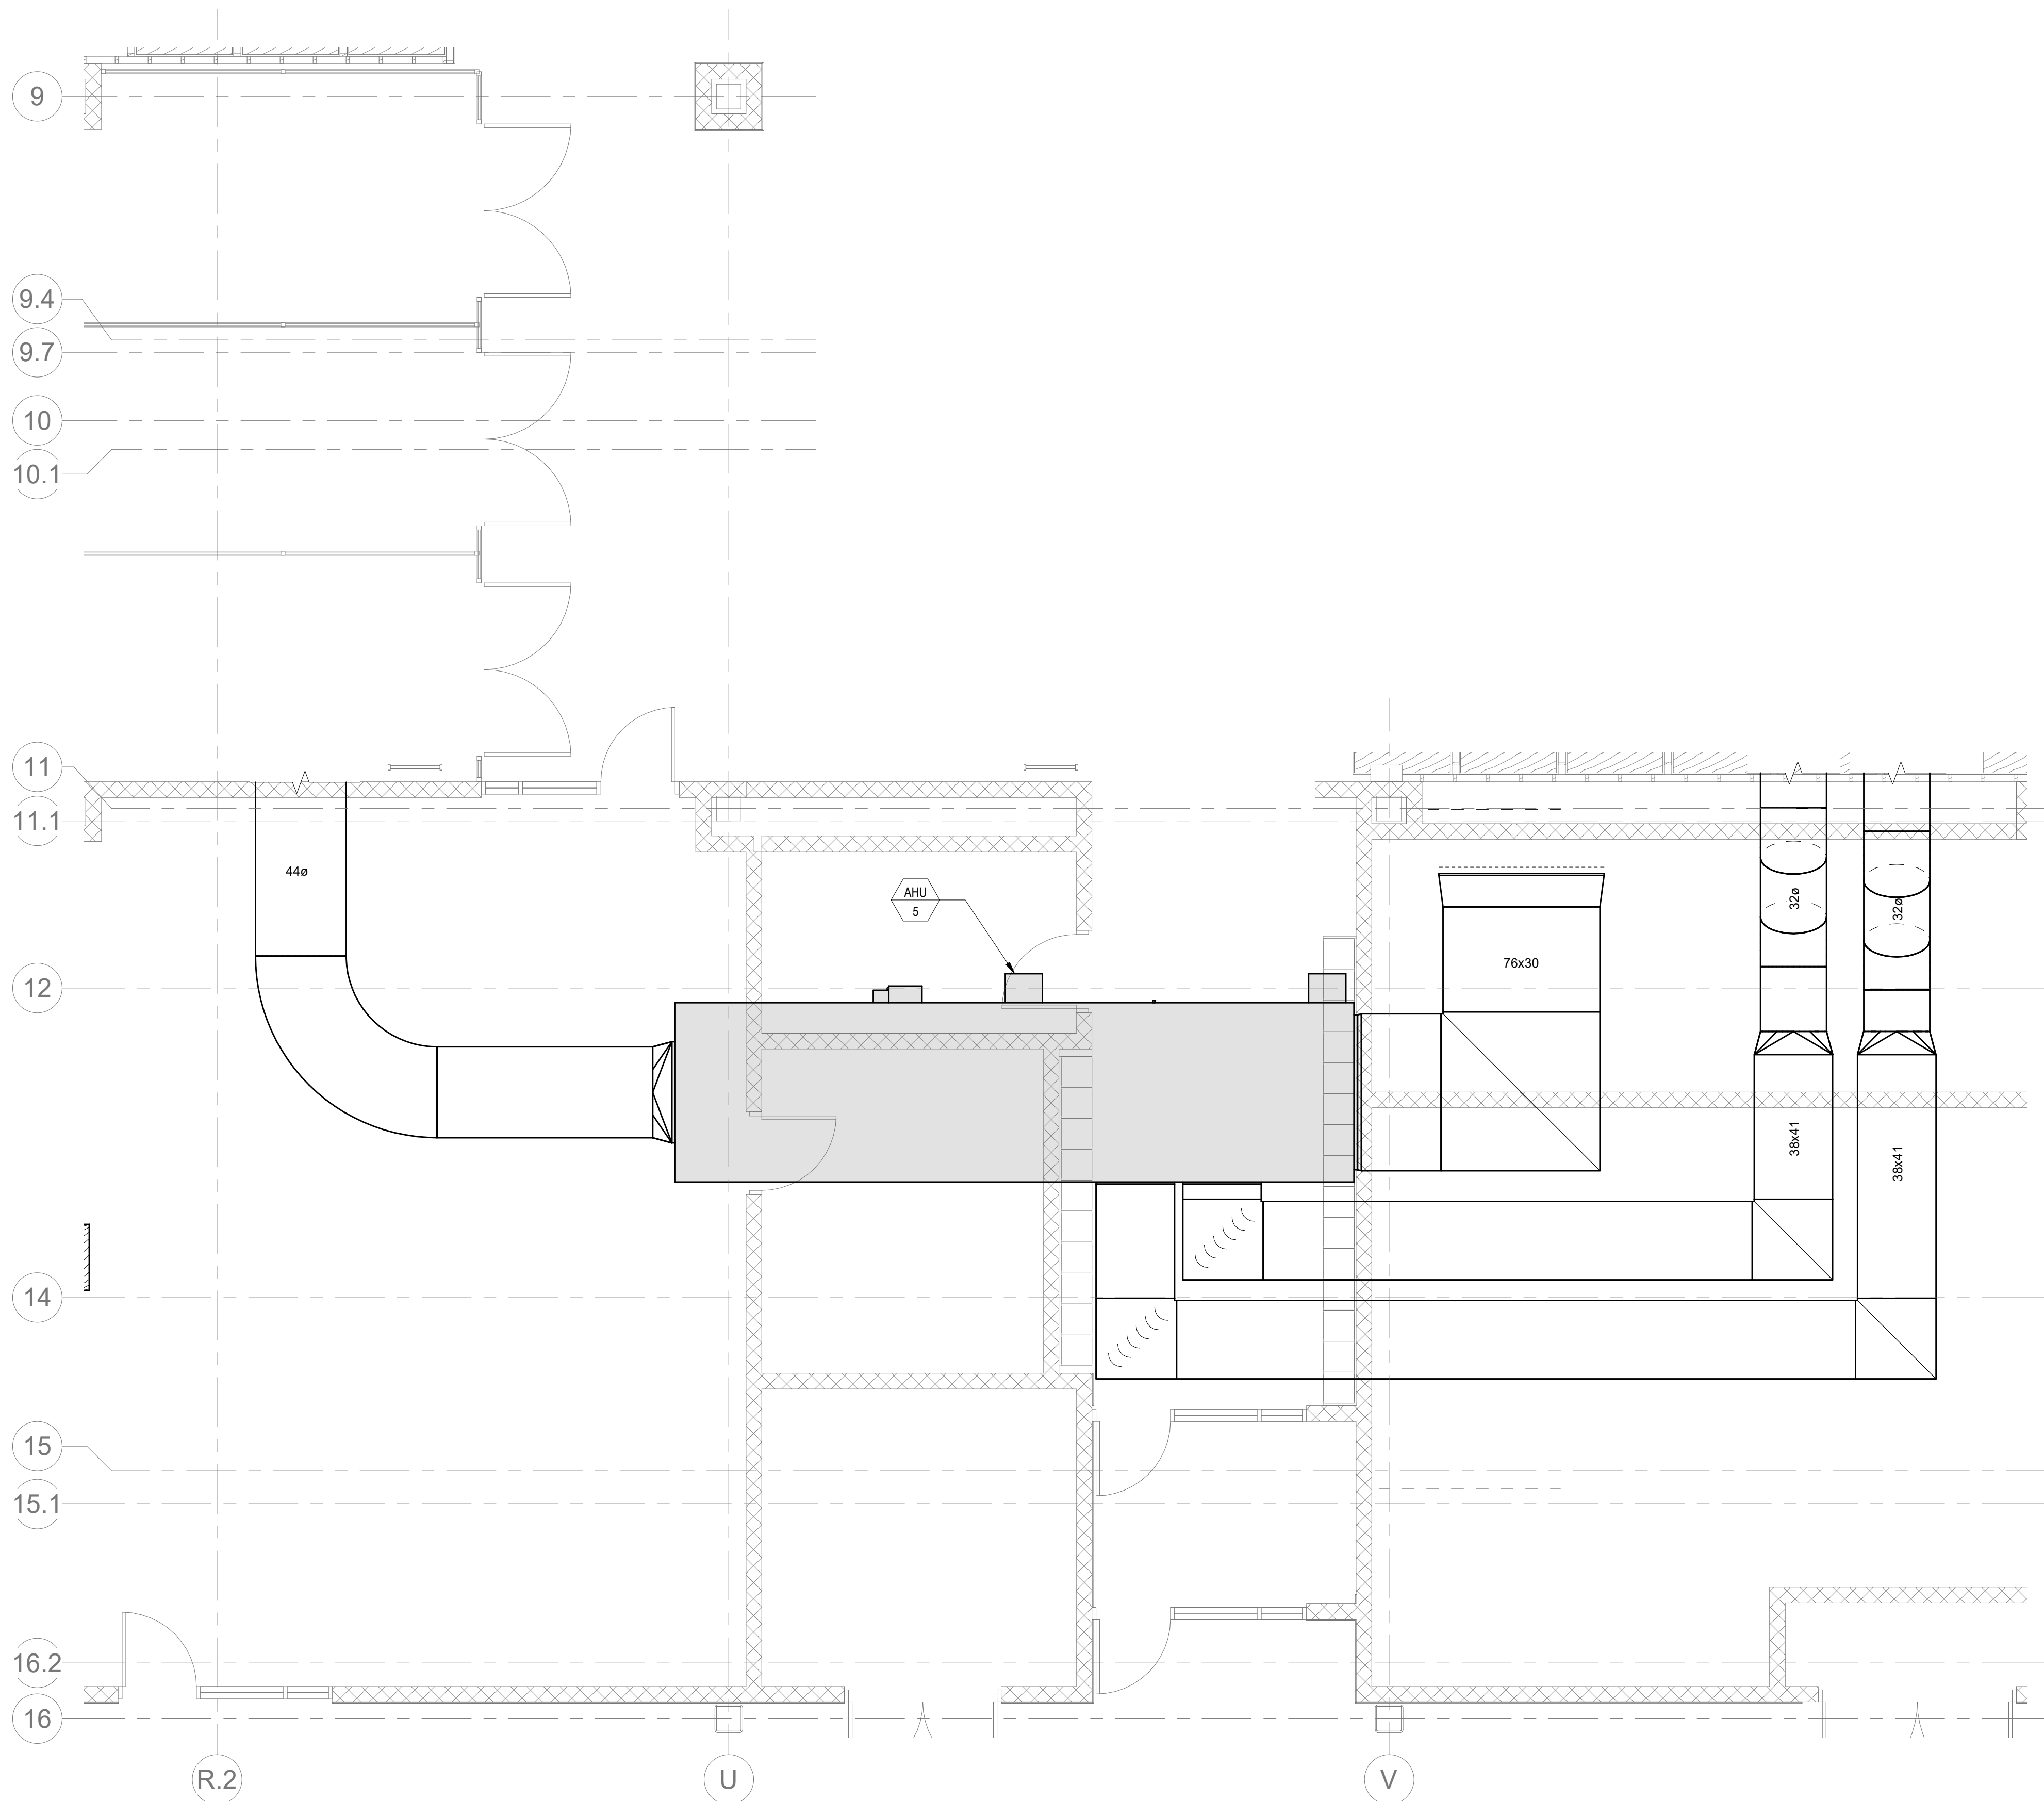

② B103 HVAC TECHNOLOGY MEZZANINE
1/4" = 1'-0"

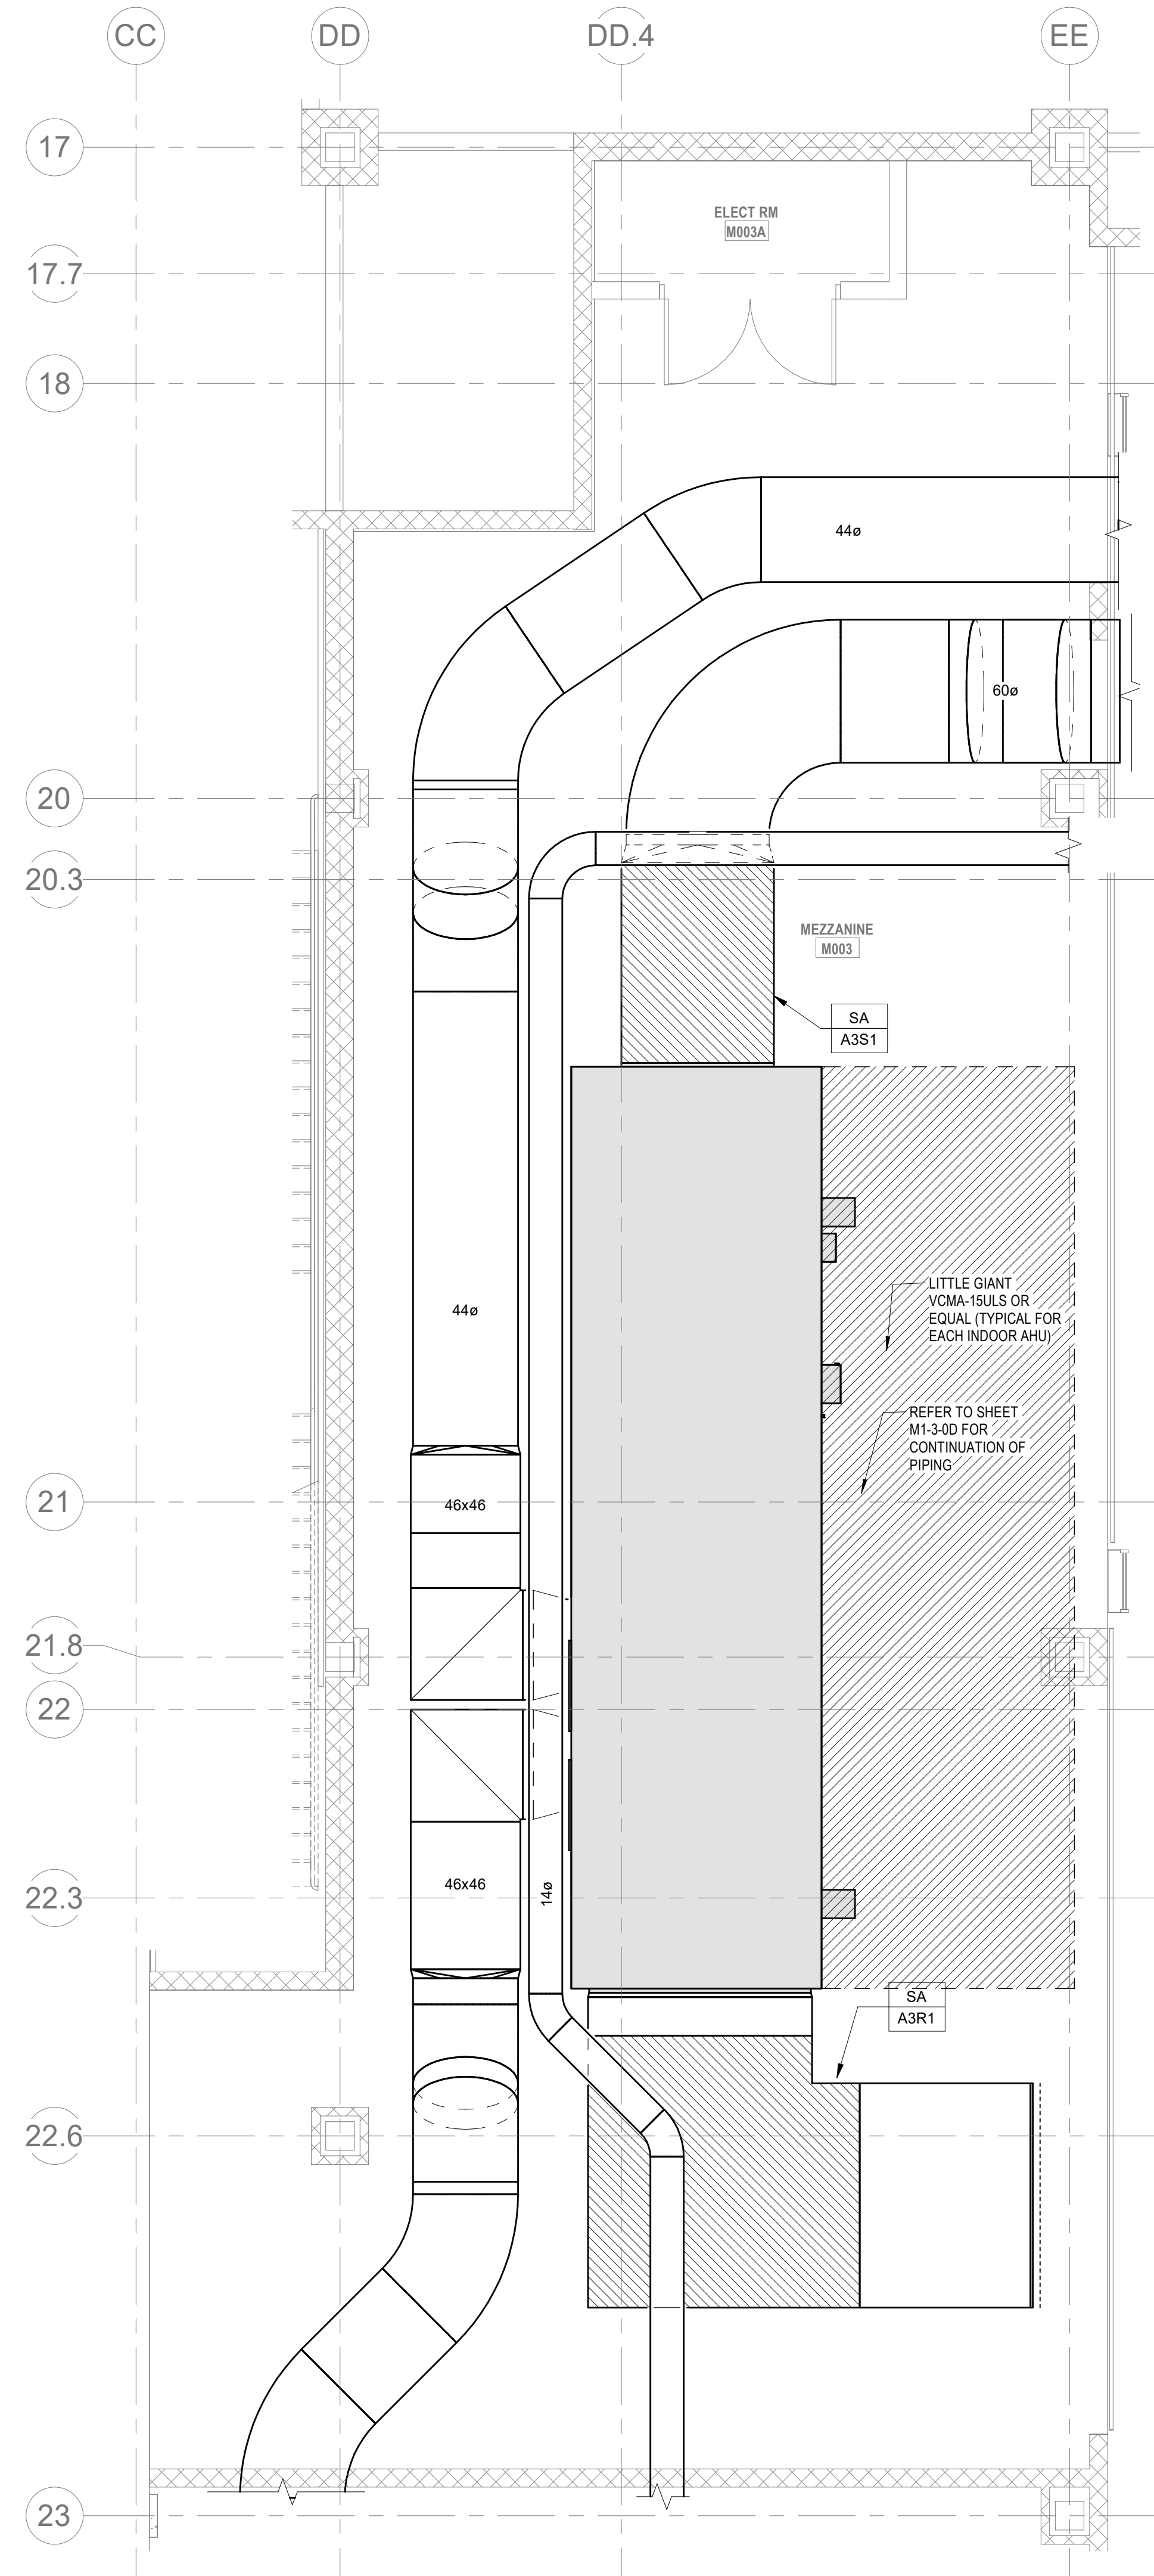

③ D008 AUTO TECHNOLOGY MEZZANINE
1/4" = 1'-0"

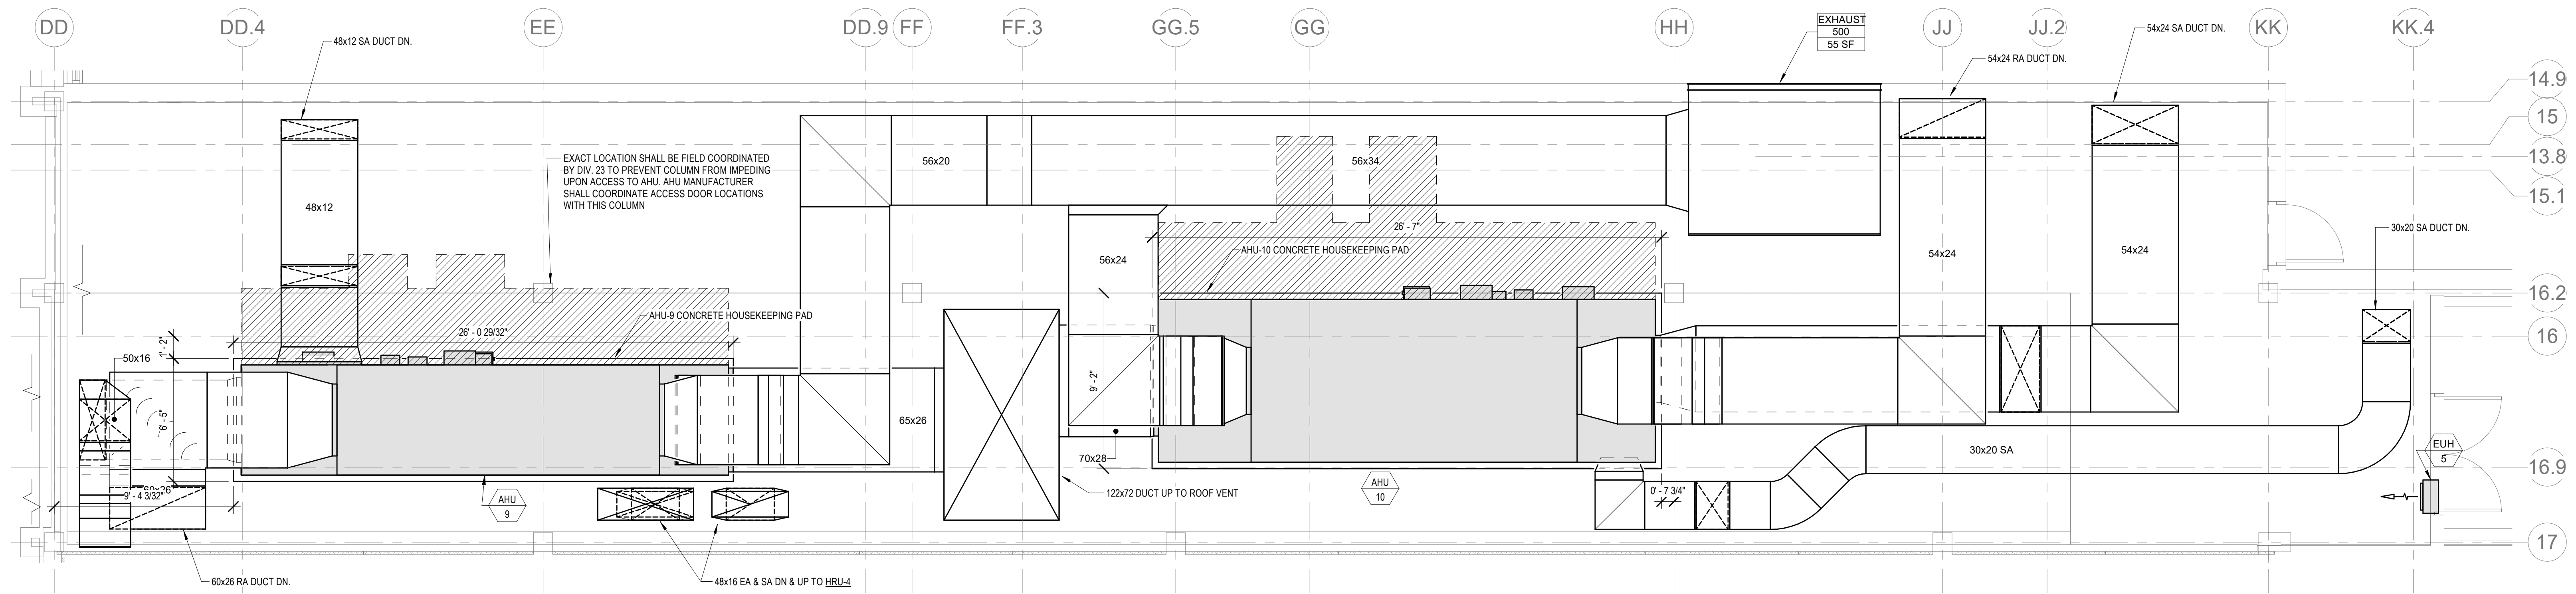

① C302 MECHANICAL ROOM
1/4" = 1'-0"

HVAC GENERAL NOTES

1. PROVIDE A LITTLE GIANT VCM-15ULS OR EQUAL CONDENSATE PUMP WITH CONDENSATE PIPING FROM AHU CONDENSATE DISCHARGE TO NEAREST CONDENSATE RECEPTOR. TYPICAL FOR EACH AHU.

DRA

Drumme Rosane Anderson, Inc.
225 Oakland Road
Studio 205
South Windsor, CT 06074
Tel: 817-984-1700
www.dra-inc.com

280 Charles Street
Studio 300
Waltham, MA 02453
Tel: 817-984-1700
www.dra-inc.com

Planning | Architecture | Interior Design

**Northeast
Metropolitan
Regional
Vocational High
School**


Wakefield, MA 01880

© COPYRIGHT 2021 DRUMMEY ROSANE ANDERSON, INC.

BALA
ENGINEERS

MSBA 60% CD
SUBMISSION

January 13, 2023


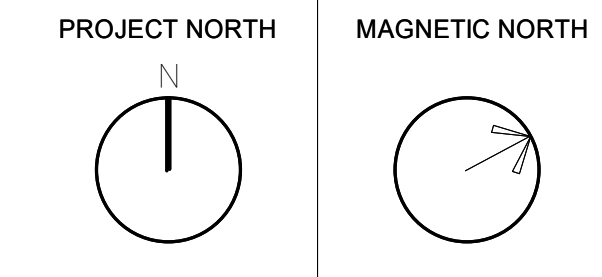


**MECHANICAL
ENLARGED
PLANS**

Scale: 1/4" = 1'-0"
Job No.: 20202
Drawn By: DRA
Date: January 13, 2023

M2-0-3

Wakefield, MA 01880

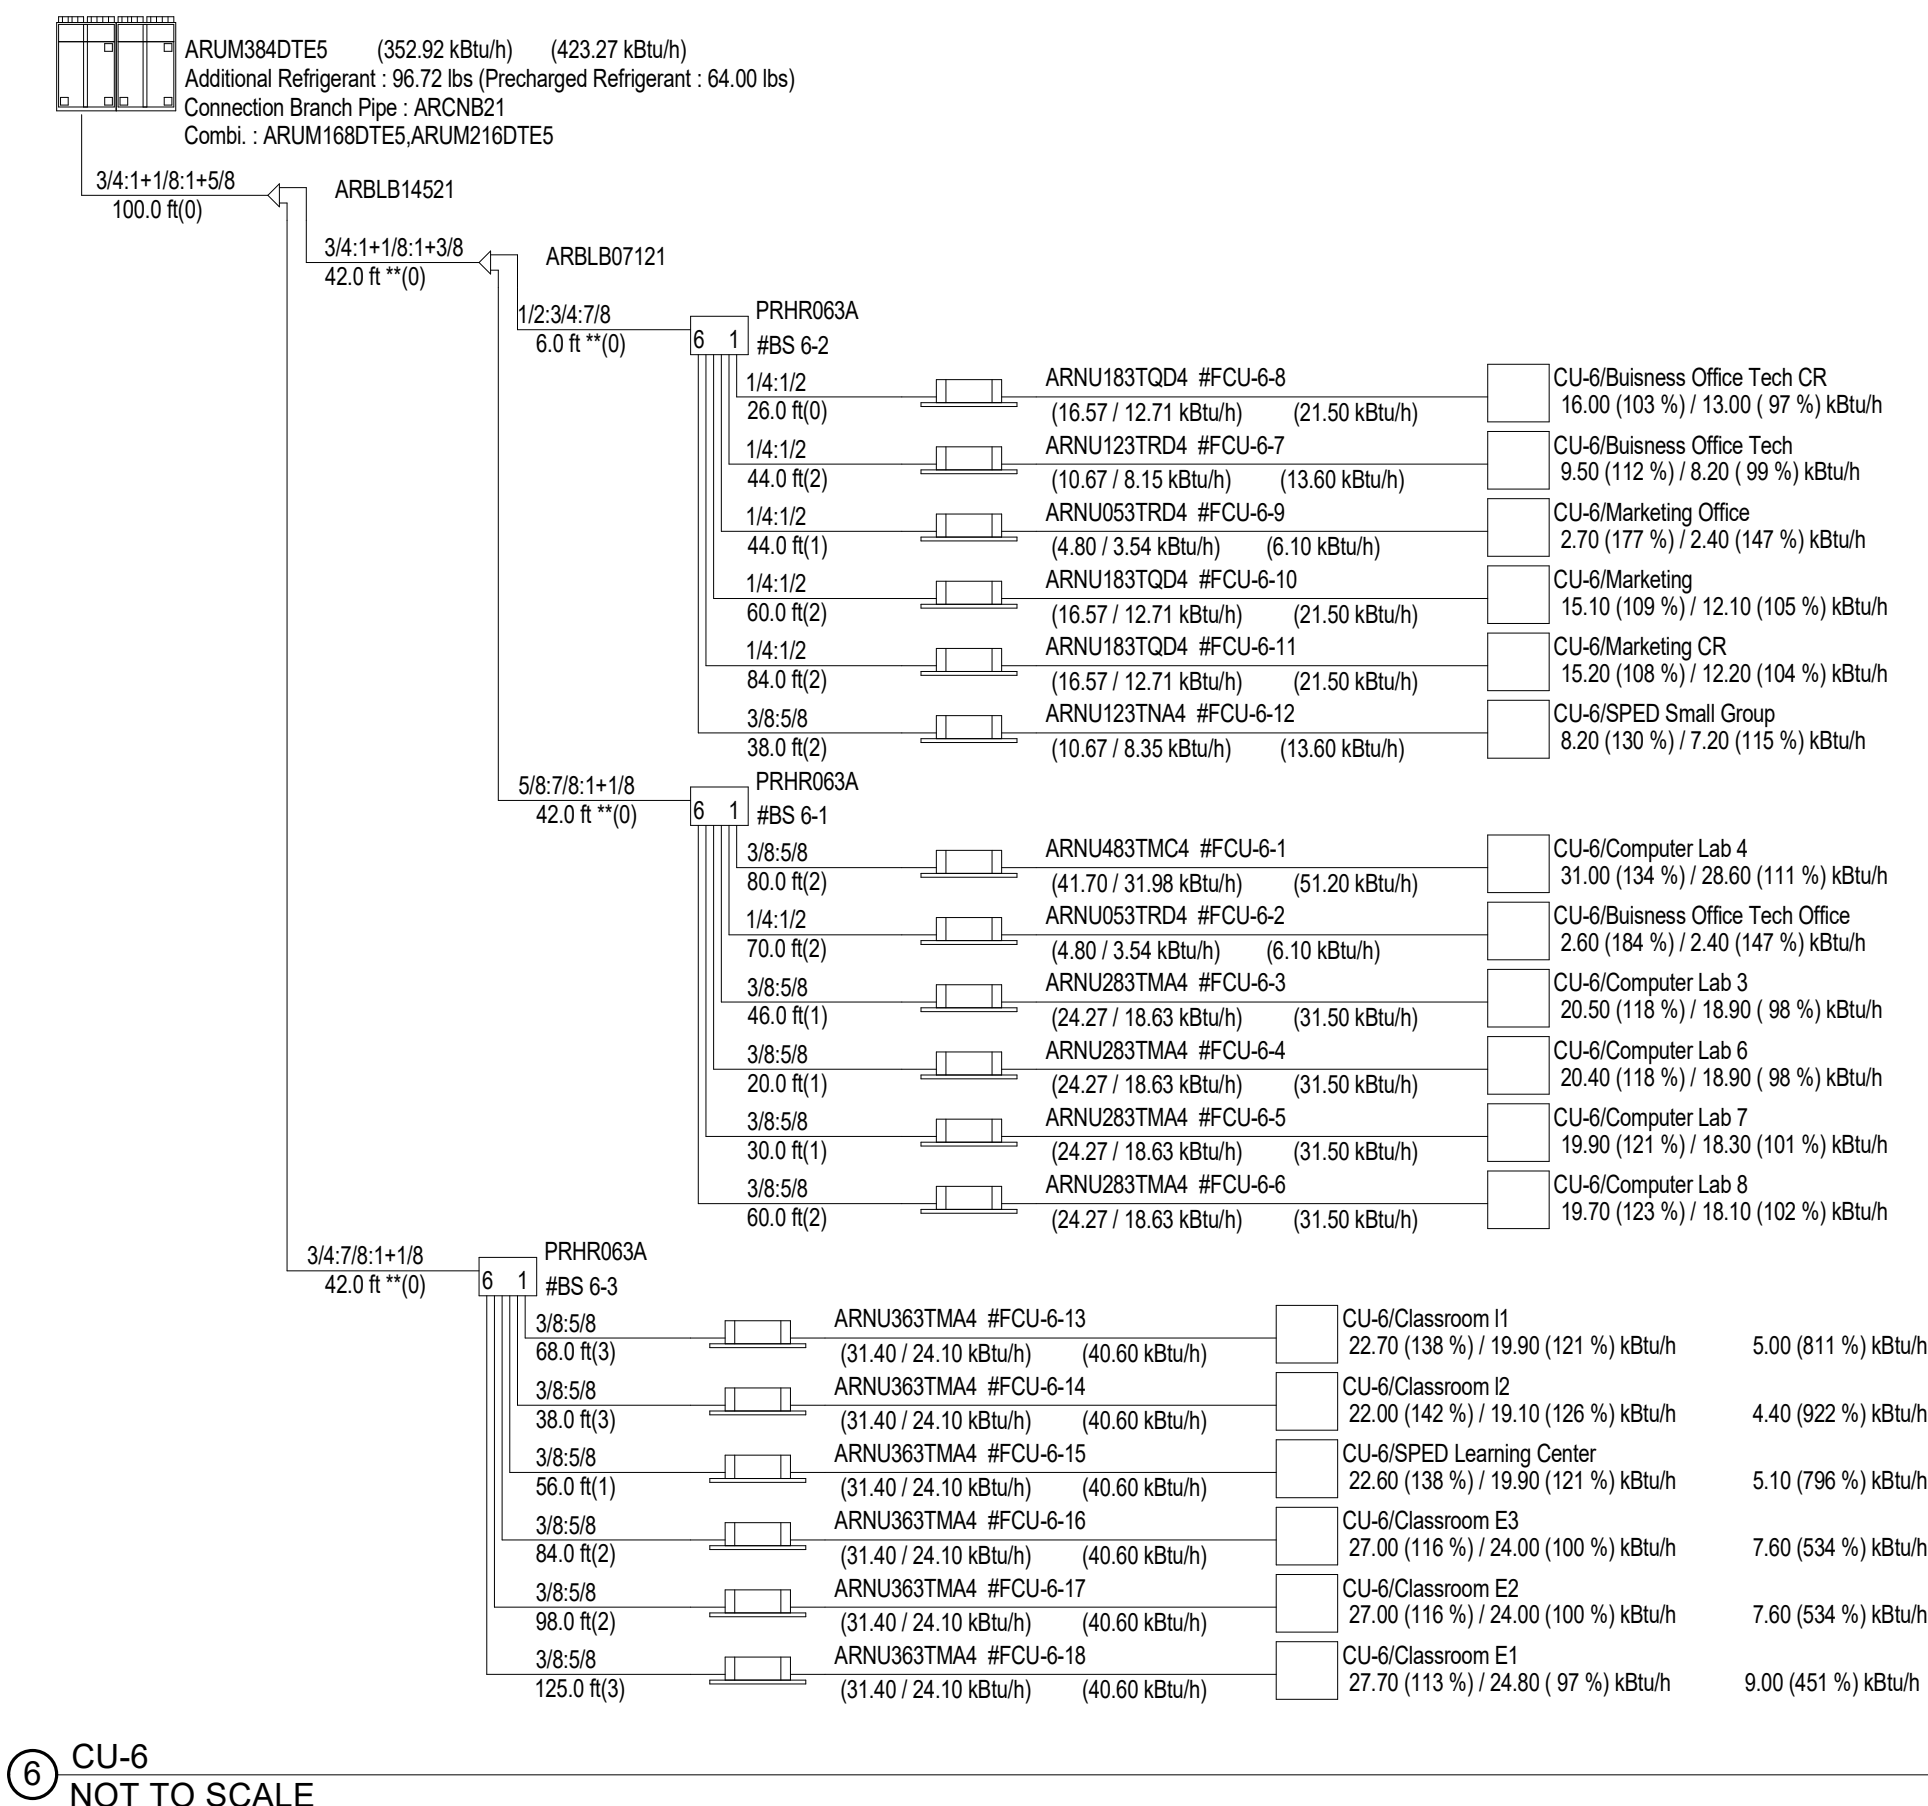
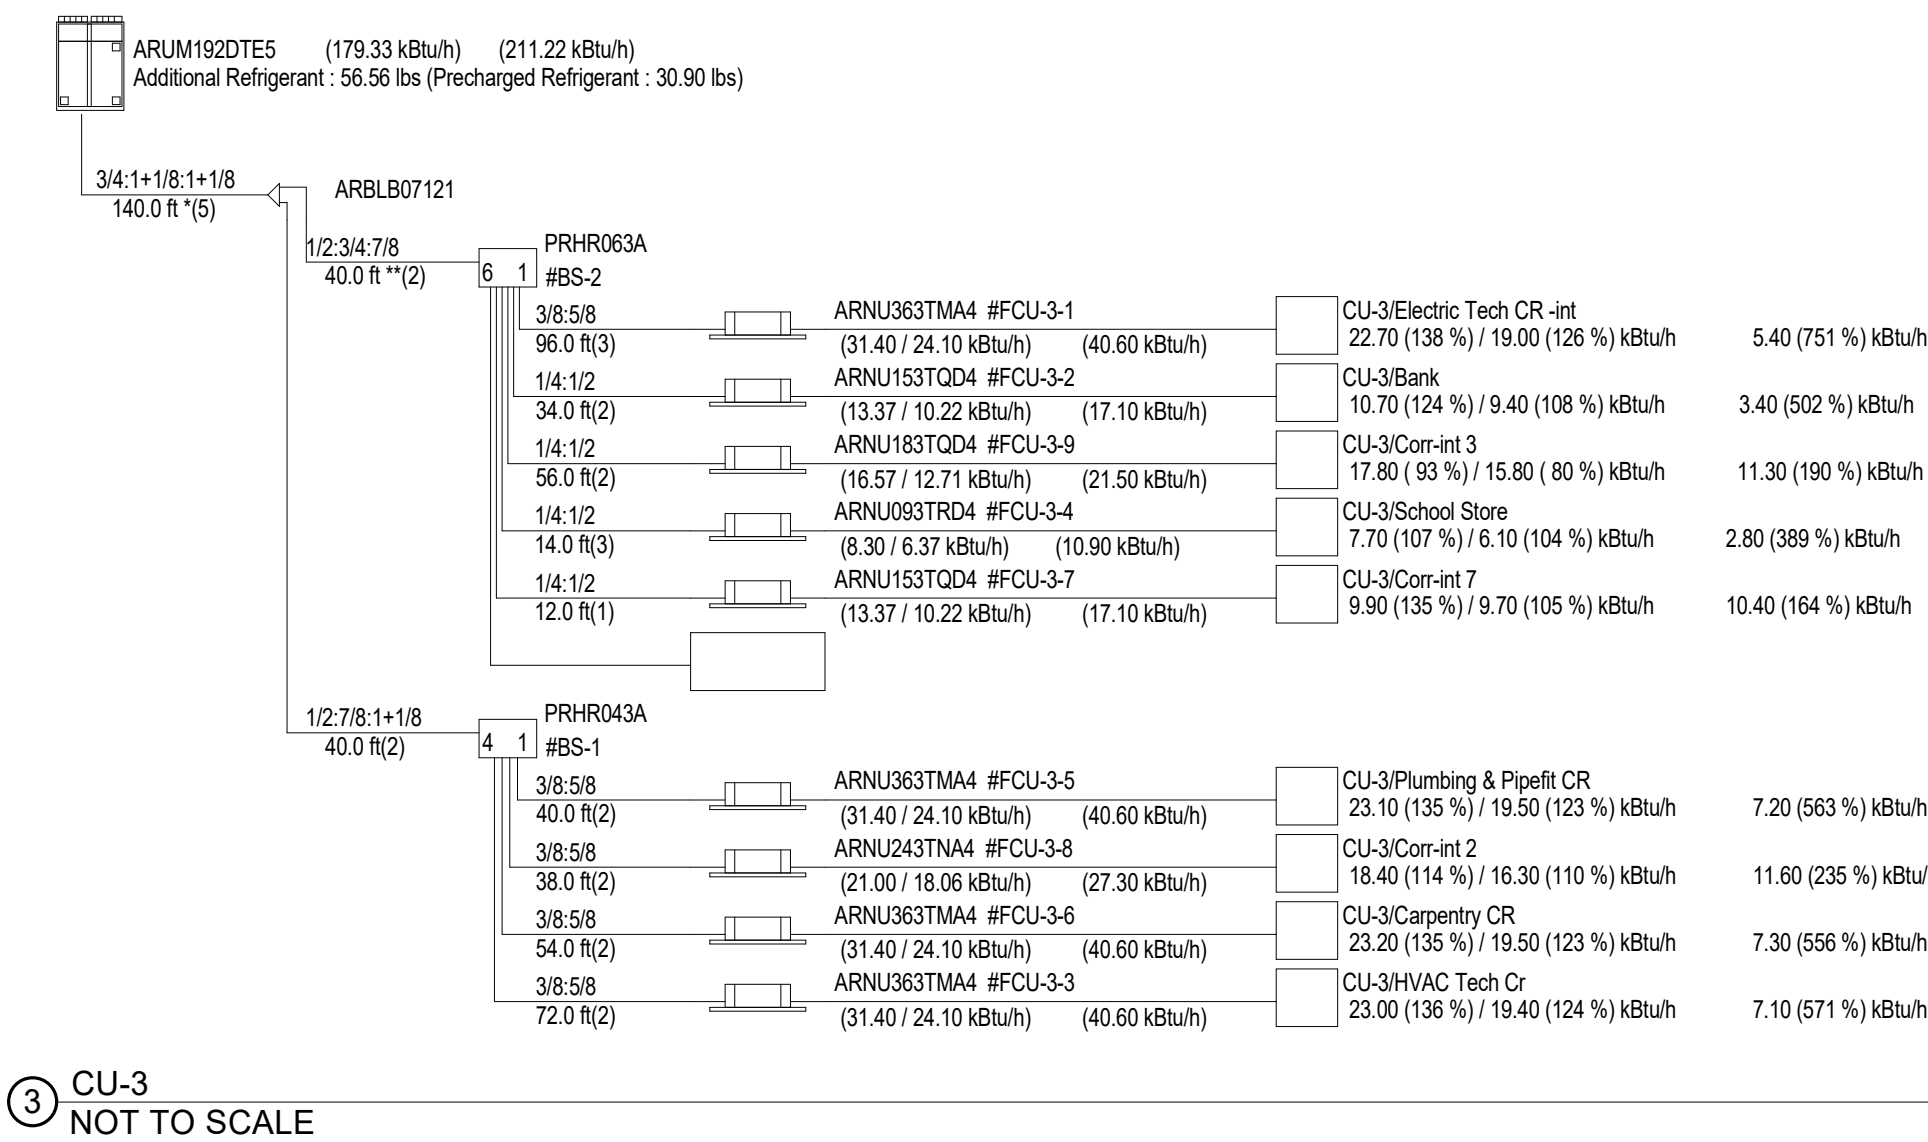


DRA

Drummeys Rosane Anderson, Inc.
225 Oakland Road
Studio 205
South Windsor, CT
06074
260 Charles Street
Studio 300
Waltham, MA
02453
Planning | Architecture | Interior Design
Tel: 617.984.1702
www.dra-inc.com

Northeast
Metropolitan
Regional
Vocational High
School

Wakefield, MA 01880

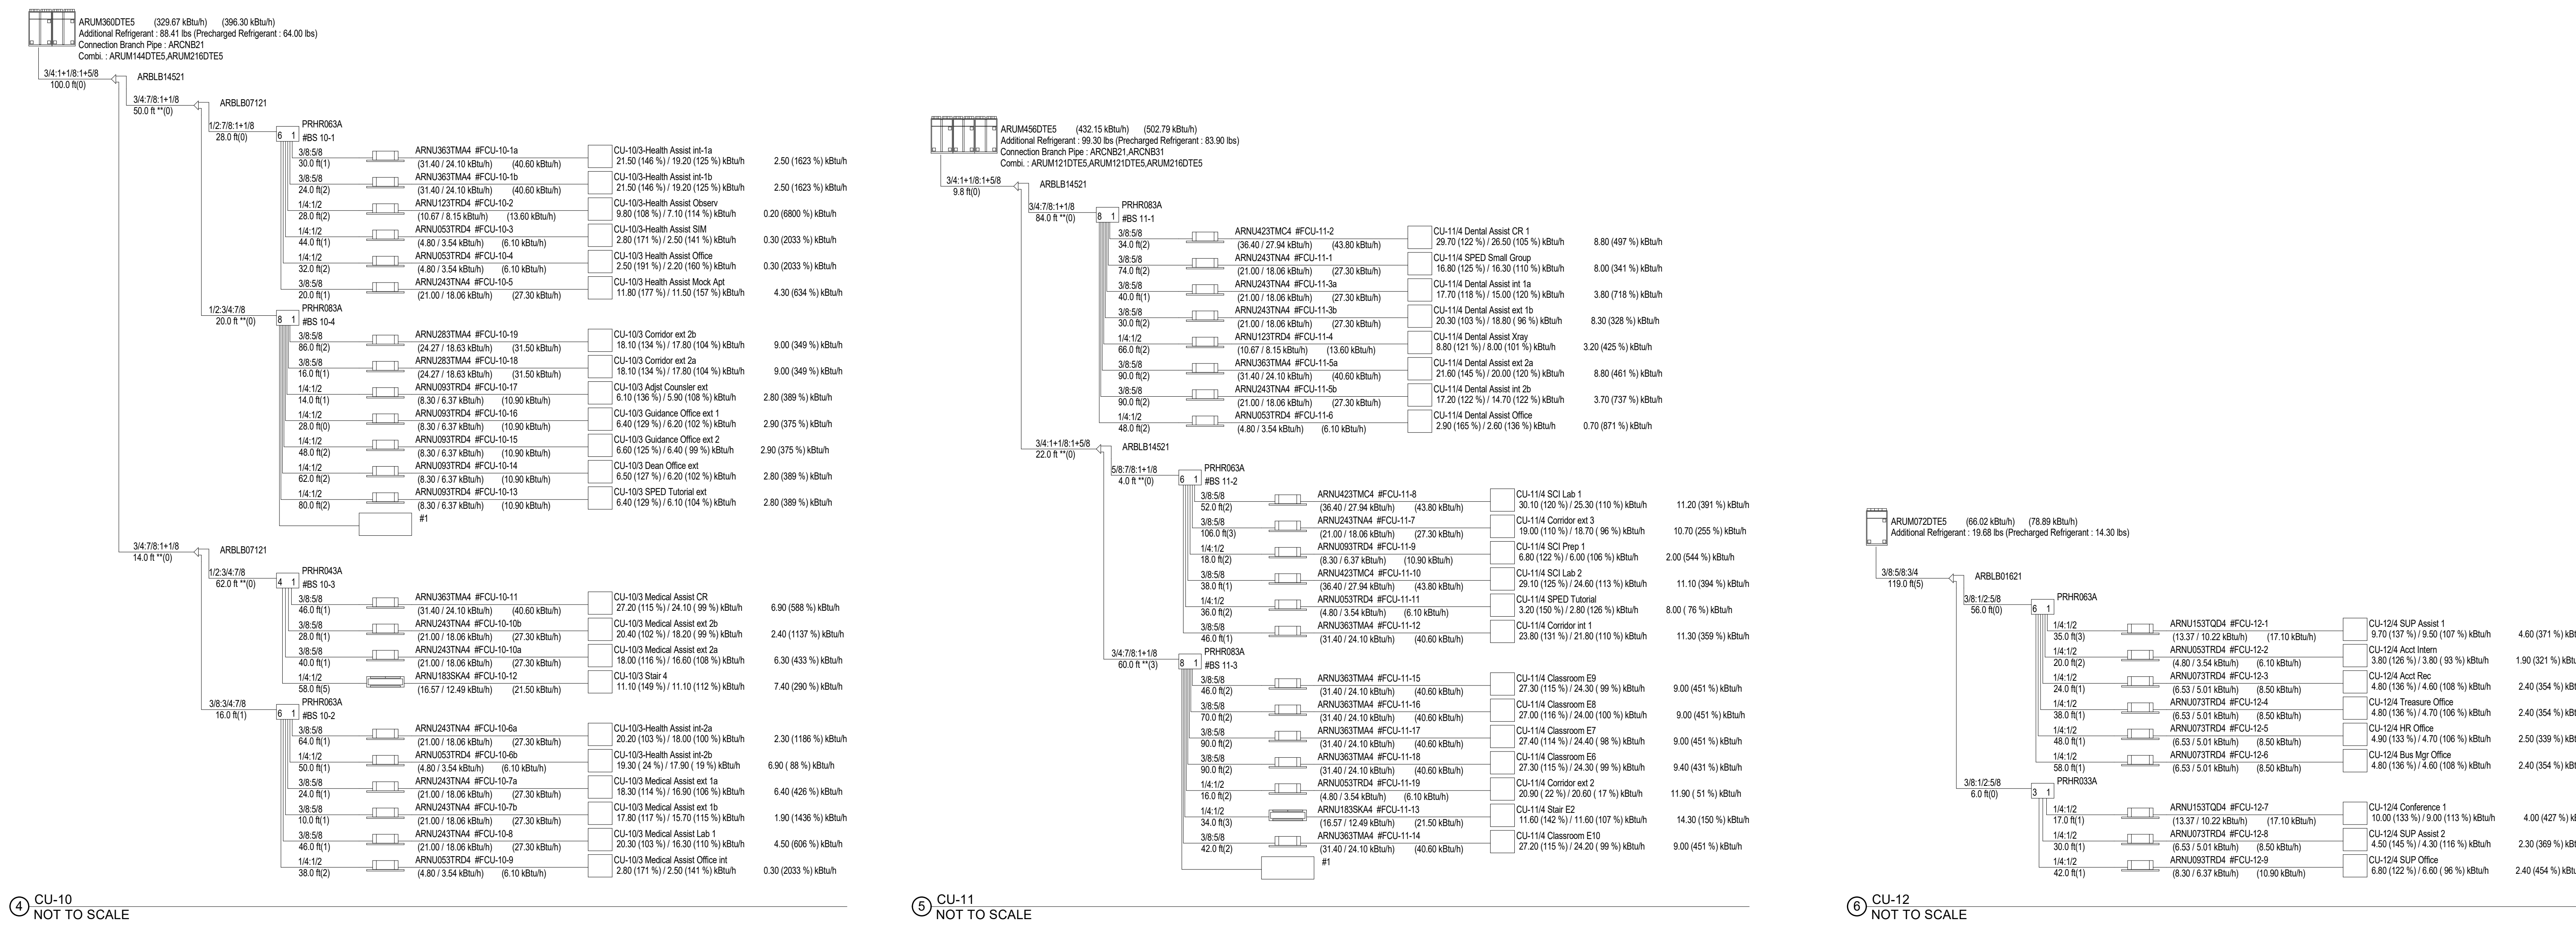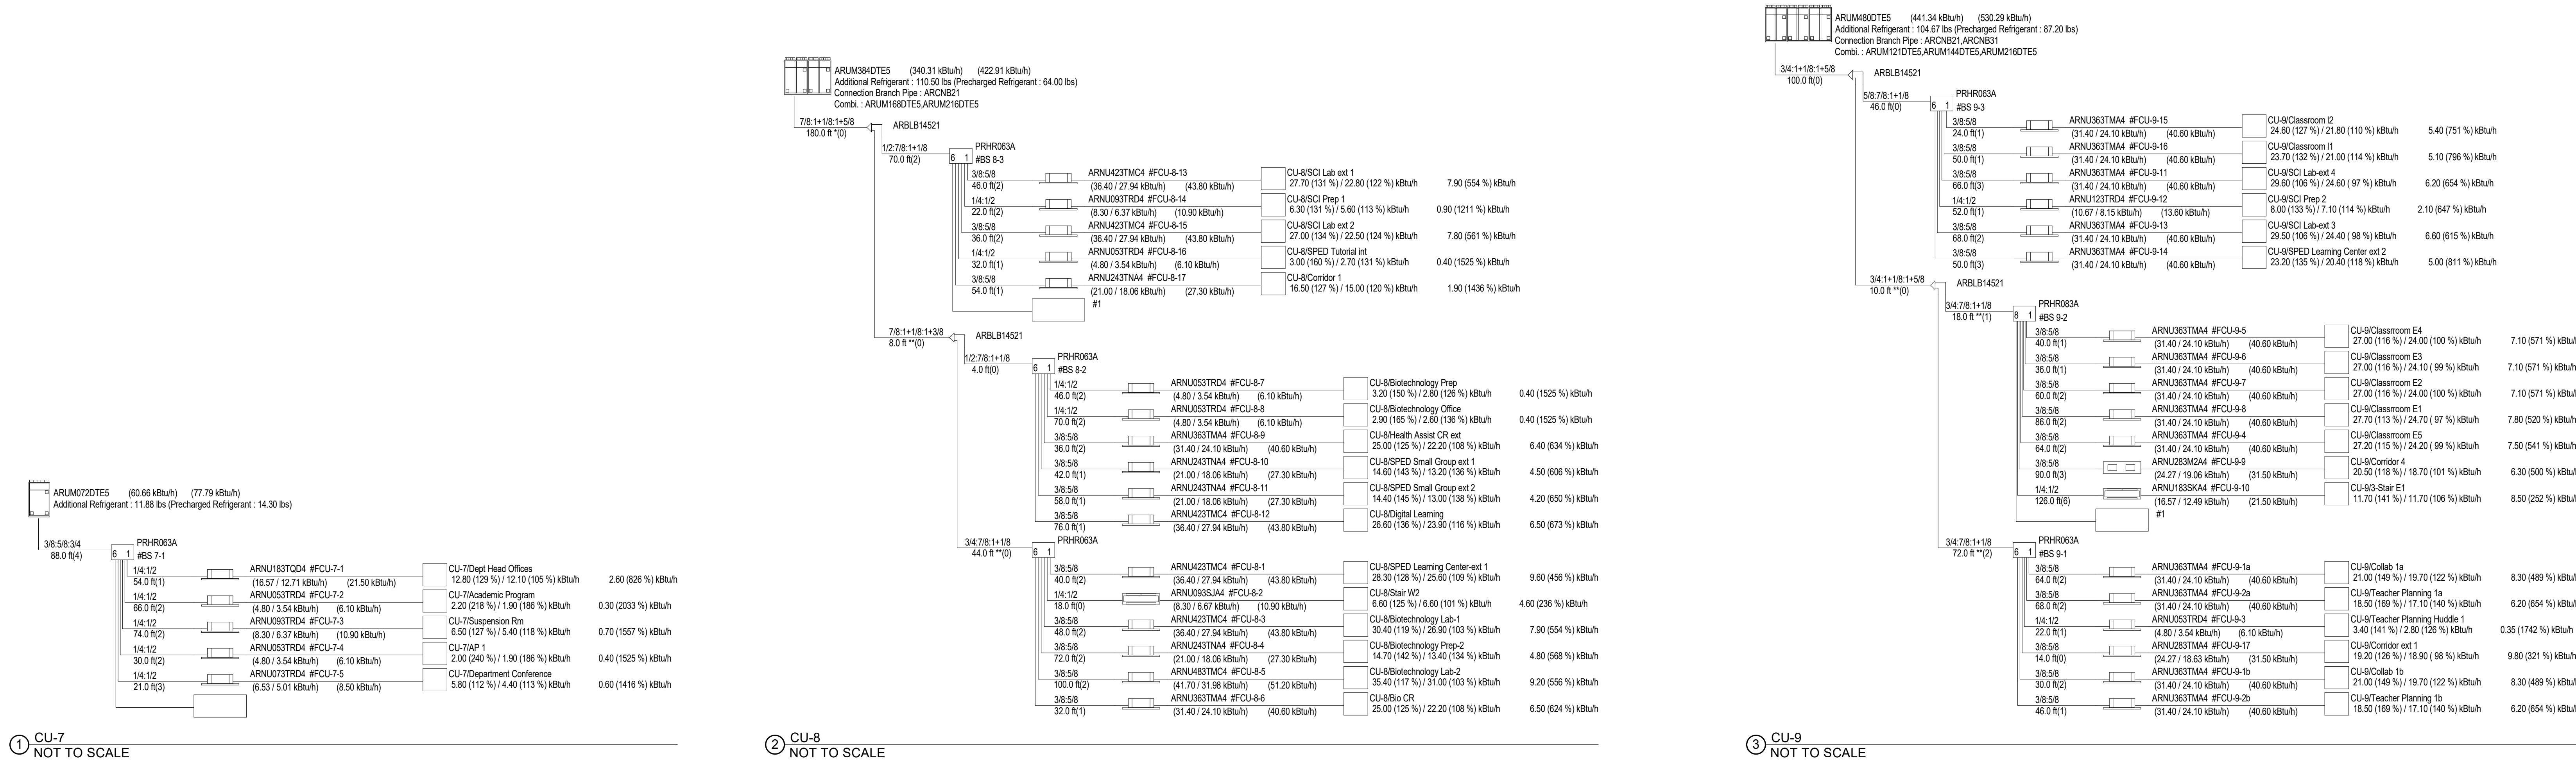

© COPYRIGHT 2021 DRUMMEYS ROSANE ANDERSON, INC.

BALA
ENGINEERS

MSBA 60% CD
SUBMISSION

January 13, 2023

 
 
 
 
 
PROJECT NORTH
MAGNETIC NORTH

MECHANICAL
VRF SYSTEM
DIAGRAMS
SHEET #2

Scale: NOT TO SCALE
Job No.: 20022
Drawn By: DRA
Date: January 13, 2023

M3-0-2

Wakefield, MA 01880

MSBA 60% CD
SUBMISSION

January 13, 2023

Scale: NTS
Job No.: 20202
Drawn By: DRA
Date: January 13, 2023

Scale: NTS
Job No.: 20202
Drawn By: [redacted]
Date: January 13




Drumme Rosane Anderson, Inc.
225 Oakland Road
Studio 205
South Windsor, CT
06074
Planning | Architecture | Interior Design
Tel: 817-984-1700
www.draa.com

**Northeast
Metropolitan
Regional
Vocational High School**

Wakefield, MA 01880





MSBA 60% CD
SUBMISSION
January 13, 2023

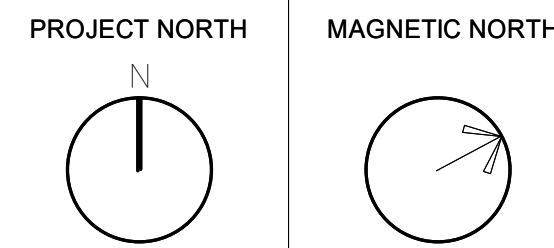


**MECHANICAL
AIR RISER
DIAGRAMS**


Scale: NTS
Job No.: 20202
Drawn By: DRA
Date: January 13, 2023

M3-0-4

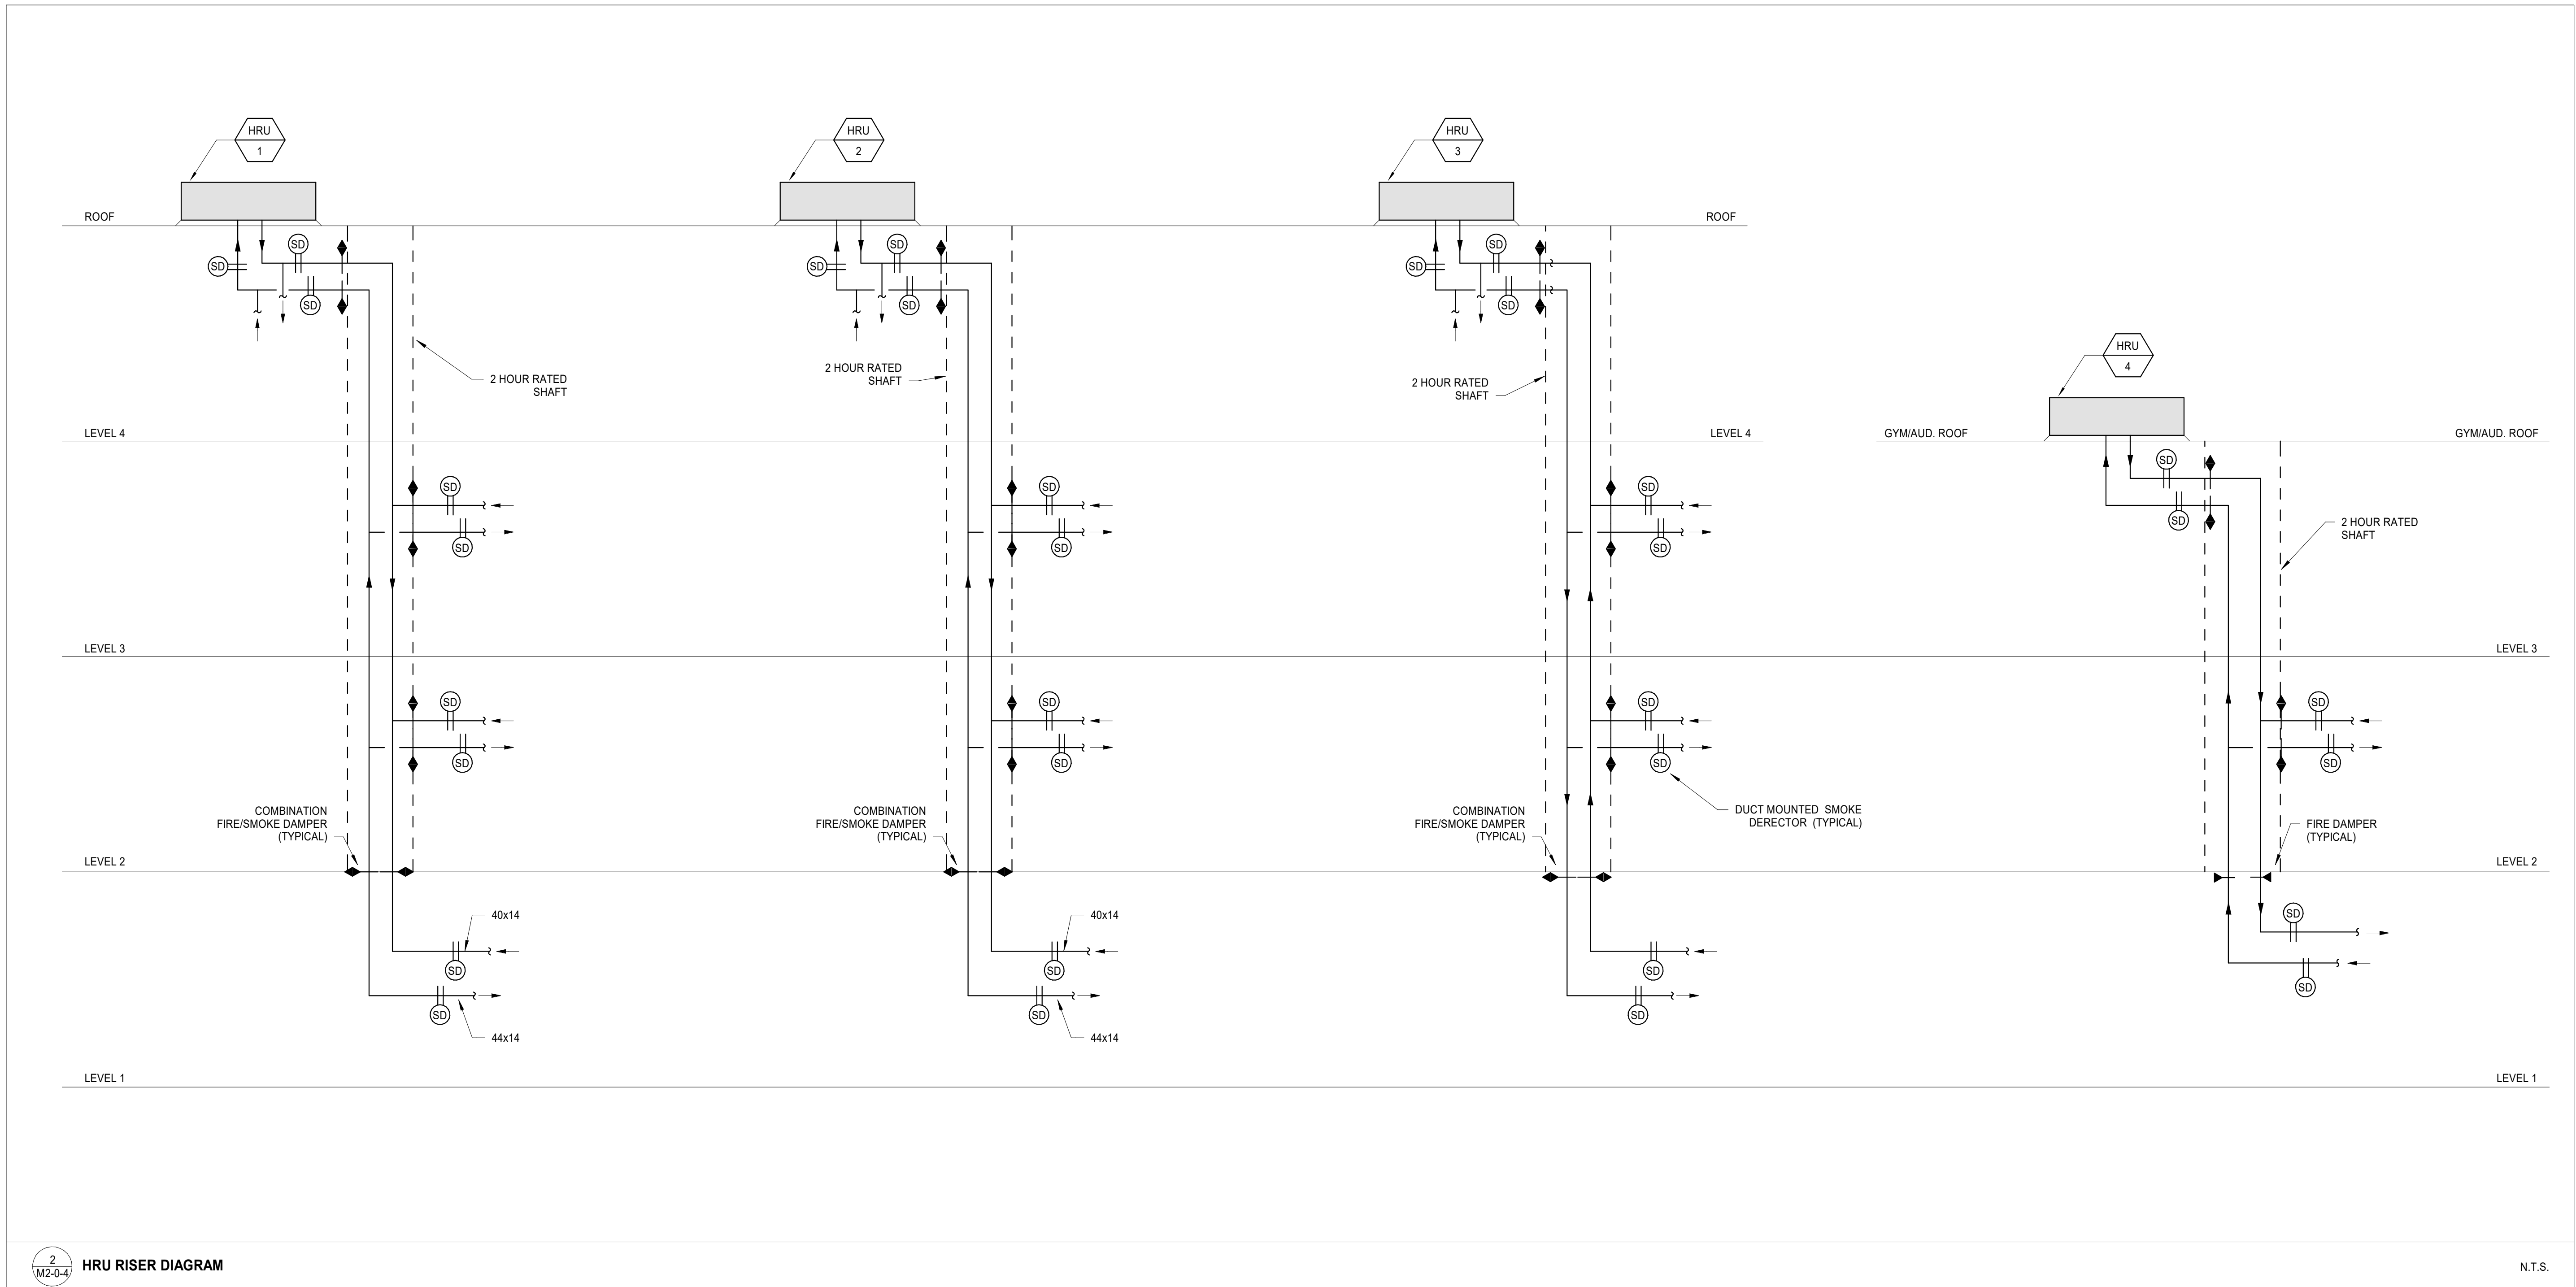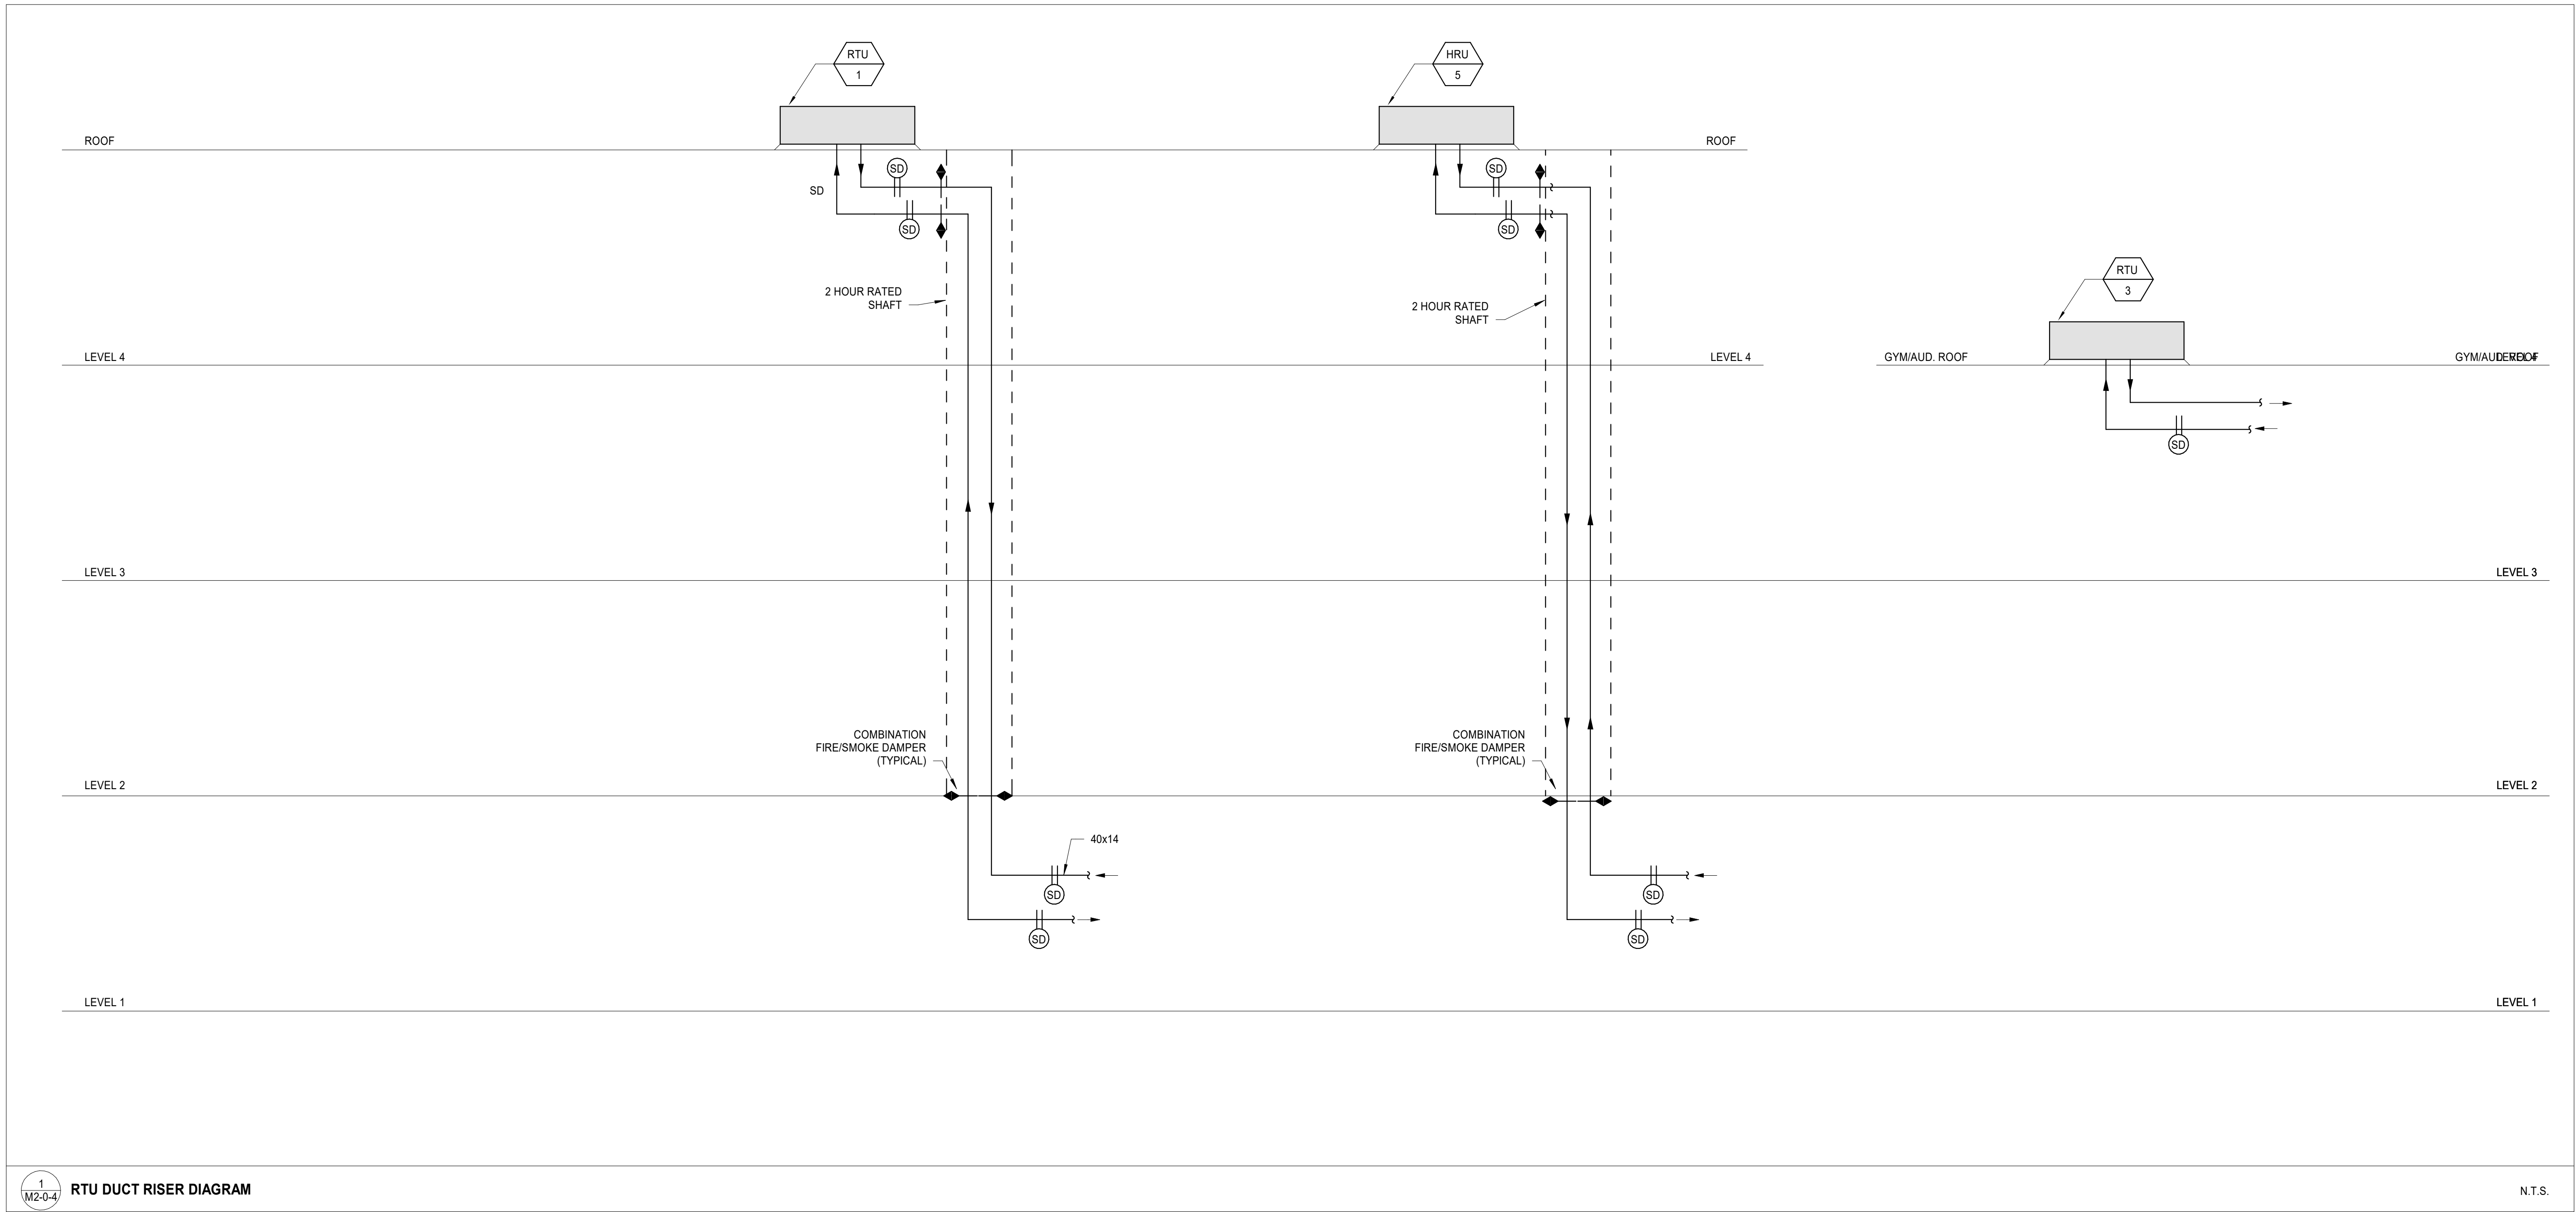

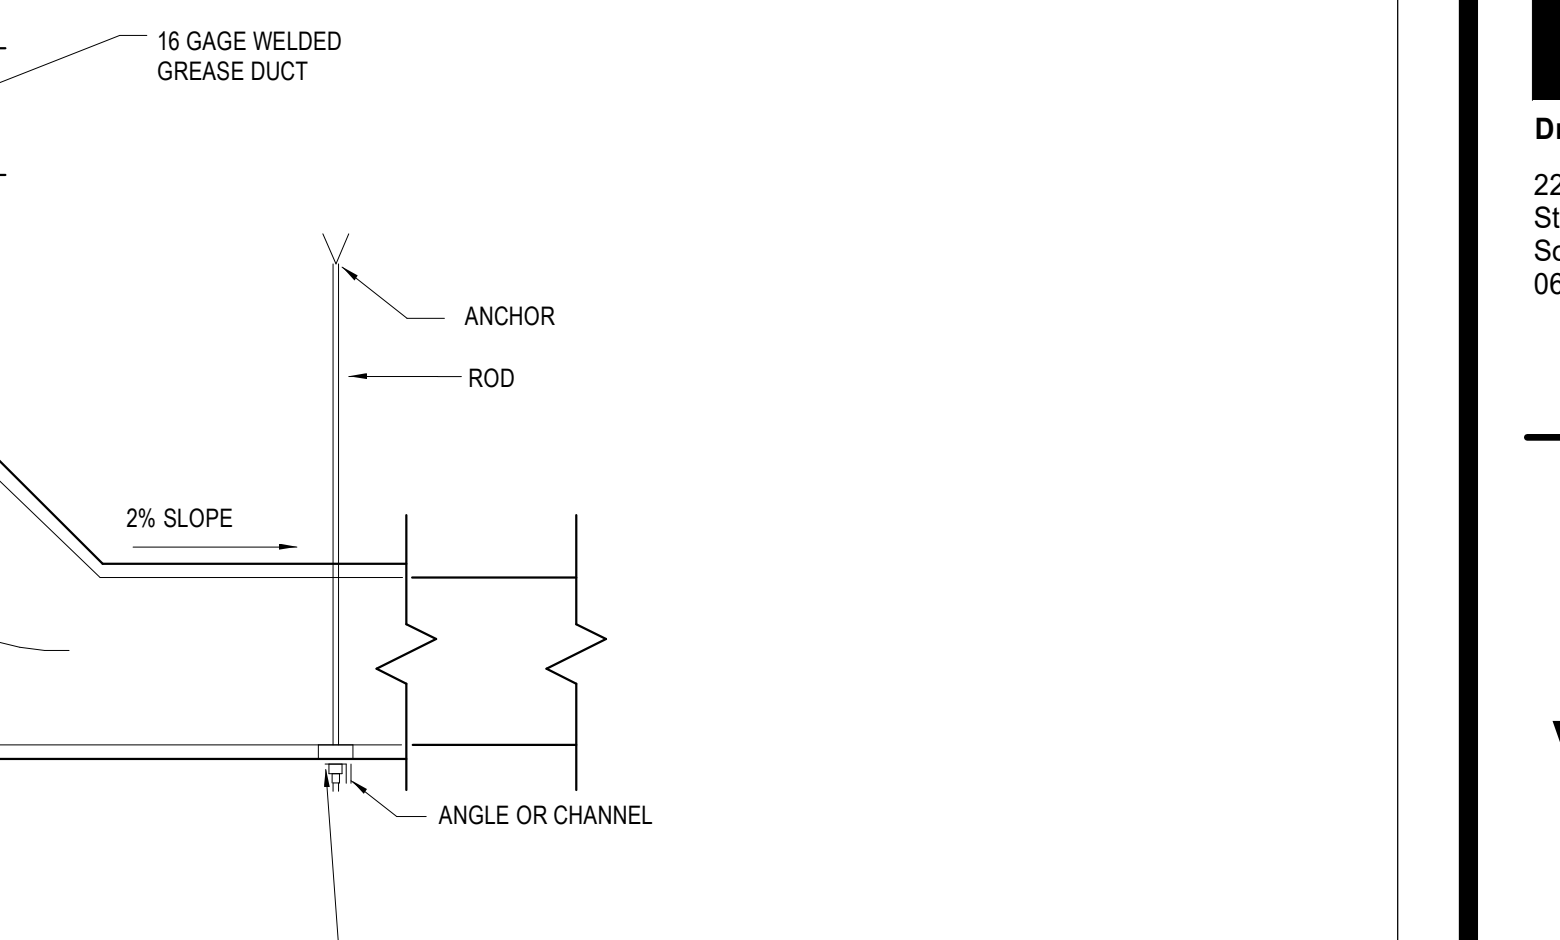


NOTE:
1. RISER AND HANGER SUPPORT ANGLES AND FASTENERS SHALL BE ARRANGED IN ACCORDANCE WITH SMACNA STANDARDS.

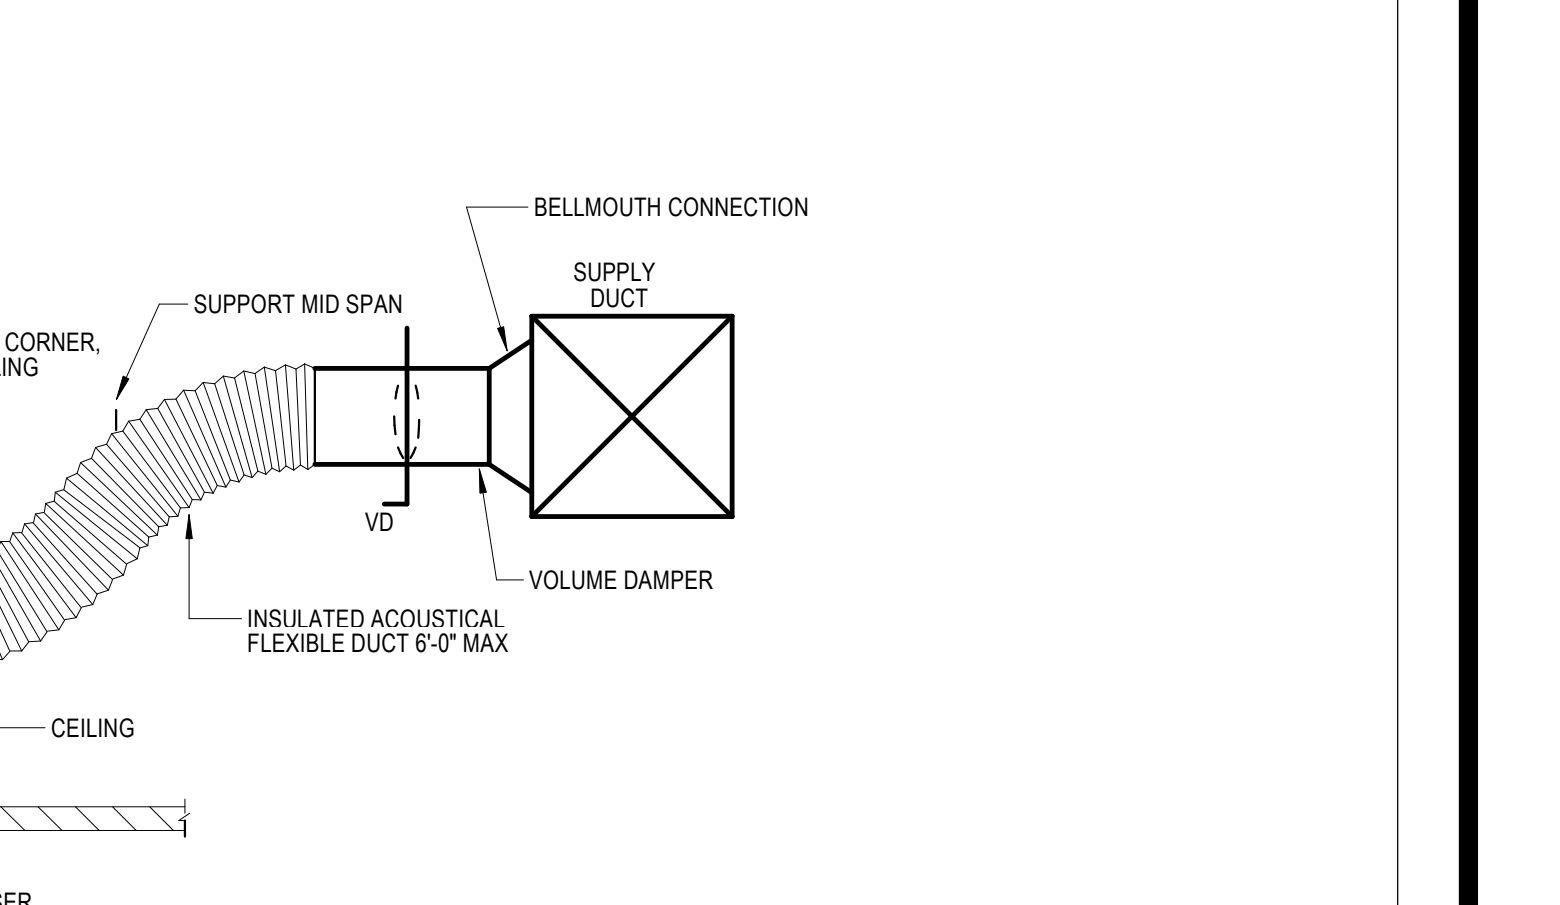

NOTES:

1. MAXIMUM LENGTH OF FLEXIBLE DUCT SHALL NOT EXCEED _____ FEET.









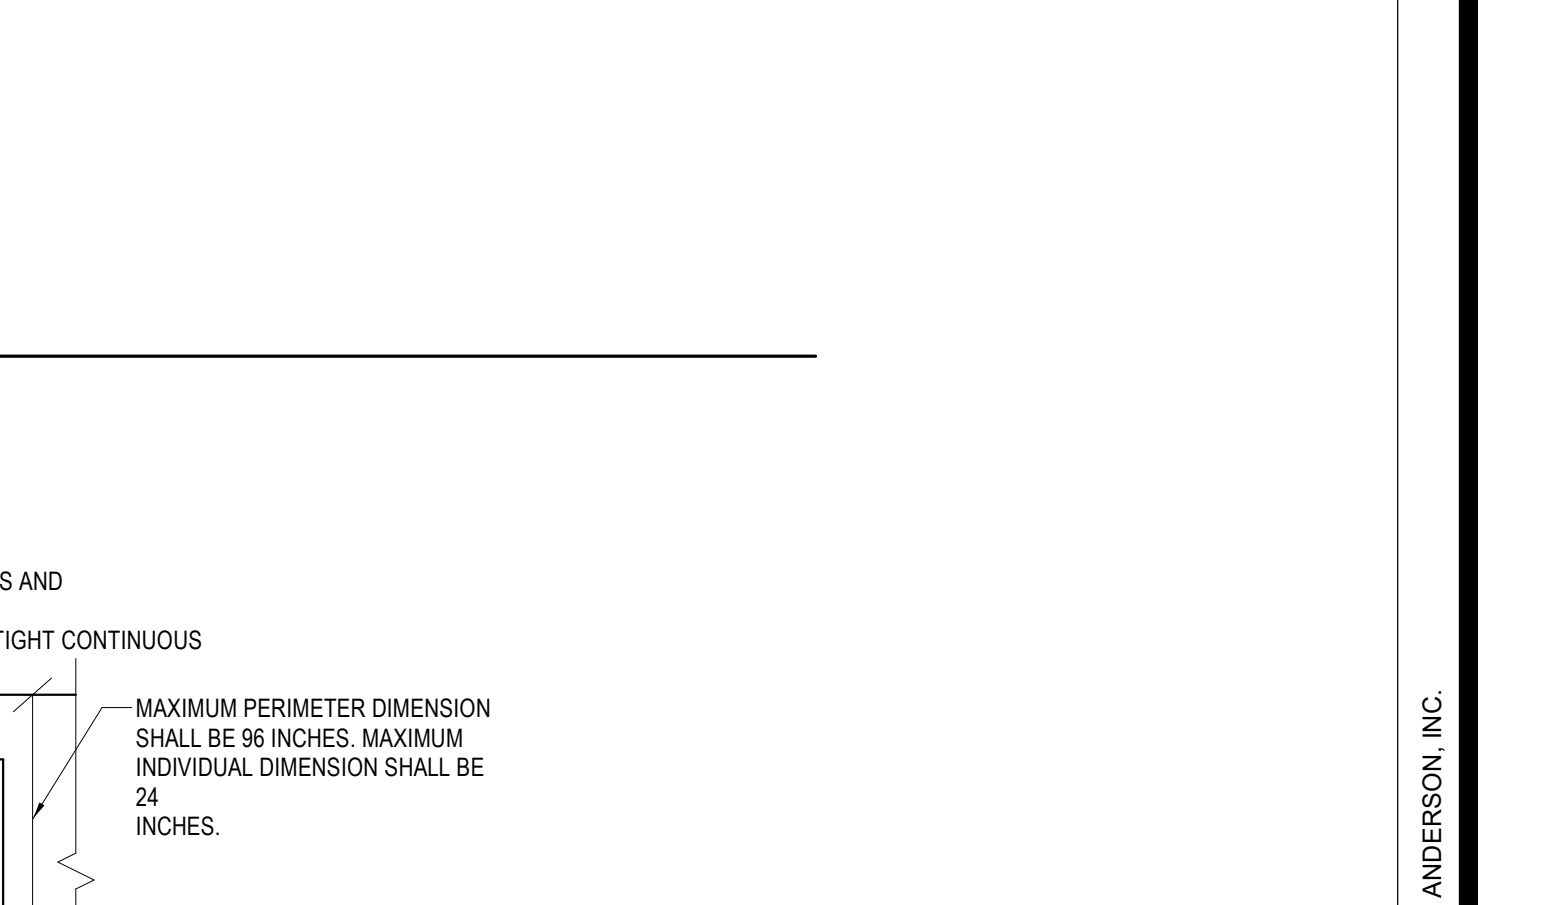


ACCESS PANEL


ACCESS FRAMES

688,
TYPE 31
SHELL
AND ALL






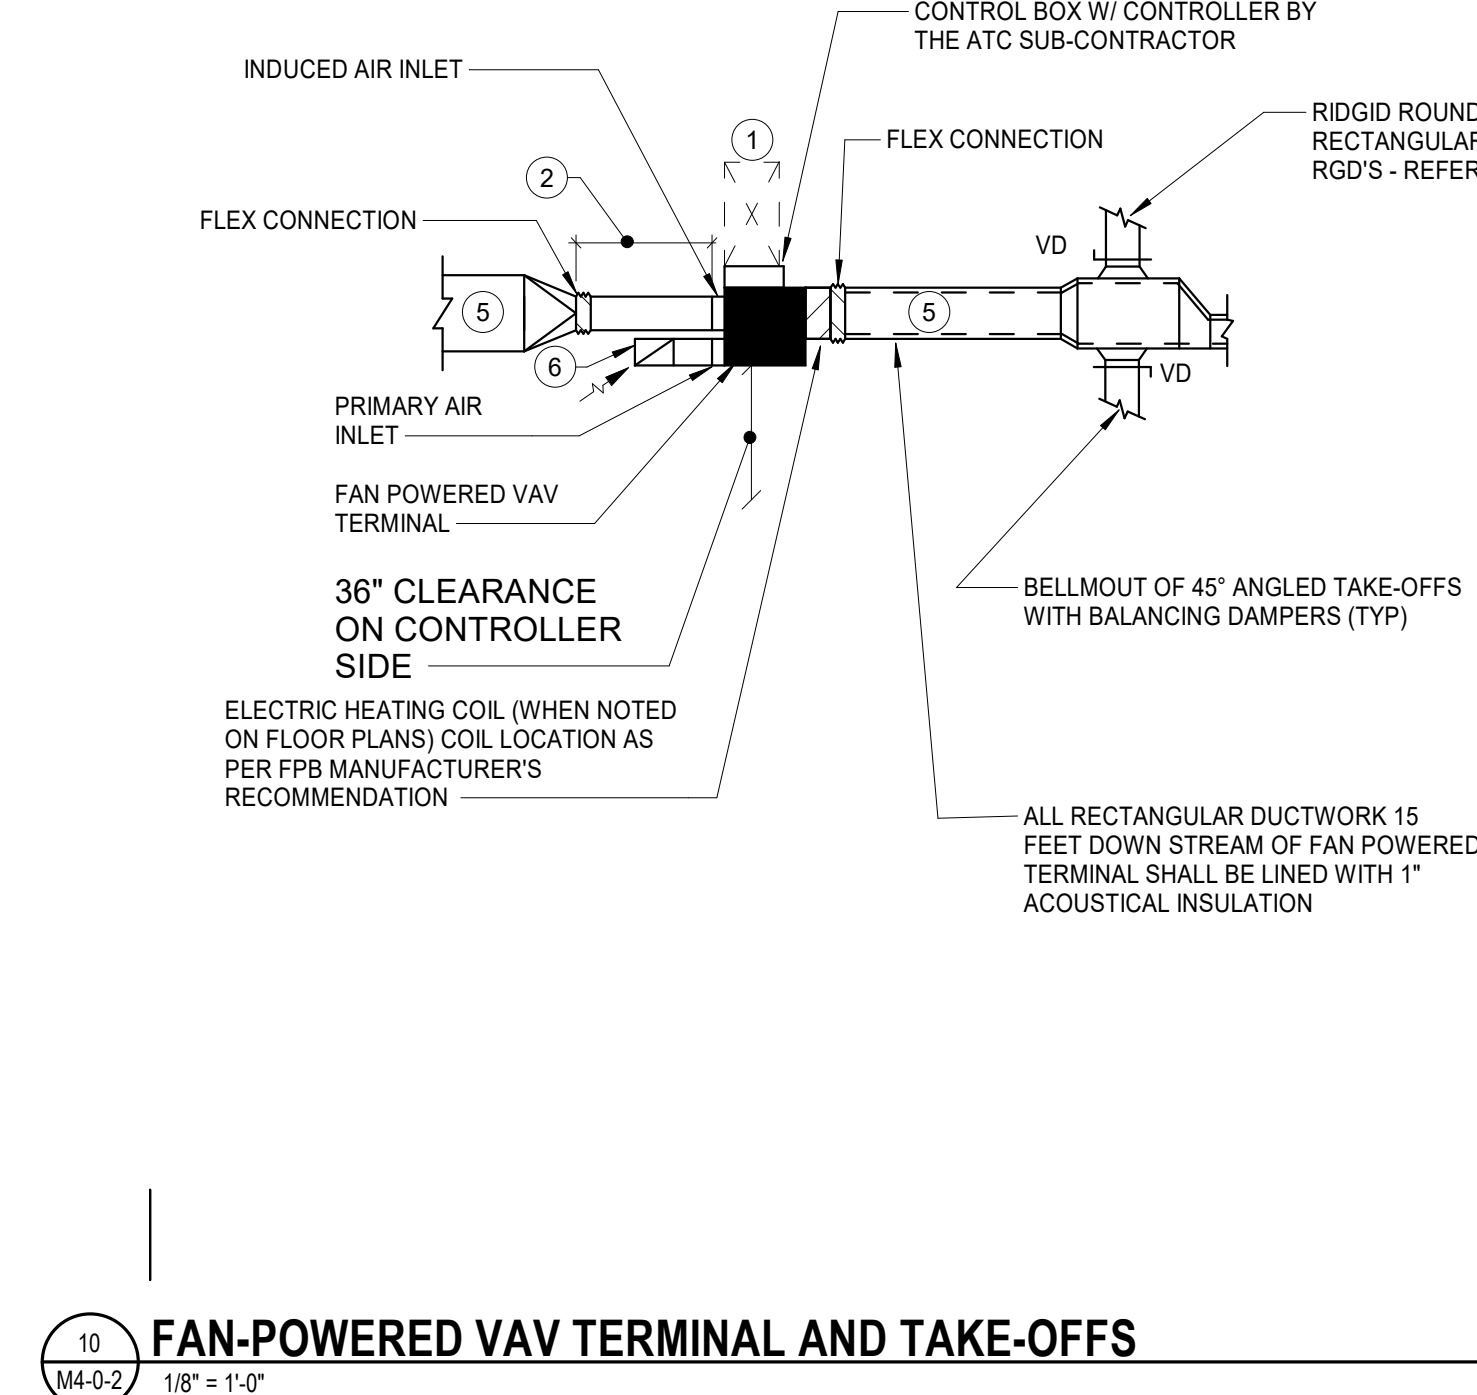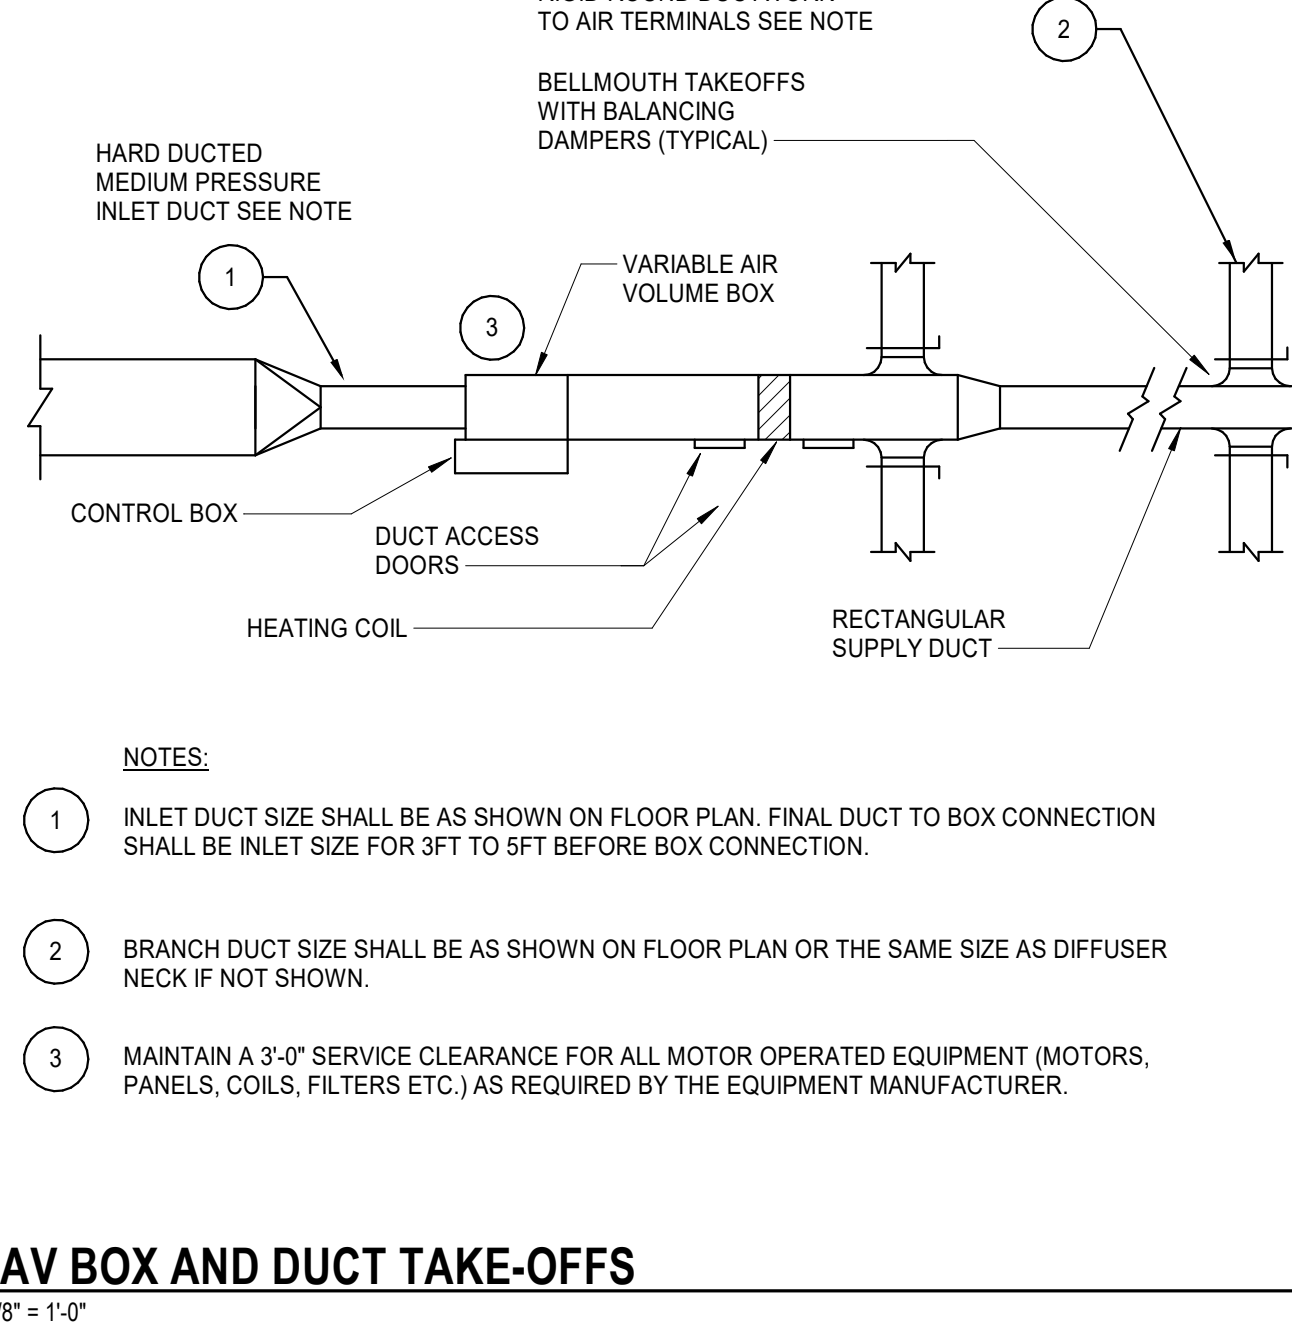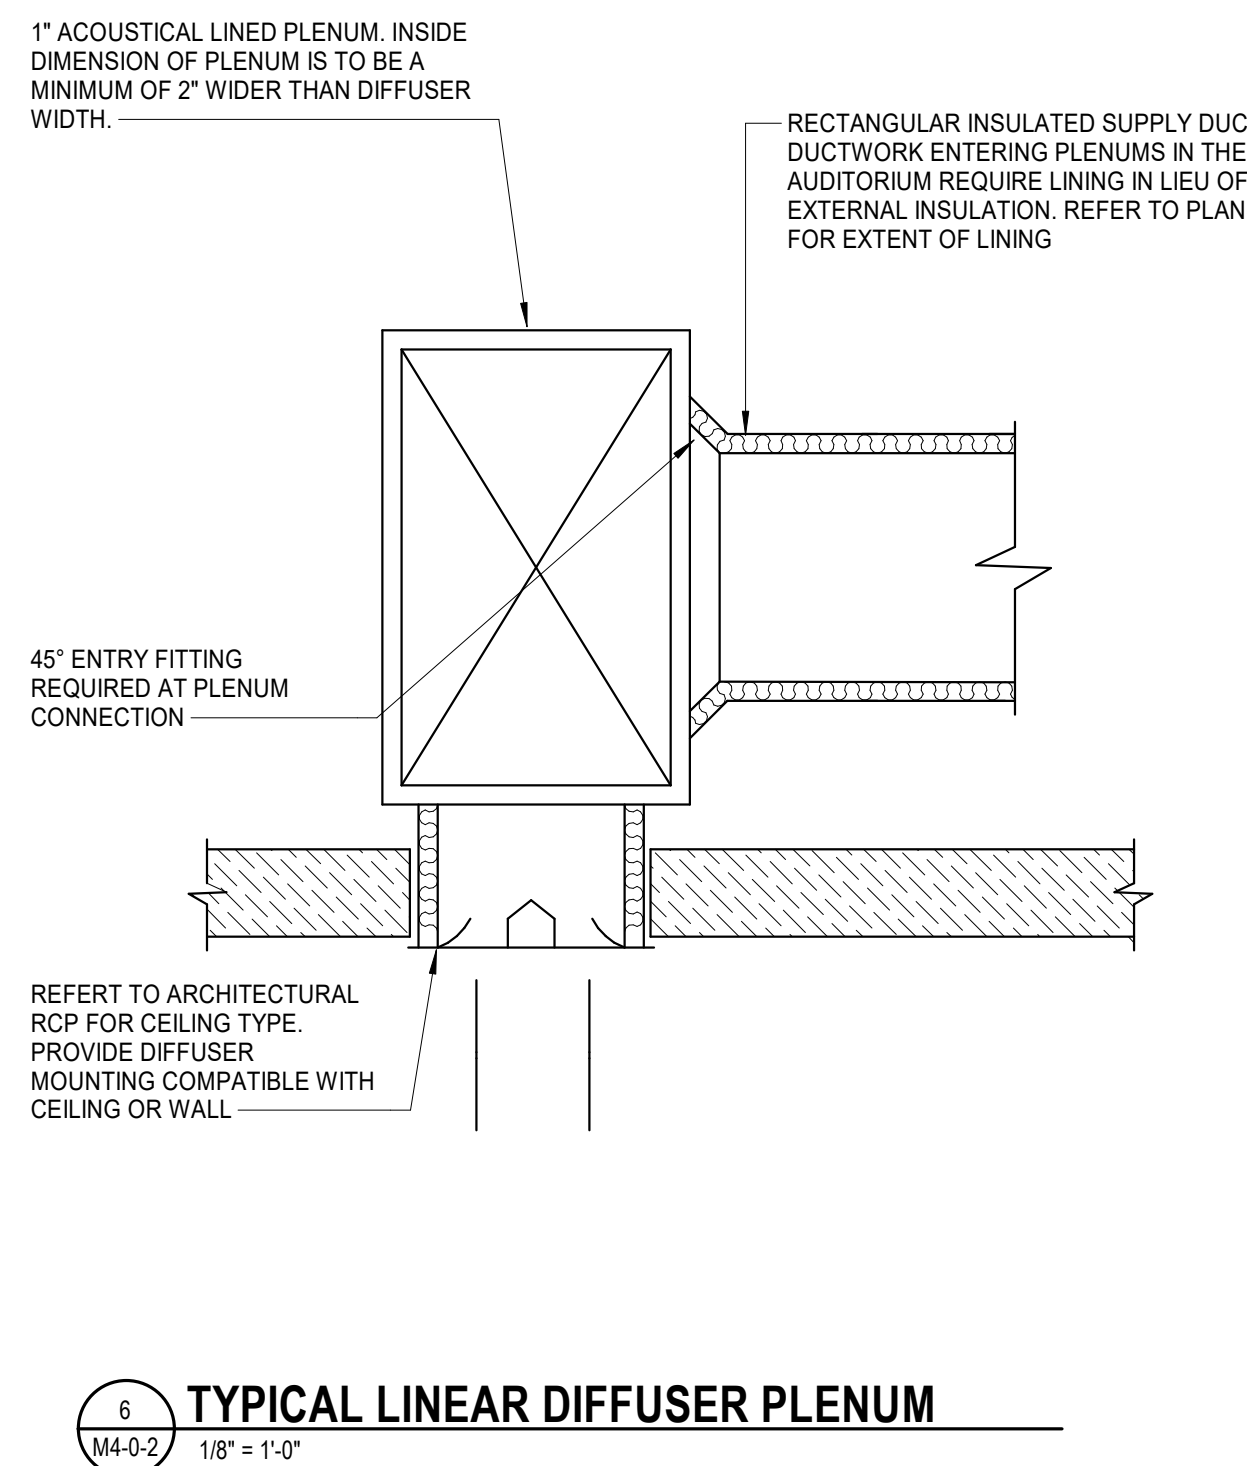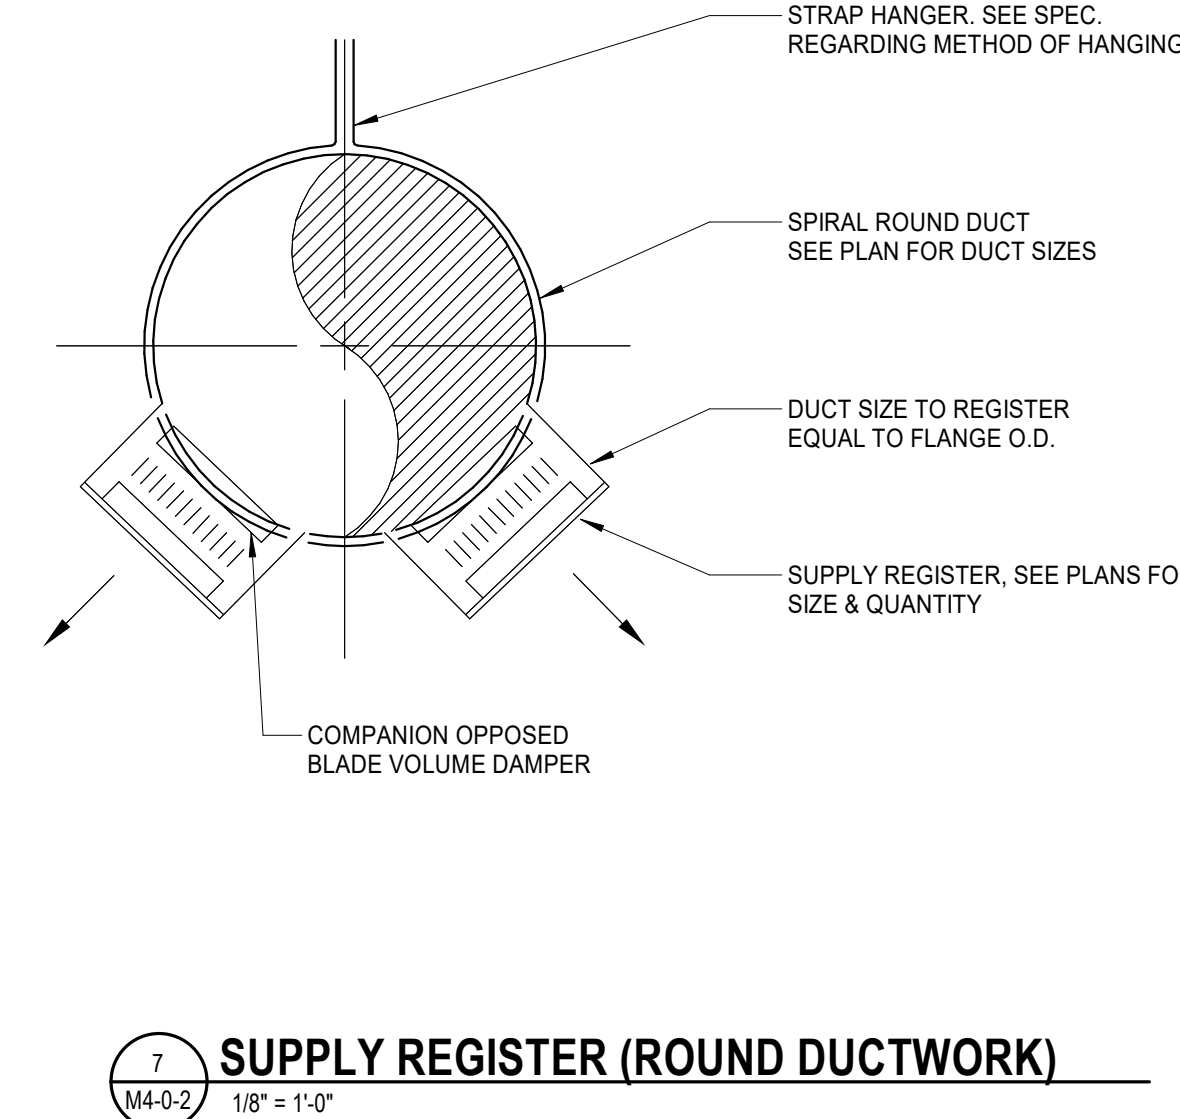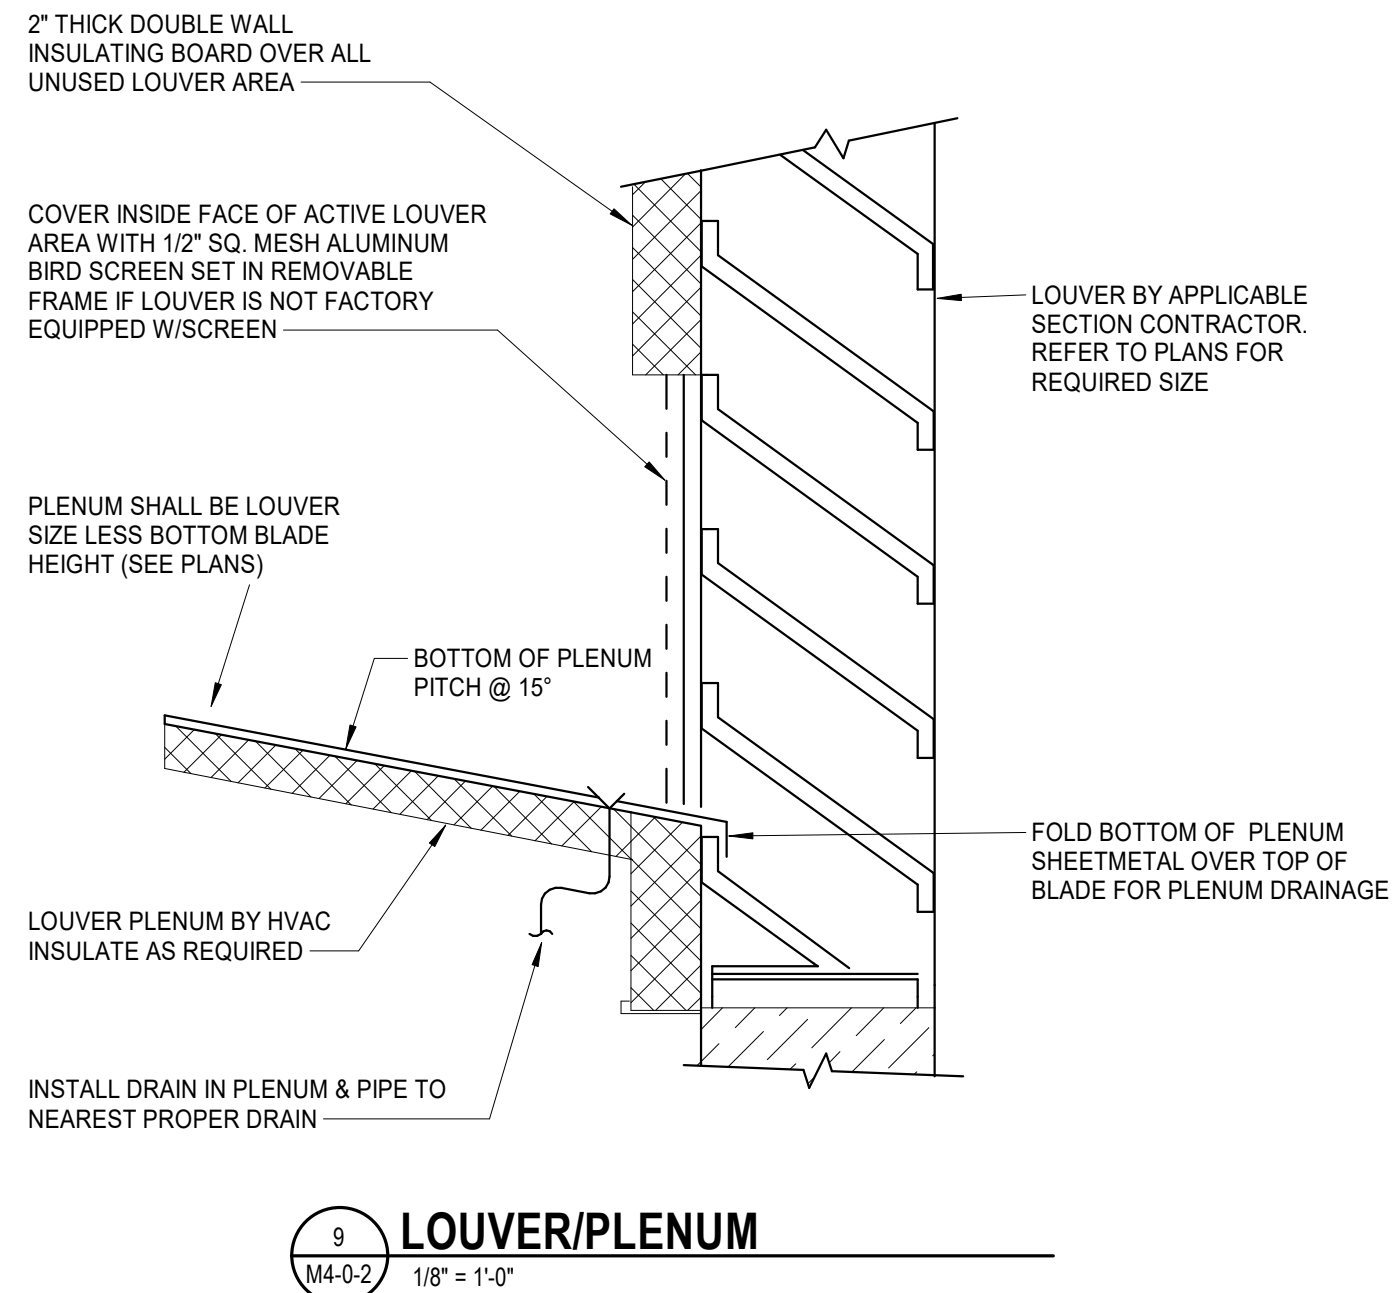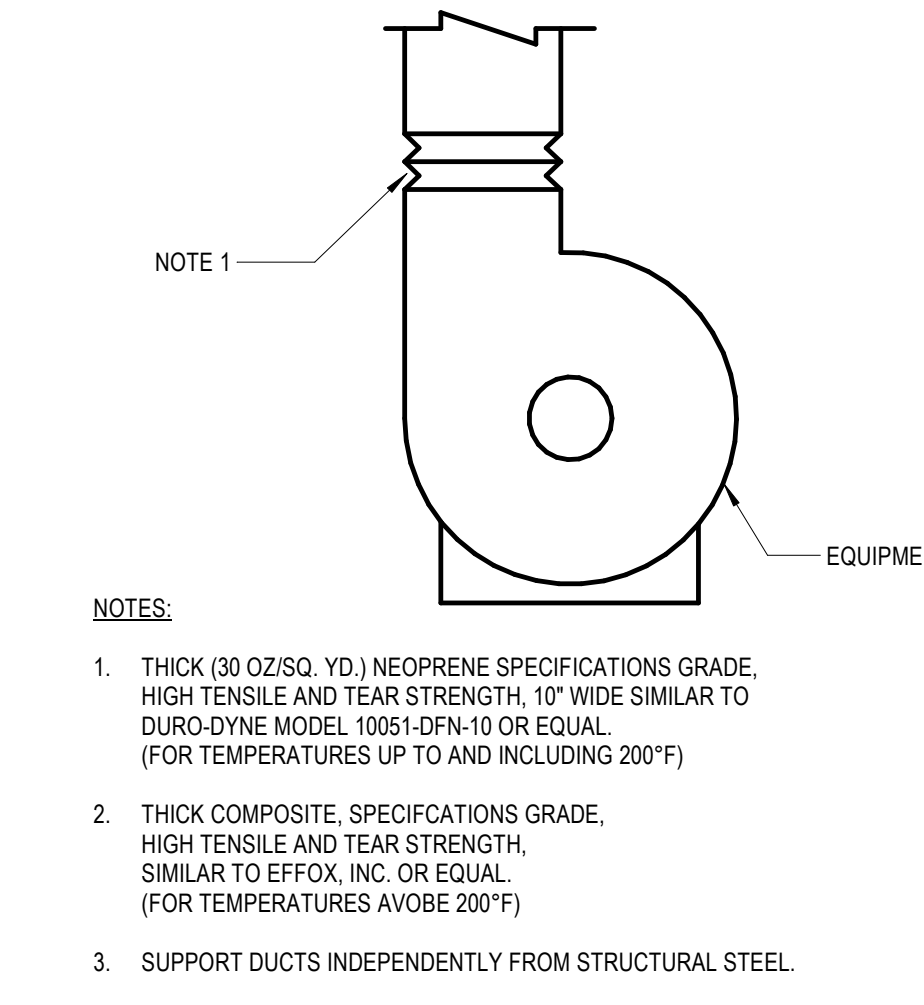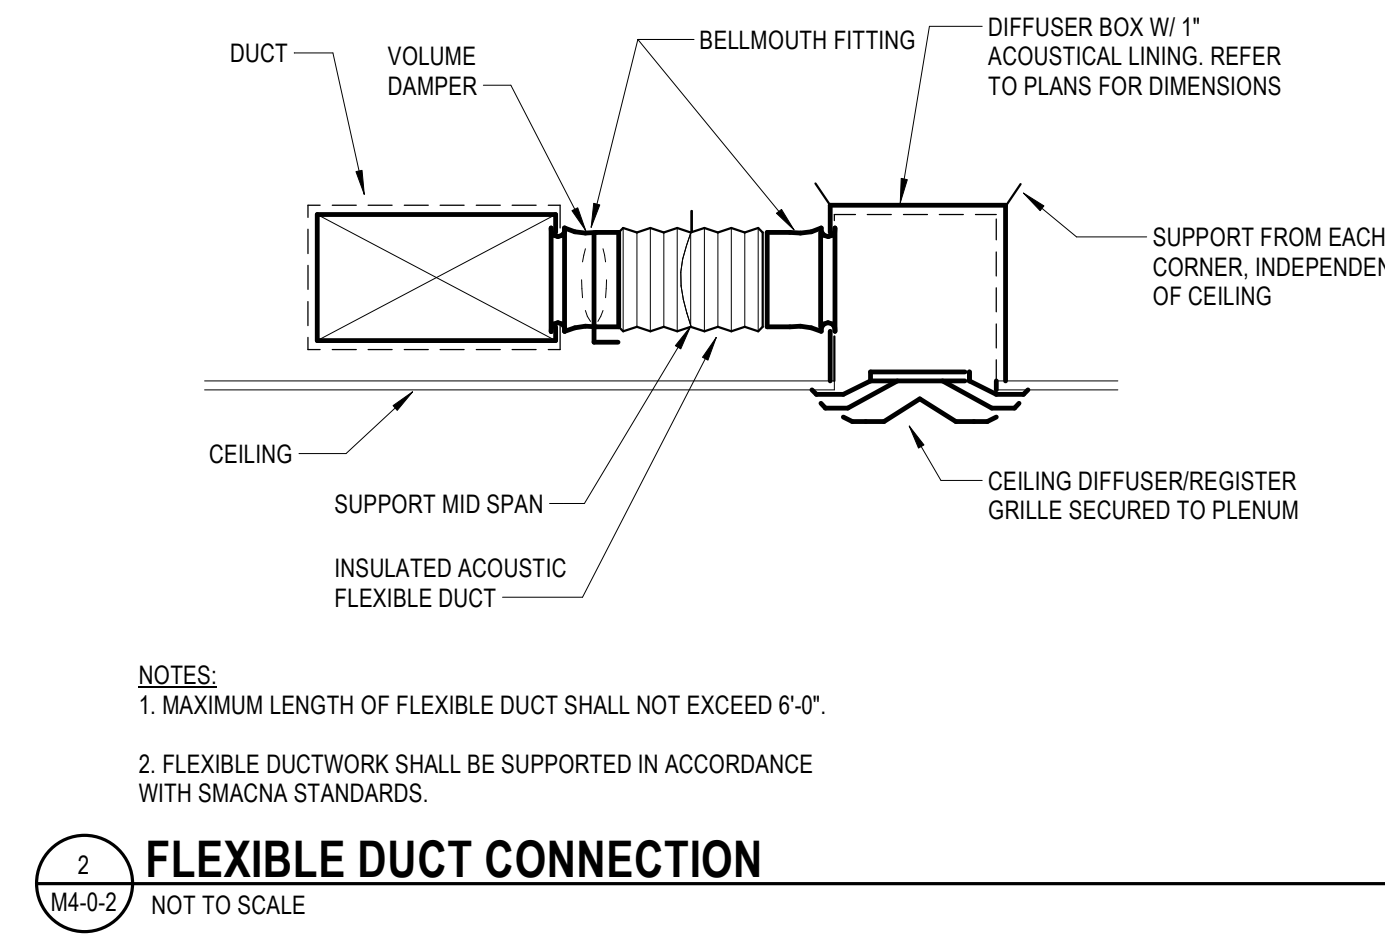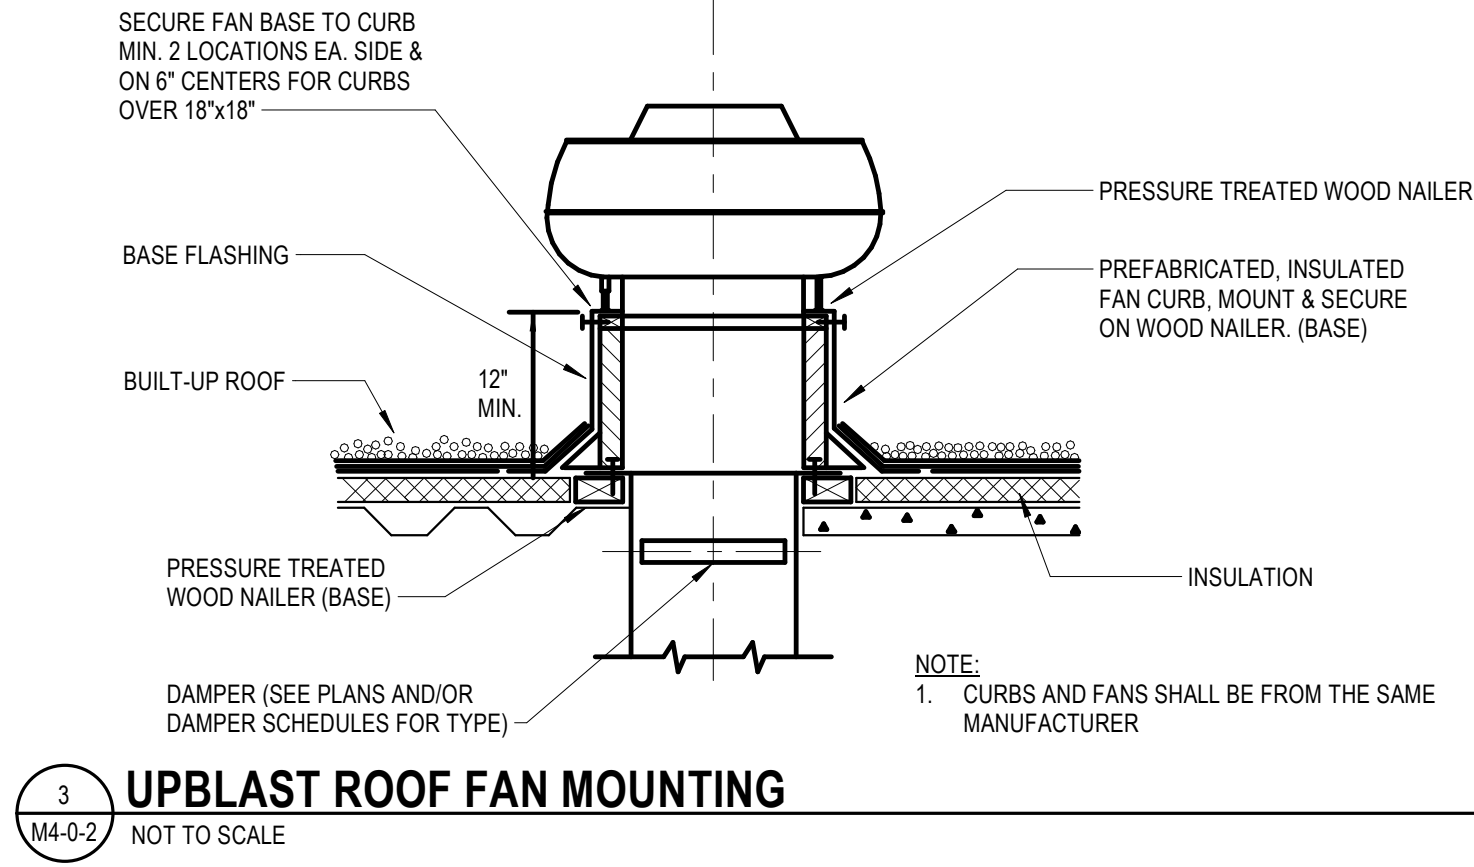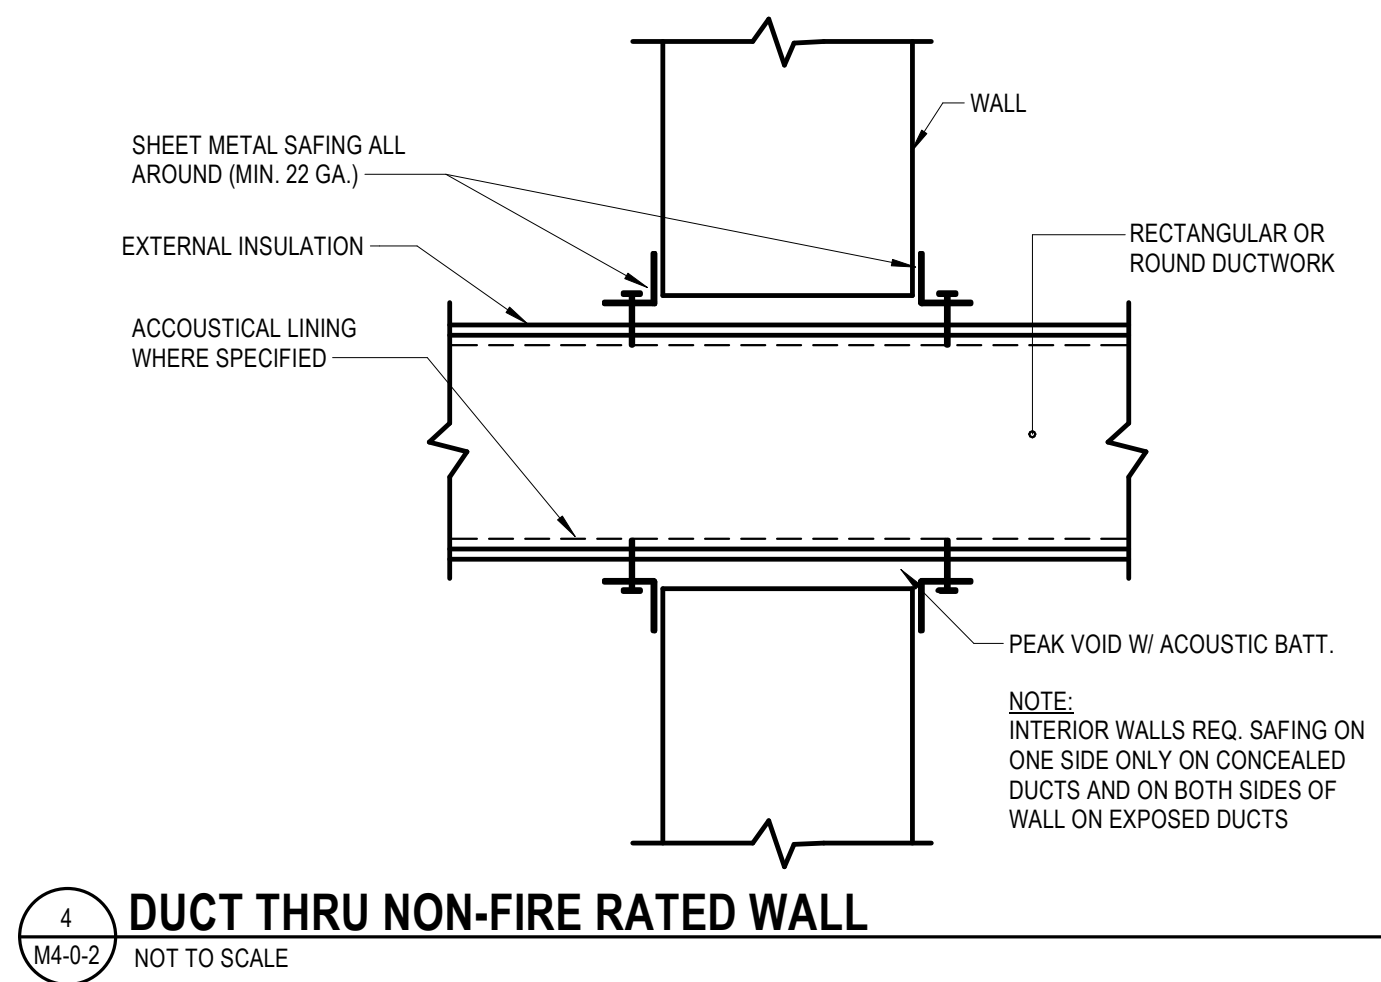

- NOTES:**
1. PROVIDE A MINIMUM OF 36" CLEARANCE IN FRONT OF THE ELECTRIC CONTROL PANEL(S) AS PER THE NATIONAL ELECTRIC CODE/NO. PIPING, DUCTWORK, BUILDING STRUCTURE, ETC. SHALL BE IN THIS MAINTENANCE ZONE-COORDINATE WITH ALL TRADES. INSTALL BOX W/ REQUIRED MANUFACTURER'S CLEARANCES ALL AROUND.
 2. 24" MINIMUM LENGTH OF INLET-SIZE STRAIGHT DUCTWORK FROM TERMINAL CONNECTION TO DUCTWORK TRANSITION AT THE RECTANGULAR PRESSURE.
 3. ALL BOXES SHALL BE INSTALLED PER THIS DETAIL.
 4. BRANCH DUCT SIZE SHALL BE AS SHOWN ON FLOOR PLAN OR SHALL BE THE SAME SIZE AS DIFFUSER NECK IF NOT INDICATED.
 5. DUCT SIZE TO BE AS SHOWN ON PLANS. TRANSITION TO BOX CONNECTION INLET/DISCHARGE SIZES AS REQUIRED.
 6. LINED SOUND DEFLECTION RA DUCT BOOT, TAPERED UP AT ANGLE W/ OPENING AT TOP PROVIDED BY BOX MFR. DUCT BOOT SIZE TO MATCH BOX RA OPENING SIZE. PROVIDE MIN. 4" HORIZ. RUN.
 7. FRB TO BE WRAPPED IN MASS-LOADED VINYL (SOUNDSEAL 8-10 OR EQUAL) W/ MIN. SURFACE DENSITY OF 1.0 LB/SQ FT AND A 1" QUILTED INSULATING UNDERLAY. SERVICE ACCESS PANELS TO BE MAINTAINED BY VELCRO ATTACHMENT OF WRAP TO PANELS.

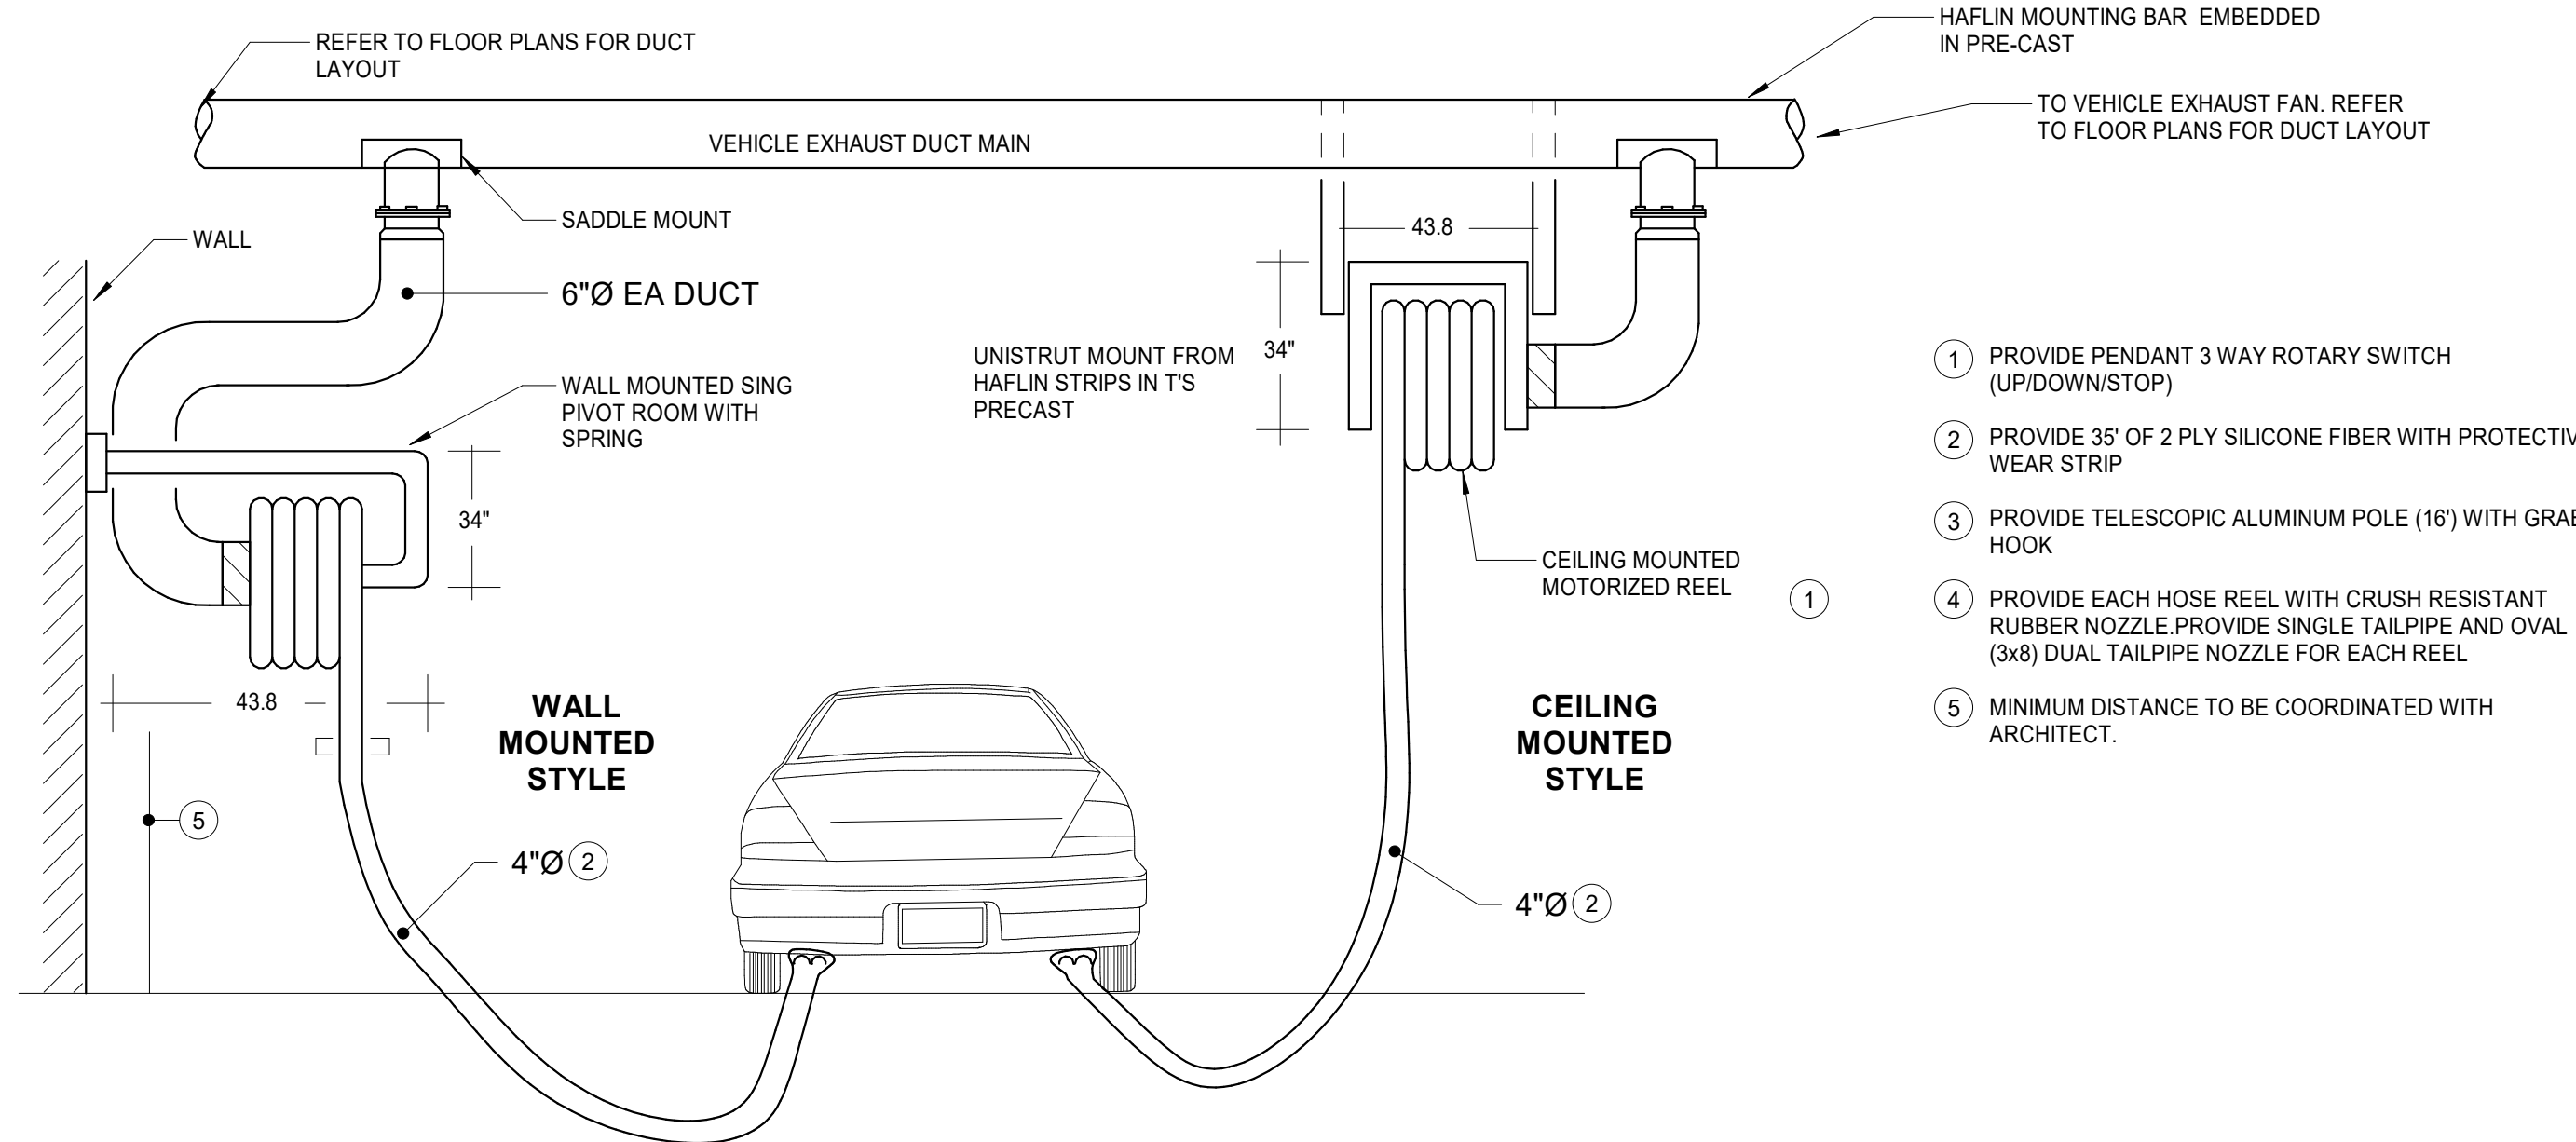

- NOTES:**
1. PROVIDE PENDANT 3 WAY ROTARY SWITCH (UP/DOWN/STOP)
 2. PROVIDE 30' OF 2 PLY SILICONE FIBER WITH PROTECTIVE WEAR STRIP
 3. PROVIDE TELESCOPIC ALUMINUM POLE (16") WITH GRAB HOOK
 4. PROVIDE EACH HOSE REEL WITH CRUSH RESISTANT RUBBER NOZZLE. PROVIDE SINGLE TAILPIPE AND OVAL (3/8") DIA. TAILPIPE NOZZLE FOR EACH REEL.
 5. MINIMUM DISTANCE TO BE COORDINATED WITH ARCHITECT.

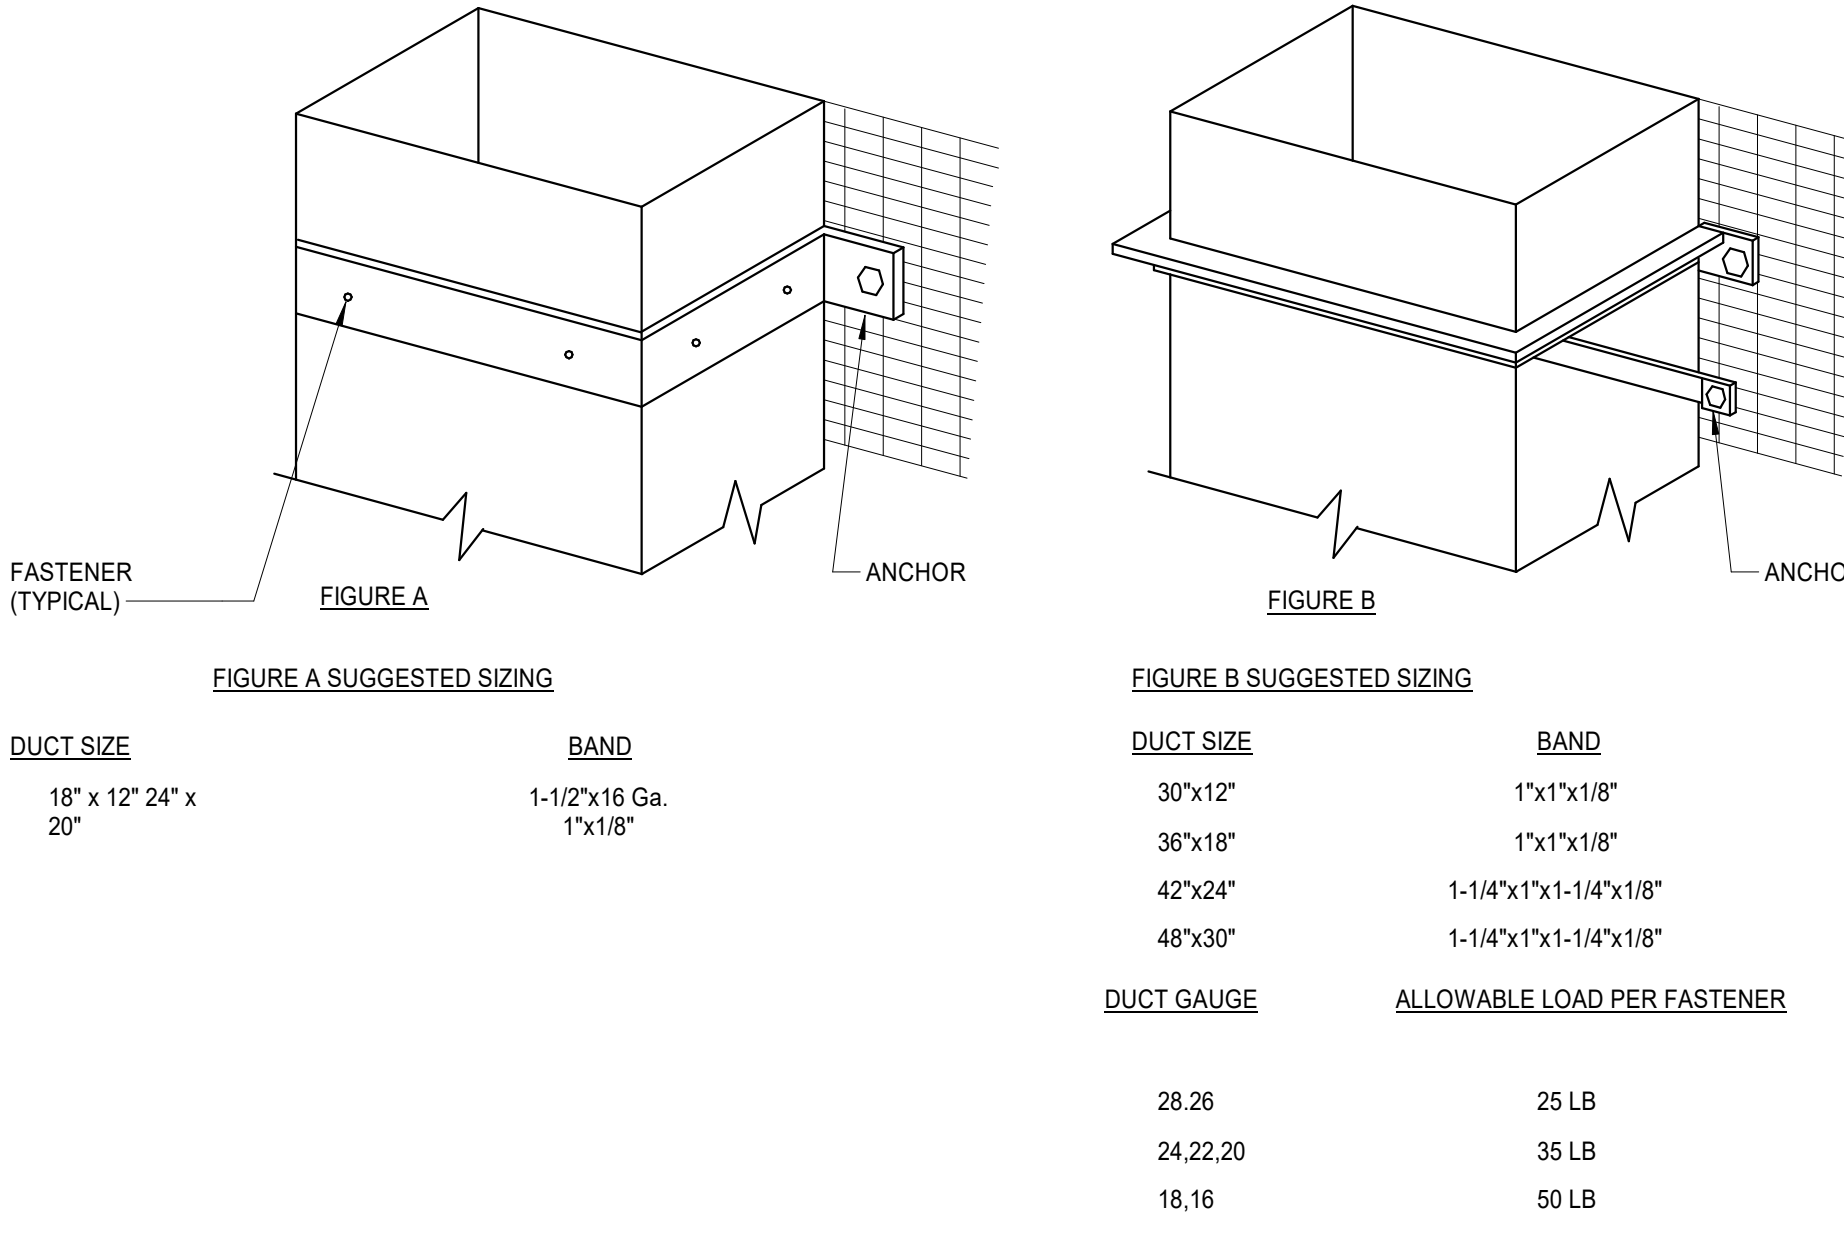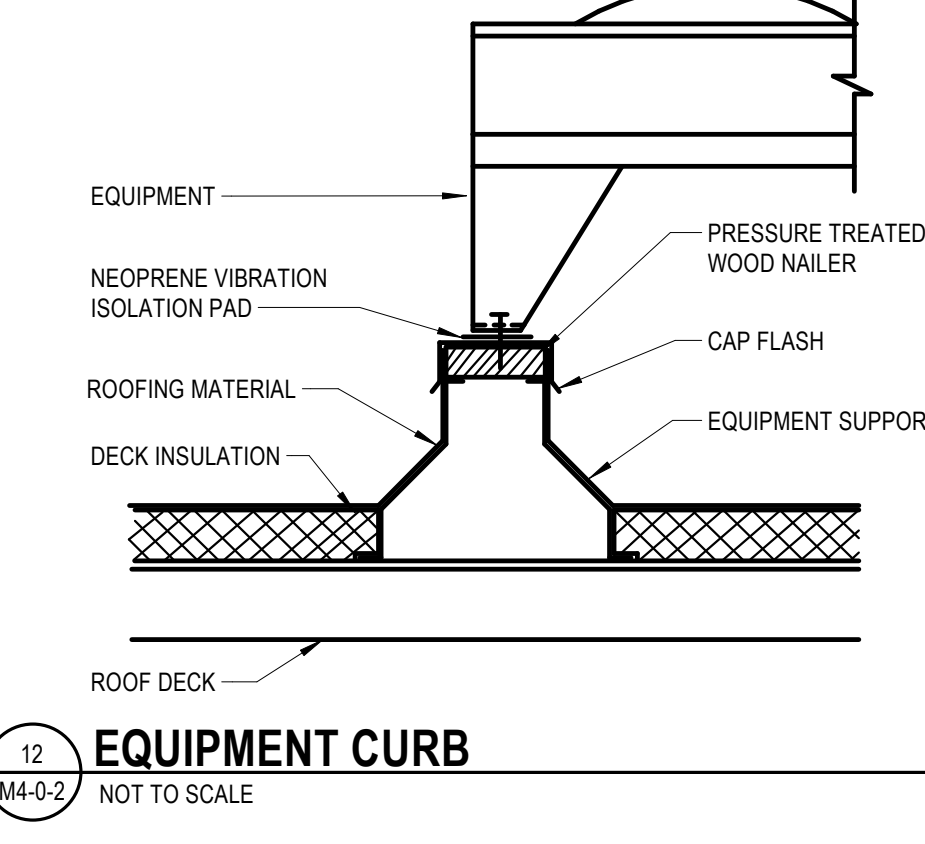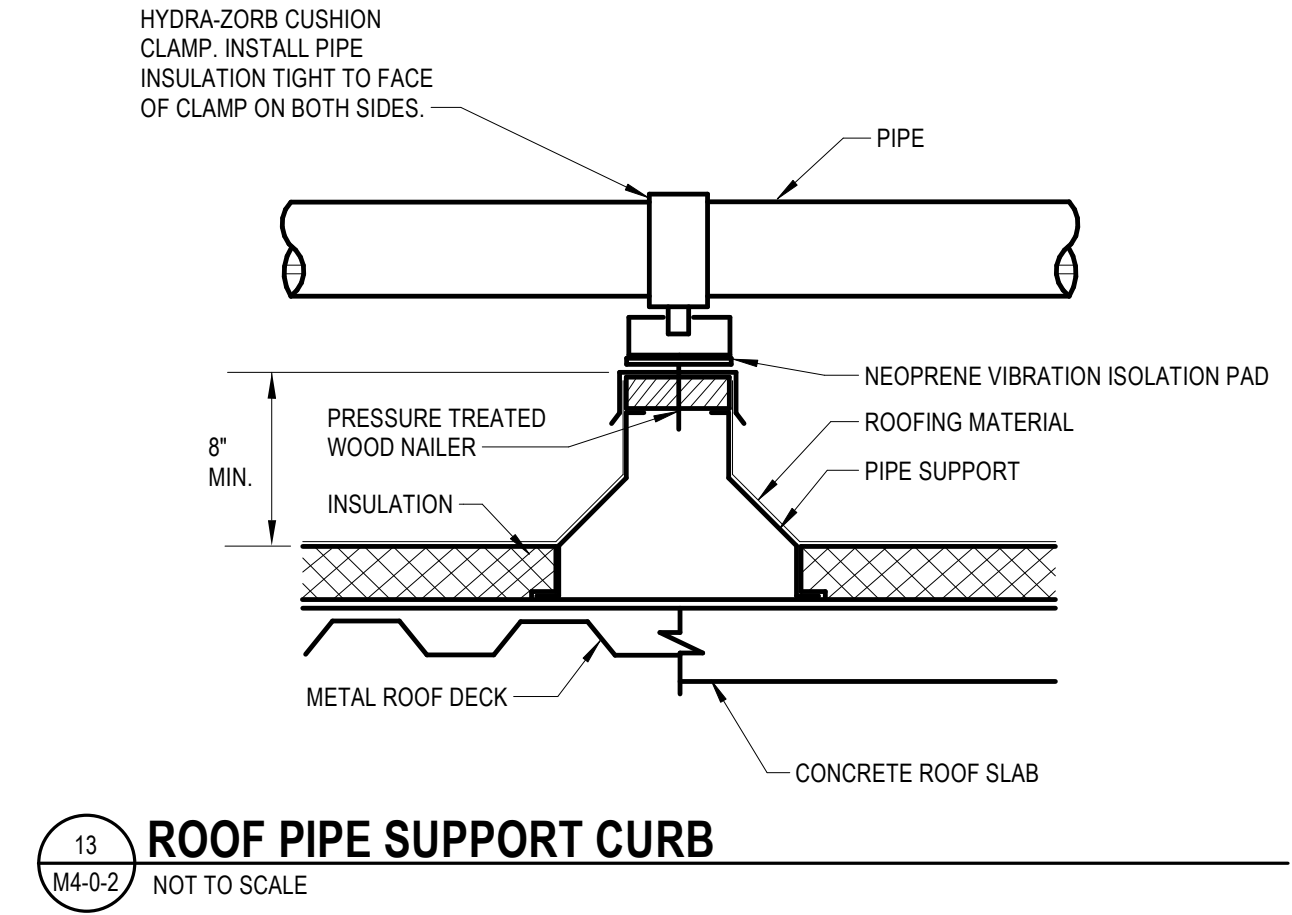

DRA

Drumme Rosane Anderson, Inc.
225 Oakland Road Studio 205 South Windsor, CT 06074
Tel: 617.984.1700 www.dra.com

280 Charles Street Studio 300 Waltham, MA 02453
Tel: 617.984.1700 www.dra.com

Planning | Architecture | Interior Design

Northeast Metropolitan Regional Vocational High School

Wakefield, MA 01880

PROJECT NORTH

MAGNETIC NORTH

MECHANICAL DETAILS SHEET #2

Scale: As indicated
Job No.: 20202
Drawn By: DRA
Date: January 13, 2023

M4-0-2

DRAWING

Drummeys Rosane Anderson, Inc.

225 Oakland Road
Studio 205
South Windsor, CT
06074

260 Charles Street
Studio 300
Waltham, MA
02453

Planning | Architecture | Interior Design

Tel: 617.984.1702
www.dra.com

Northeast Metropolitan Regional Vocational High School

Wakefield, MA 01880

ENERGY RECOVERY VENTILATOR - ELECTRIC HEATING COIL (ERV)												
UNIT NO	SERVICE	LOCATION	AIR FLOWS (CFM)		ELECTRICAL CHARACTERISTICS				MANUFACTURER	MODEL	REMARKS	STARTER TYPE
			O.A.	EXH	V	PH	MCA	MOP				
ERV-1	ADMIN AREA 1A	A120 WAITING	695	350	208	1	54.7	60	OXYGEN8	A16N	PROVIDE 1 KW ELEC COIL	PS
ERV-2	DEPARTMENT HEADS	ROOF AREA B	285	285	208	1	2.7	15	SALDA	SMARTY 4X-P-FZ-1.1	PROVIDE 2 KW POST HEATER @ 208V/1PH - MOP=15	PS
ERV-3	EARLY CHILDHOOD	EARLY CHILDHOOD	1100	1005	480	3	21.2	25	OXYGEN8	H15	PROVIDE 1.3 KW ELEC COIL	PS
ERV-4	MEDIA CENTER	ROOF AREA A	1795	1795	480	3	28.1	30	OXYGEN8	C220U	PROVIDE 3.3 KW COIL	PS
ERV-5	CONCESSIONS BUILDING	CONCESSIONS BUILDING	1545	1550	480	3	24.5	25	OXYGEN8	H15	PROVIDE 1.4 KW ELEC COIL	PS
ERV-6	LOCKER BUILDING	LOCKER BUILDING	1590	1490	480	3	24.4	25	OXYGEN8	H15	PROVIDE 1.9 KW ELEC COIL	PS
ERV-7	ADMIN AREA 4A	A403 CORRIDOR	250	195	208	1	2.7	15	SALDA	SMARTY 4X-P-FZ-1.1	PROVIDE 2 KW POST HEATER @ 208V/1PH - MOP=15	PS

- NOTES:
1. REFER TO SPECIFICATIONS SECTION 23000 FOR ALTERNATE MANUFACTURERS FOR PRODUCTS/SYSTEMS LISTED UNDER THIS SCHEDULE.
 2. PROVIDE 2 INCH MERV-13 FILTER FOR OUTDOOR AIR.
 3. PROVIDE 2 INCH MERV-8 EXHAUST FILTER.
 4. MAXIMUM FILTER VELOCITY TO BE 40 FPM.
 5. PROVIDE SINGLE POINT POWER CONNECTION FOR OXYGEN8 UNITS.
 6. PROVIDE FROST CONTROL.

DEDICATED OUTDOOR AIR ROOFTOP UNITS - DXCOOLING/HEATING WITH ELECTRIC PRE-HEAT (HRU)														
UNIT NO	LOCATION	SERVICE	OUTDOOR AIRFLOW (CFM)	MAX AIRFLOW (CFM)	TSP (IN.WG)	CONTROL	SUPPLY FAN MAX AIRFLOW (CFM)	TSP (IN.WG)	RETURN FAN MAX AIRFLOW (CFM)	TSP (IN.WG)	COOLING COIL TOTAL CAP (MBH)	KW	V	PH
HRU1-1	ROOF AREA A	CLASSROOMS	16000	16000	5.50	VFD	15000	822.0	80	480	3	156.8	169.1	175
HRU1-2	ROOF AREA A	CLASSROOMS	16000	16000	5.50	VFD	15000	822.0	80	480	3	156.8	169.1	175
HRU1-3	ROOF AREA B	CLASSROOMS	16000	16000	5.50	VFD	15000	822.0	80	480	3	156.8	169.1	175
HRU1-4	ROOF AREA D	LOCKERSHOWER	7070	7070	5.00	VFD	7070	409.0	25	480	3	61.2	76.5	80
HRU1-5	ROOF AREA B	COSMETOLOGY	2760	2760	4.80	VFD	2760	115.0	10	480	3	28.8	36.0	40

- NOTES:
1. REFER TO SPECIFICATIONS SECTION 23000 FOR ALTERNATE MANUFACTURERS FOR PRODUCTS/SYSTEMS LISTED UNDER THIS SCHEDULE.
 2. REFER TO ENERGY RECOVERY WHEEL SCHEDULE.
 3. THE BREAK HORSEPOWER LISTED HERE IS THE MAXIMUM ALLOWABLE WHICH SHALL INCLUDE ALL UNIT SPECIFIC SYSTEM EFFECTS AND COMPONENT PRESSURE DROPS.
 4. PROVIDE MERV-8 PRE-FILTER AND MERV-15 FINAL FILTER FOR SUPPLY AIR FLOW. PROVIDE MERV-8 FILTERS FOR THE RETURN/EXHAUST AIRFLOW UPSTREAM OF TOTAL ENERGY WHEEL.
 5. ALLOW FOR 1" W.C. FILTER LOADING ON THE SUPPLY AND 0.5" W.C. FILTER LOADING ON THE EXHAUST AIR STREAMS.
 6. PROVIDE 22-INCH HIGH FULL PERIMETER SPRING ROOF CURB WITH 2-INCH DEFLECTION - TYPE PC-4025
 7. PROVIDE DIRECT DRIVE PLUMIN FANS WITH AIRFOIL SHAPED BLADES.
 8. PROVIDE REFRIGERANT PIPING BETWEEN HRU AND VCU CONDENSING UNIT.

MAKE-UP AIR UNIT - DX COOLING/HEATING WITH ELECTRIC PRE-HEAT (MAU)														
UNIT NO	LOCATION	SERVICE	OUTDOOR AIRFLOW (CFM)	MAX AIRFLOW (CFM)	TSP (IN.WG)	CONTROL	SUPPLY FAN MAX AIRFLOW (CFM)	TSP (IN.WG)	RETURN FAN MAX AIRFLOW (CFM)	TSP (IN.WG)	COOLING COIL TOTAL CAP (MBH)	KW	V	PH
MAU-1	MECHANICAL 201	KITCHEN	6510	6510	2.10	VFD	392.0	95	460	3	136	139.5	150	166.00
MAU-2	ROOF AREA A	CULINARY KITCHEN	15605	15605	2.00	VFD	1057.0	225	460	3	327	338.4	400	16163.00

- NOTES:
1. REFER TO SPECIFICATIONS SECTION 23000 FOR ALTERNATE MANUFACTURERS FOR PRODUCTS/SYSTEMS LISTED UNDER THIS SCHEDULE.
 2. REFER TO ENERGY RECOVERY WHEEL SCHEDULE.
 3. THE BREAK HORSEPOWER LISTED HERE IS THE MAXIMUM ALLOWABLE WHICH SHALL INCLUDE ALL UNIT SPECIFIC SYSTEM EFFECTS AND COMPONENT PRESSURE DROPS.
 4. PROVIDE MERV-8 PRE-FILTER AND MERV-15 FINAL FILTER FOR SUPPLY AIR FLOW. PROVIDE MERV-8 FILTERS FOR THE RETURN/EXHAUST AIRFLOW UPSTREAM OF TOTAL ENERGY WHEEL.
 5. ALLOW FOR 1" W.C. FILTER LOADING ON THE SUPPLY AND 0.5" W.C. FILTER LOADING ON THE EXHAUST AIR STREAMS.
 6. PROVIDE 22-INCH SPRING ROOF CURB.
 7. PROVIDE DIRECT DRIVE PLUMIN FANS WITH AIRFOIL SHAPED BLADES.
 8. PROVIDE REFRIGERANT PIPING BETWEEN MAU AND VCU CONDENSING UNIT.

ROOFTOP AIR HANDLING UNIT - DX COOLING/HEATING WITH ELECTRIC PRE-HEAT (RTU)														
UNIT NO	LOCATION	SERVICE	MIN	MAX AIRFLOW (CFM)	TSP (IN.WG)	CONTROL	SUPPLY FAN MAX AIRFLOW (CFM)	TSP (IN.WG)	RETURN FAN MAX AIRFLOW (CFM)	TSP (IN.WG)	COOLING COIL TOTAL CAP (MBH)	KW	V	PH
RTU-1	ROOF AREA A	CULINARY	680	1165	3.40	VFD	1165	3.40	VFD	1165	3.40	460	3	136
RTU-2	ROOF AREA D	GYMNASIUM	4650	14000	5.40	VFD	14000	3.20	VFD	14000	3.20	460	3	327

- NOTES:
1. REFER TO SPECIFICATIONS SECTION 23000 FOR ALTERNATE MANUFACTURERS FOR PRODUCTS/SYSTEMS LISTED UNDER THIS SCHEDULE.
 2. REFER TO ENERGY RECOVERY WHEEL SCHEDULE.
 3. PROVIDE 2 INCH MERV-13 FILTER FOR OUTDOOR AIR.
 4. PROVIDE OUTSIDE AIR INTAKE HOOD.
 5. PROVIDE 2 INCH MERV-8 EXHAUST FILTER.
 6. MAXIMUM FILTER VELOCITY TO BE 40 FPM.
 7. PROVIDE SINGLE POINT POWER CONNECTION.
 8. PROVIDE CONVENIENCE OUTLET POWERED BY DEDICATED 120V/1PH/20AMP FEED (BY DIV. 26)
 9. PROVIDE FROST CONTROL.
 10. PROVIDE REFRIGERANT PIPING BETWEEN RTU AND VCU CONDENSING UNIT.

INDOOR AIR HANDLING UNIT - DX COOLING/HEATING WITH ELECTRIC PRE-HEAT (AHU)																					
UNIT NO.	LOCATION	SERVICE	MIN	SUPPLY FAN			RETURN FAN			COOLING COIL	ELECTRIC PRE-HEAT		ELECTRICAL	REMARKS							
				MAX AIRFLOW (CFM)	TSP (IN.WG)	CONTROL	MAX AIRFLOW (CFM)	ESP (IN.WG)	CONTROL		TOTAL CAP (MBH)	KW			V	PH	FLA	MCA	OPD	WEIGHT	
AHU-1	METAL FABRICATION MEZZANINE	METAL FABRICATION	2880	2000	2.55	VFD	17000	2.10	VFD	NONE	755.1	285.0	400	3	412	425.2	400	16663.00	YORK	YC-754155	SEE NOTES
AHU-2	METAL FABRICATION MEZZANINE	METAL FABRICATION	2880	2000	2.55	VFD	17000	2.10	VFD	NONE	755.1	285.0	400	3	412	425.2	400	16663.00	YORK	YC-754155	SEE NOTES
AHU-3	AUTO TECHNOLOGY MEZZANINE	AUTO TECHNOLOGY	6885	15475	3.40	VFD	15745	1.90	VFD	NONE	596.0	225.0	400	3	328	338.0	400	13230.00	YORK	YC-754105	SEE NOTES
AHU-4	ELECTRICAL TECHNOLOGY MEZZANINE	ELECTRICAL TECHNOLOGY	1985	3450	3.32	VFD	6885	2.00	VFD	NONE	230.6	135.0	400	3	193	205.5	225	10603.00	YORK	YC-65454	SEE NOTES
AHU-5	HVAC TECHNOLOGY MEZZANINE	HVAC TECHNOLOGY	3360	7275	3.34	VFD	7275	2.11	VFD	NONE	272.0	103.0	400	3	157	163.8	175	8219.00	YORK	YC-55475	SEE NOTES
AHU-6	PLUMBING & PIPEFITTING MEZZANINE	PLUMBING & PIPEFITTING	2115	6570	3.80	VFD	6580	2.00	VFD	NONE	232.3	95.0	400	3	1943	147.8	150	7903.00	YORK	YC-61575	SEE NOTES
AHU-7	CARPENTRY MEZZANINE	CARPENTRY	2400	6265	2.36	VFD	6335	2.10	VFD	NONE	300.6	120.0	400	3	179	186.5	200	9115.00	YORK	YC-61544	SEE NOTES
AHU-8	MECHANICAL 201	CAFETERIA	7100	10255	3.90	VFD	10260	2.80	VFD	ALUMINUM W/MLL/CULAR SIEVE A4	466.6	35.0	400	3	185	196.0	110	16275.00	HERMETIC	YC-65411	SEE NOTES
AHU-9	MECHANICAL 639	EVENTS ENTRY	2595	3555	4.10	VFD	2595	4.00	VFD	ALUMINUM W/MLL/CULAR SIEVE A4	363.9	30.0	400	3	78	97.10	100	14986.00	THERMOTEC	YC-654102	SEE NOTES
AHU-10	MECHANICAL 639	AUDITORIUM	965	9485	4.00	VFD	9485	3.20	VFD	ALUMINUM W/MLL/CULAR SIEVE A4	479.0	35.0	400	3	85	106.4	110	15229.00	THERMOTEC	YC-654102	SEE NOTES

- NOTES:
1. REFER TO SPECIFICATIONS SECTION 23000 FOR ALTERNATE MANUFACTURERS FOR PRODUCTS/SYSTEMS LISTED UNDER THIS SCHEDULE.
 2. MAXIMUM FAN POWER INCLUDES DRIVE LOSSES AND ANY SYSTEM EFFECTS INTERNAL TO ROOFTOP UNIT.
 3. THE BREAK HORSEPOWER LISTED HERE IS THE MAXIMUM ALLOWABLE WHICH SHALL INCLUDE ALL UNIT SPECIFIC SYSTEM EFFECTS.
 4. PROVIDE DIRECT DRIVE PLUMIN FANS WITH AIRFOIL SHAPED BLADES.
 5. PROVIDE MERV-8 PRE-FILTER AND MERV-15 FINAL FILTER.
 6. SUPPLY FAN IS ADJUSTED TO ALLOW FOR A TOTAL AIR SYSTEM LEAKAGE OF 3%.
 7. DIRTY FILTER ALLOWANCE SHALL BE 0.5 W.G.
 8. PROVIDE 6-INCH BASE RAIL.
 9. PROVIDE ECONOMIZER SECTION.
 10. PROVIDE SINGLE POINT POWER CONNECTION WITH CONVENIENCE OUTLET FED FROM DEDICATED 120V/1PH/20 AMP LINE FROM DIV. 26.
 11. UNIT SHALL BE INDOOR TYPE.
 12. PROVIDE WITH UNIT DISCONNECT SWITCH.
 13. SUPPLY AIR FAN SHALL BE PLUMIN TYPE.
 14. RETURN AIR FAN SHALL BE PLUMIN TYPE.
 15. RETURN AIR FAN SHALL BE PLUMIN TYPE. INNER FACE OF CASING SHALL BE PERFORATED WITH MYLAR OR TEGULAR LINING.
 16. PROVIDE COP MOTORS FOR FANS.
 17. PROVIDE WITH VFD COMPATIBLE MOTORS.
 18. PROVIDE ELECTRICALLY INSULATED BEARINGS ON VFD DRIVEN MOTORS. PROVIDE SHAFT MOUNTED STATIC DISCHARGE DISAPPEARANCE RING WITH CONDUCTIVE MICROFIBERS ELECTRO-STATIC TECHNOLOGY AEGIS SGR OR APPROVED EQUAL.
 19. THE BREAKHORSEPOWER LISTED IS THE MAXIMUM ALLOWABLE WHICH SHALL INCLUDE ALL DRIVE LOSSES AND UNIT SPECIFIC FAN SYSTEM EFFECTS.
 20. PROVIDE WITH OUTDOOR AIRFLOW MEASURING STATION.
 21. PROVIDE 2" SPRING ISOLATORS.
 22. PROVIDE WITH ENERGY RECOVERY SECTION. REFER TO ENERGY RECOVERY SCHEDULE FOR PERFORMANCE REQUIREMENTS.

FAN SCHEDULE (F)										
UNIT NO.	LOCATION	SERVICE	AIRFLOW (CFM)	SIZE HP	V	PH	MANUFACTURER	MODEL	NOTES	
F-1	ROOF AREA A	KITCHEN DISHWASHER	600	12	120	1	GREENHECK	CUE-100HP-VG		
F-2	ROOF AREA A	CULINARY OVEN	900	34	208	1	GREENHECK	CUE-140HP-VG		
F-3	AUTO TECH	VEHICLE EXHAUST	2800	5	460	3	CARMON	CMB-20		
F-7	AUTO TECH	VEHICLE EXHAUST	2100	3	460	3	CARMON	CMB-20		
F-8	ROOF AREA A	CULINARY DISHWASHER	600	12	120	1	GREENHECK	CUE-100HP-VG		
F-9	MECHANICAL 201	MECHANICAL 201	300	34	208	1	GREENHECK	SQ-36-VG		
F-11	ROOF AREA B	B201 LASER CUTTER	360	-	208	1	CINCINNATI FAN	REB-9		
F-12	ROOF AREA B	B201 LASER CUTTER	360	-	208	1	CINCINNATI FAN	REB-9		
F-13	ROOF AREA C	METAL FAB. WELDING BOOTHS	18400	20	460	3	GREENHECK	QE-30	VFD	
F-15	ROOF AREA C	AUTO COLL. SPRAY BOOTH	15000	15	460	3	GREENHECK	QE-30		
F-16	ROOF AREA C	AUTO COLL. SPRAY BOOTH	15000	15	460	3	GREENHECK	QE-33		
F-17	ROOF AREA C	AUTO COLL. MIXING BOOTH	900	0.75	208	1	GREENHECK	CUE-140HP-VG		
F-18	DRY STORAGE 383	DRY STORAGE 383	415	34	120	3	GREENHECK	SQ-36-VG		
F-19	MAINT. GARAGE	MAINT. GARAGE M101	1700	34	208	1	GREENHECK	SQ-36-VG		
F-20	ROOF AREA C	AUDITORIUM TOILETS	400	1.25	208	1	GREENHECK	CUE-100HP-VG		
F-21	FIELD MAINT. GARAGE	FIELD MAINT. GARAGE	1100	34	208	1	GREENHECK	SQ-36-VG		
KEF-1	ROOF AREA A	HOOD A37	2800	1-1/2	460	3	GREENHECK	USGF-180HP	VFD	
KEF-2	ROOF AREA A	HOOD A38	3300	2	460	3	GREENHECK	USGF-180HP	VFD	
KEF-3	ROOF AREA A	HOOD D12	1850	1	460	3	GREENHECK	USGF-180HP	VFD	
KEF-4	ROOF AREA A	HOOD E4	2365	1-1/2	460	3	GREENHECK	USGF-180HP	VFD	
KEF-5	ROOF AREA A	HOODS F13, 14, 16, & 17	8390	5	460	3	GREENHECK	CUE-360HP	VFD	

- NOTES:
1. REFER TO SPECIFICATIONS SECTION 23000 FOR ALTERNATE MANUFACTURERS FOR PRODUCTS/SYSTEMS LISTED UNDER THIS SCHEDULE.
 2. PROVIDE EC MOTOR.
 3. PROVIDE 18-INCH PRE-FABRICATED ROOF CURB FOR ROOF MOUNTED FANS.
 4. ALL SUSPENDED FANS SHALL BE MOUNTED ON TYPE HSN VIBRATION ISOLATORS WITH A 1.5" MINIMUM STATIC DEFLECTION.
 5. PROVIDE FAN COMPLETE WITH UL782 RATING AND RINGED ROOF CURB FOR ROOF MOUNTED UPRAST KITCHEN HOOD EXHAUST FANS.
 6. PROVIDE REMOTE MOUNT LOW VOLTAGE DISCONNECT PANEL CAPABLE OF DISPLAYING NORMAL OPERATION, NO POWER, BLOCKED DUCT, LOCKED MOTOR ROTOR AND LOW SPEED CONDITIONS.
 7. 10% DELT LOSS INCLUDED ON BELT DRIVE FANS.
 8. PROVIDE VFD FOR INTERLOCKING WITH KITCHEN HOOD CONTROL MODULE.
 9. PROVIDE WITH DISCONNECT SWITCH.
 10. PROVIDE VFD COMPATIBLE MOTORS FOR NON EC MOTORS.
 11. PROVIDE ELECTRICALLY INSULATED BEARINGS ON VFD DRIVEN MOTORS. PROVIDE SHAFT MOUNTED STATIC DISCHARGE DISAPPEARANCE RING WITH CONDUCTIVE MICROFIBERS ELECTRO-STATIC TECHNOLOGY AEGIS SGR OR APPROVED EQUAL.
 12. THE BREAKHORSEPOWER LISTED IS THE MAXIMUM ALLOWABLE WHICH SHALL INCLUDE ALL DRIVE LOSSES AND UNIT SPECIFIC FAN SYSTEM EFFECTS.
 13. PROVIDE WITH INTEGRAL CONTROL (AMPER WITH END SWITCH).
 14. INTERLOCK FANS SERVING EQUIPMENT WITH EQUIPMENT CONTROLS.

AIR CONDITIONING UNITS - DX SPLIT SYSTEMS (AC)														
UNIT NO	AREA SERVED	TYPE	ELECTRICAL CHARACTERISTICS		DX REFRIGERANT COOLING CAPACITY (MBH)		SOUND LEVEL (DBA)	MANUFACTURER	MODEL	NOTES	STARTER TYPE			
			V	PH	V	PH								
AC-01	MAIN ELECTRICAL - C081	WALL MOUNTED	208	1	36.0	51	LG	LSN243LV3						
AC-02	MAIN ELECTRICAL STANDBY - C085	WALL MOUNTED	208	1	24.0	49	LG	LSN243LV3						
AC-03	LIFE SAFETY ELECTRICAL - C080	WALL MOUNTED	208	1	24.0	49	LG	LSN243LV3						
AC-04	GENERATOR PANELS - C007	WALL MOUNTED	208	1	24.0	49	LG	LSN243LV3						
AC-05	IDF - C099	WALL MOUNTED	208	1	24.0	49	LG	LSN243LV3						
AC-06	PLUMBING C008	WALL MOUNTED	208	1	36.0	51	LG	LSN243LV3						
AC-07	ELEV MACHINE RM - C012	WALL MOUNTED	208	1	36.0	51	LG	LSN243LV3						
AC-08	MAIN KITCHEN ELECTRICAL - 192	WALL MOUNTED	208	1	24.0	49	LG	LSN243LV3						
AC-11	IDF - 588	WALL MOUNTED	208	1	24.0	49	LG	LSN243LV3						
AC-12	PLUMBING - COMPRESSED AIR - 212	WALL MOUNTED	208	1	36.0	51	LG	LSN243LV3						
AC-13	VOC ELECTRICAL - 194	WALL MOUNTED	208	1	24.0	49	LG	LSN243LV3						
AC-14	IDF - 217	WALL MOUNTED	208	1	24.0	49	LG	LSN243LV3						
AC-15	ELECTRIC RM - 124	WALL MOUNTED	0	1	0.0	0	x		xx					
AC-16	LIFE SAFETY ELECTRICAL - 121	WALL MOUNTED	208	1	24.0	49	LG	LSN243LV3						
AC-17	IDF - 118	WALL MOUNTED	208	1	24.0	49	LG	LSN243LV3						
AC-21	ELECTRIC RM - 370	WALL MOUNTED	208	1	24.0	49	LG	LSN243LV3						
AC-22	LIFE SAFETY ELECTRICAL - 371	WALL MOUNTED	208	1	24.0	49	LG	LSN243LV3						
AC-23	IDF - 372	WALL MOUNTED	208	1	24.0	49	LG	LSN243LV3						
AC-24	ELEV MACHINE RM - 718	WALL MOUNTED	208	1	36.0	51	LG	LSN243LV3						
AC-25	IDF - 185	WALL MOUNTED	208	1	24.0	49	LG	LSN243LV3						
AC-26	IDF - 186	WALL MOUNTED	208	1	24.0	49	LG	LSN243LV3						
AC-27	TELECOM - 142	WALL MOUNTED	208	1	24.0	49	LG	LSN243LV3						
AC-28	ELECTRIC RM - 200	WALL MOUNTED	208	1	24.0	49	LG	LSN243LV3						
AC-29	ELECTRIC RM - 203	WALL MOUNTED	208	1	24.0	49	LG	LSN243LV3						
AC-210	ELECTRIC RM - 203	WALL MOUNTED	208	1	24.0	49	LG	LSN243LV3						
AC-31	IDF - 221	WALL MOUNTED	208	1	24.0	49	LG	LSN243LV3						
AC-32	LIFE SAFETY ELECTRICAL - 236	WALL MOUNTED	208	1	24.0	49	LG	LSN243LV3						
AC-33	ELECTRIC RM - 199	WALL MOUNTED	208	1	24.0	49	LG	LSN243LV3						
AC-34	IDF - 223	WALL MOUNTED	208	1	24.0	49	LG	LSN243LV3						
AC-35	ELECTRIC RM - 186	WALL MOUNTED	208	1	24.0	49	LG	LSN243LV3						
AC-36	LIFE SAFETY ELECTRICAL - 237	WALL MOUNTED	208	1	24.0	49	LG	LSN243LV3						
AC-41	IDF - 215	WALL MOUNTED	208	1	24.0	49	LG	LSN243LV3						
AC-42	LIFE SAFETY ELECTRICAL - 201	WALL MOUNTED	208	1	24.0	49	LG	LSN243LV3						
AC-43	ELECTRIC RM - 195	WALL MOUNTED	208	1	24.0	49	LG	LSN243LV3						
AC-44	LIFE SAFETY ELECTRICAL - 202	WALL MOUNTED	208	1	24.0	49	LG	LSN243LV3						
AC-45	ELECTRIC RM - 186	WALL MOUNTED	208	1	24.0	49	LG	LSN243LV3						
AC-46	AMPLIFIER ELECT RM - 207	WALL MOUNTED	208	1	24.0	49	LG	LSN243LV3						
AC-47	IDF - 384	WALL MOUNTED	208	1	24.0	49	LG	LSN243LV3						
AC-H01	HVAC TECH B103 - STUDENT TRAINER	WALL MOUNTED	208	1	18.0	47	LG	LSM181HSVS						
AC-H02	HVAC TECH B103 - STUDENT TRAINER	WALL MOUNTED	208	1	18.0	47	LG	LSM181HSVS						
AC-H03	HVAC TECH B103 - STUDENT TRAINER	WALL MOUNTED	208	1	18.0	47	LG	LSM181HSVS						
AC-H04	HVAC TECH B103 - STUDENT TRAINER	WALL MOUNTED	208	1	18.0	47	LG	LSM181HSVS						
AC-H04.2	HVAC TECH B103 - STUDENT TRAINER	WALL MOUNTED	208	1	18.0	47	LG	LSM181HSVS						
AC-H04.3	HVAC TECH B103 - STUDENT TRAINER	20 CEILING CASSETTE	208	1	18.0	47	LG	ARN181STN4						
AC-H04.4	HVAC TECH B103 - STUDENT TRAINER	DUCTED	208	1	18.0	0	LG	ARN181STN4						
AC-H05	HVAC TECH B103 - STUDENT TRAINER	DUCTED	208	1	48.0	0	TRANE	TAM040C4V410A						
AC-H05	HVAC TECH B103 - STUDENT TRAINER	DUCTED	208	1	48.0	0	TRANE	TAM040C4V410A						
AC-H06	HVAC TECH B103 - STUDENT TRAINER	DUCTED	208	1	48.0	0	TRANE	TAM040C4V410A						

VRF BRANCH CIRCUIT SELECTOR SCHEDULE (BS)						
UNIT NO	V	PH	ELEC DATA	RATED AMPS	MANUFACTURER	MODEL
BS-1.1	208	1	0.06	LG	PRHR03SA	SEE NOTES
BS-1.2	208	1	0.09	LG	PRHR03SA	SEE NOTES
BS-2.1	208	1	0.09	LG	PRHR03SA	SEE NOTES
BS-2.2	208	1	0.09	LG	PRHR03SA	SEE NOTES
BS-2.3	208	1	0.09	LG	PRHR03SA	SEE NOTES
BS-2.4	208	1	0.09	LG	PRHR03SA	SEE NOTES
BS-3.1	208	1	0.06	LG	PRHR03SA	SEE NOTES
BS-3.2	208	1	0.06	LG	PRHR03SA	SEE NOTES
BS-4.1	208	1	0.09	LG	PRHR03SA	SEE NOTES
BS-4.2	208	1	0.06	LG	PRHR03SA	SEE NOTES
BS-4.3	208	1	0.09	LG	PRHR03SA	SEE NOTES
BS-4.4	208	1	0.09	LG	PRHR03SA	SEE NOTES
BS-5.1	208	1	0.09	LG	PRHR03SA	SEE NOTES
BS-5.2	208	1	0.09	LG	PRHR03SA	SEE NOTES
BS-5.3	208	1	0.06	LG	PRHR03SA	SEE NOTES
BS-6.1	208	1	0.09	LG	PRHR03SA	SEE NOTES
BS-6.2	208	1	0.09	LG	PRHR03SA	SEE NOTES
BS-6.3	208	1	0.09	LG	PRHR03SA	SEE NOTES
BS-7.1	208	1	0.09	LG	PRHR03SA	SEE NOTES
BS-8.1	208	1	0.09	LG	PRHR03SA	SEE NOTES
BS-8.2	208	1	0.09	LG	PRHR03SA	SEE NOTES
BS-8.3	208	1	0.06	LG	PRHR03SA	SEE NOTES
BS-8.4	208	1	0.09	LG	PRHR03SA	SEE NOTES
BS-9.1	208	1	0.09	LG	PRHR03SA	SEE NOTES
BS-9.2	208	1	0.09	LG	PRHR03SA	SEE NOTES
BS-9.3	208	1	0.09	LG	PRHR03SA	SEE NOTES
BS-10.1	208	1	0.09	LG	PRHR03SA	SEE NOTES
BS-10.2	208	1	0.06	LG	PRHR03SA	SEE NOTES
BS-10.3	208	1	0.09	LG	PRHR03SA	SEE NOTES
BS-10.4	208	1	0.09	LG	PRHR03SA	SEE NOTES
BS-11.1	208	1	0.09	LG	PRHR03SA	SEE NOTES
BS-11.2	208	1	0.09	LG	PRHR03SA	SEE NOTES
BS-11.3	208	1	0.09	LG	PRHR03SA	SEE NOTES
BS-12.1	208	1	0.09	LG	PRHR03SA	SEE NOTES
BS-13.1	208	1	0.09	LG	PRHR03SA	SEE NOTES
BS-13.2	208	1	0.09	LG	PRHR03SA	SEE NOTES
BS-13.3	208	1	0.06	LG	PRHR03SA	SEE NOTES
BS-14.1	208	1	0.09	LG	PRHR03SA	SEE NOTES
BS-14.2	208	1	0.09	LG	PRHR03SA	SEE NOTES
BS-14.3	208	1	0.09	LG	PRHR03SA	SEE NOTES
BS-15.1	208	1	0.09	LG	PRHR03SA	SEE NOTES
BS-15.2	208	1	0.09	LG	PRHR03SA	SEE NOTES
BS-16.1	208	1	0.09	LG	PRHR03SA	SEE NOTES
BS-16.2	208	1	0.06	LG	PRHR03SA	SEE NOTES
BS-16.3	208	1	0.09	LG	PRHR03SA	SEE NOTES
BS-16.4	208	1	0.09	LG	PRHR03SA	SEE NOTES

VRF FAN COIL UNIT (FCU)											
UNIT NO	TYPE	LOCATION	VRF CONDENSING UNIT	NOMINAL (TONS)	V	PH	MOCP	MAX SOUND RATING (DBA) HML	MANUFACTURER	MODEL	NOTES
FCU-1.1	3/3 CEILING CASSETTE	METAL LAB CR	CU-1	2.5	208	1	0	0	LG	ARNK0357R04	
FCU-1.2	2/2 CEILING CASSETTE	CURT OFF	CU-1	0.5	208	1	0	0	LG	ARNK0357R04	
FCU-1.3	2/2 CEILING CASSETTE	CUST WORKSHOP	CU-1	0.8	208	1	0	0	LG	ARNK0357R04	
FCU-1.4	3/3 CEILING CASSETTE	TEAM LOCKER	CU-1	1.5	208	1	0	0	LG	ARNK0357R04	
FCU-1.5	3/3 CEILING CASSETTE	AUTO COLL CR	CU-1	1.5	208	1	0	0	LG	ARNK0357R04	
FCU-1.6	3/3 CEILING CASSETTE	AUTO TECH CR	CU-1	3.0	208	1	0	0	LG	ARNK0357R04	
FCU-1.7	3/3 CEILING CASSETTE	WALL MOUNTED	CU-1	1.5	208	1	0	0	LG	ARNK0357R04	
FCU-1.8	3/3 CEILING CASSETTE	STAR 56	CU-1	1.5	208	1	0	0	LG	ARNK0357R04	
FCU-1.9	2/2 CEILING CASSETTE	CURT OFF	CU-1	0.5	208	1	0	0	LG	ARNK0357R04	
FCU-1.10	2/2 CEILING CASSETTE	CURT OFF	CU-1	0.5	208	1	0	0	LG	ARNK0357R04	
FCU-2.1	2/2 CEILING CASSETTE	NURSE WAIT 102	CU-2	0.6	208	1	0	0	LG	ARNK0357R04	
FCU-2.2	2/2 CEILING CASSETTE	NURSE OFFICE 103	CU-2	0.5	208	1	0	0	LG	ARNK0357R04	
FCU-2.3	2/2 CEILING CASSETTE	NURSE OFFICE 104	CU-2	0.5	208	1	0	0	LG	ARNK0357R04	
FCU-2.4	2/2 CEILING CASSETTE	EXAM 105	CU-2	0.5	208	1	0	0	LG	ARNK0357R04	
FCU-2.5	2/2 CEILING CASSETTE	EXAM 109	CU-2	0.5	208	1	0	0	LG	ARNK0357R04	
FCU-2.6	2/2 CEILING CASSETTE	EXAM 110	CU-2	0.5	208	1	0	0	LG	ARNK0357R04	
FCU-2.7	2/2 CEILING CASSETTE	RESTING 105	CU-2	0.6	208	1	0	0	LG	ARNK0357R04	
FCU-2.8	3/3 CEILING CASSETTE	HEALTH CR 111	CU-2	2.0	208	1	0	0	LG	ARNK0357R04	
FCU-2.9	3/3 CEILING CASSETTE	FITNESS 113	CU-2	2.0	208	1	0	0	LG	ARNK0357R04	
FCU-2.10	3/3 CEILING CASSETTE	FITNESS 113	CU-2	4.0	208	1	0	0	LG	ARNK0357R04	
FCU-2.11	2/2 CEILING CASSETTE	OFFICIALS 123	CU-2	0.5	208	1	0	0	LG	ARNK0357R04	
FCU-2.12	2/2 CEILING CASSETTE	PE INSTR. OFF 117D	CU-2	0.5	208	1	0	0	LG	ARNK0357R04	
FCU-2.13	2/2 CEILING CASSETTE	TRAINER 119	CU-2	0.5	208	1	0	0	LG	ARNK0357R04	
FCU-2.14	2/2 CEILING CASSETTE	ATH. DIR. OFF 118	CU-2	0.5	208	1	0	0	LG	ARNK0357R04	
FCU-2.15	2/2 CEILING CASSETTE	PE INSTR. OFF 122D	CU-2	0.5	208	1	0	0	LG	ARNK0357R04	
FCU-2.16	3/3 CEILING CASSETTE	OFFICIALS 123	CU-2	0.5	208	1	0	0	LG	ARNK0357R04	
FCU-2.17	3/3 CEILING CASSETTE	GIRLS LOCKER 122	CU-2	2.0	208	1	0	0	LG	ARNK0357R04	
FCU-2.18	3/3 CEILING CASSETTE	GIRLS LOCKER 122	CU-2	2.0	208	1	0	0	LG	ARNK0357R04	
FCU-2.19	2/2 CEILING CASSETTE	TEAM LOCKER 122B	CU-2	0.6	208	1	0	0	LG	ARNK0357R04	
FCU-2.20	2/2 CEILING CASSETTE	TEAM LOCKER 122C	CU-2	0.6	208	1	0	0	LG	ARNK0357R04	
FCU-2.21	2/2 CEILING CASSETTE	TEAM LOCKER 117B	CU-2	0.6	208	1	0	0	LG	ARNK0357R04	
FCU-2.22	2/2 CEILING CASSETTE	TEAM LOCKER 117C	CU-2	0.6	208	1	0	0	LG	ARNK0357R04	
FCU-2.23	2/2 CEILING CASSETTE	BOYS LOCKER 117	CU-2	0.6	208	1	0	0	LG	ARNK0357R04	
FCU-2.24	2/2 CEILING CASSETTE	BOYS LOCKER 117	CU-2	0.6	208	1	0	0	LG	ARNK0357R04	
FCU-2.25	3/3 CEILING CASSETTE	WEIGHTS 115	CU-2	2.3	208	1	0	0	LG	ARNK0357R04	
FCU-3.1	3/3 CEILING CASSETTE	RELATED CR 518	CU-3	3.0	208	1	0	0	LG	ARNK0357R04	
FCU-3.2	2/2 CEILING CASSETTE	RELATED CR 518	CU-3	1.3	208	1	0	0	LG	ARNK0357R04	
FCU-3.3	3/3 CEILING CASSETTE	RELATED CR 504	CU-3	3.0	208	1	0	0	LG	ARNK0357R04	
FCU-3.4	2/2 CEILING CASSETTE	SCHOOL STORE 159	CU-3	0.8	208	1	0	0	LG	ARNK0357R04	
FCU-3.5	3/3 CEILING CASSETTE	RELATED CR 603	CU-3	3.0	208	1	0	0	LG	ARNK0357R04	
FCU-3.6	3/3 CEILING CASSETTE	RELATED CR 496	CU-3	3.0	208	1	0	0	LG	ARNK0357R04	
FCU-3.7	2/2 CEILING CASSETTE	CORRIDOR 377	CU-3	0.5	208	1	0	0	LG	ARNK0357R04	
FCU-4.1	3/3 CEILING CASSETTE	COMPUTER LAB 416	CU-4	3.5	208	1	0	0	LG	ARNK0357R04	
FCU-4.2	2/2 CEILING CASSETTE	PHOTO / STORAGE	CU-4	0.6	208	1	0	0	LG	ARNK0357R04	
FCU-4.3	3/3 CEILING CASSETTE	DESIGN & VISUAL COMM 0	CU-4	3.0	208	1	0	0	LG	ARNK0357R04	
FCU-4.3b	2/2 CEILING CASSETTE	DESIGN & VISUAL COMM 0	CU-4	0.5	208	1	0	0	LG	ARNK0357R04	
FCU-4.4	3/3 CEILING CASSETTE	STAR 1715	CU-4	1.5	208	1	0	0	LG	ARNK0357R04	
FCU-4.5	3/3 CEILING CASSETTE	COMPUTER LAB 417	CU-4	4.0	208	1	0	0	LG	ARNK0357R04	
FCU-4.6	2/2 CEILING CASSETTE	RELATED CR 418	CU-4	1.5	208	1	0	0	LG	ARNK0357R04	
FCU-4.7	3/3 CEILING CASSETTE	COMPUTER LAB 410	CU-4	3.5	208	1	0	0	LG	ARNK0357R04	
FCU-4.8	3/3 CEILING CASSETTE	RELATED CR 411	CU-4	2.0	208	1	0	0	LG	ARNK0357R04	
FCU-4.9	3/3 CEILING CASSETTE	CORRIDOR	CU-4	4.0	208	1	0	0	LG	ARNK0357R04	
FCU-4.10	3/3 CEILING CASSETTE	CORRIDOR	CU-4	4.0	208	1	0	0	LG	ARNK0357R04	
FCU-4.11	3/3 CEILING CASSETTE	LANGUAGE LEARNING 0	CU-4	2.0	208	1	0	0	LG	ARNK0357R04	
FCU-4.12	2/2 CEILING CASSETTE	SCIENCE LAB 29	CU-4	0.8	208	1	0	0	LG	ARNK0357R04	
FCU-4.13	3/3 CEILING CASSETTE	SCIENCE LAB 0	CU-4	3.0	208	1	0	0	LG	ARNK0357R04	
FCU-4.14	3/3 CEILING CASSETTE	CORRIDOR	CU-4	2.0	208	1	0	0	LG	ARNK0357R04	
FCU-4.15	2/2 CEILING CASSETTE	GUIDANCE OFFICE 138	CU-4	0.8	208	1	0	0	LG	ARNK0357R04	
FCU-4.16	2/2 CEILING CASSETTE	GUIDANCE OFFICE 139	CU-4	0.8	208	1	0	0	LG	ARNK0357R04	
FCU-4.17	2/2 CEILING CASSETTE	GUIDANCE OFFICE 140	CU-4	0.8	208	1	0	0	LG	ARNK0357R04	
FCU-4.18	2/2 CEILING CASSETTE	VOC DEAN 168	CU-4	0.8	208	1	0	0	LG	ARNK0357R04	
FCU-4.19	2/2 CEILING CASSETTE	SPED TUTORIAL 81	CU-4	1.5	208	1	0	0	LG	ARNK0357R04	
FCU-4.20	2/2 CEILING CASSETTE	OFFICE 413	CU-4	0.5	208	1	0	0	LG	ARNK0357R04	
FCU-4.21	3/3 CEILING CASSETTE	CORRIDOR	CU-4	2.0	208	1	0	0	LG	ARNK0357R04	
FCU-5.1	3/3 CEILING CASSETTE	CR 0	CU-5	3.0	208	1	0	0	LG	ARNK0357R04	
FCU-5.2	3/3 CEILING CASSETTE	CR 0	CU-5	3.0	208	1	0	0	LG	ARNK0357R04	
FCU-5.3	3/3 CEILING CASSETTE	CR 0	CU-5	3.0	208	1	0	0	LG	ARNK0357R04	
FCU-5.4	3/3 CEILING CASSETTE	CR 0	CU-5	3.0	208	1	0	0	LG	ARNK0357R04	
FCU-5.5	3/3 CEILING CASSETTE	CR 0	CU-5	3.0	208	1	0	0	LG	ARNK0357R04	
FCU-5.6	3/3 CEILING CASSETTE	COLLAB 50	CU-5	3.0	208	1	0	0	LG	ARNK0357R04	
FCU-5.7	3/3 CEILING CASSETTE	COLLAB 50	CU-5	3.0	208	1	0	0	LG	ARNK0357R04	
FCU-5.8	2/2 CEILING CASSETTE	TEACHERS PLANNING 0	CU-5	2.3	208	1	0	0	LG	ARNK0357R04	
FCU-5.9	2/2 CEILING CASSETTE	TEACHERS PLANNING 0	CU-5	2.3	208	1	0	0	LG	ARNK0357R04	
FCU-5.10	2/2 CEILING CASSETTE	HUDDLE 636	CU-5	0.5	208	1	0	0	LG	ARNK0357R04	
FCU-5.11	3/3 CEILING CASSETTE	CR 0	CU-5	3.0	208	1	0	0	LG	ARNK0357R04	
FCU-5.12	3/3 CEILING CASSETTE	CR 0	CU-5	3.0	208	1	0	0	LG	ARNK0357R04	
FCU-6.1	3/3 CEILING CASSETTE	CR 0	CU-6	3.0	208	1	0	0	LG	ARNK0357R04	
FCU-6.2	2/2 CEILING CASSETTE	CORRIDOR	CU-6	2.0	208	1	0	0	LG	ARNK0357R04	
FCU-6.3	3/3 CEILING CASSETTE	COMPUTER LAB 396	CU-6	2.3	208	1	0	0	LG	ARNK0357R04	
FCU-6.4	3/3 CEILING CASSETTE	COMPUTER LAB 397	CU-6	2.3	208	1	0	0	LG	ARNK0357R04	
FCU-6.5	3/3 CEILING CASSETTE	COMPUTER LAB 398	CU-6	2.3	208	1	0	0	LG	ARNK0357R04	
FCU-6.6	3/3 CEILING CASSETTE	COMPUTER LAB 399	CU-6	2.3	208	1	0	0	LG	ARNK0357R04	
FCU-6.7	2/2 CEILING CASSETTE	BUSINESS OFFICE TECH 10	CU-6	1.0	208	1	0	0	LG	ARNK0357R04	
FCU-6.8	2/2 CEILING CASSETTE	RELATED CR 404	CU-6	1.5	208	1	0	0	LG	ARNK0357R04	
FCU-6.9	2/2 CEILING CASSETTE	OFFICE 401	CU-6	0.5	208	1	0	0	LG	ARNK0357R04	
FCU-6.10	2/2 CEILING CASSETTE	MARKETING 441	CU-6	1.5	208	1	0	0	LG	ARNK0357R04	
FCU-6.11	2/2 CEILING CASSETTE	RELATED CR 405	CU-6	1.5	208	1	0	0	LG	ARNK0357R04	
FCU-6.12	3/3 CEILING CASSETTE	SPED SMALL GROUP 79	CU-6	3.0	208	1	0	0	LG	ARNK0357R04	
FCU-6.13	3/3 CEILING CASSETTE	CR 0	CU-6	3.0	208	1	0	0	LG	ARNK0357R04	
FCU-6.14	3/3 CEILING CASSETTE	CR 0	CU-6	3.0	208	1	0	0	LG	ARNK0357R04	
FCU-6.15	3/3 CEILING CASSETTE	SPED LEARNING CENTER	CU-6	3.0	208	1	0	0	LG	ARNK0357R04	
FCU-6.16	3/3 CEILING CASSETTE	CR 68	CU-6	3.0	208	1	0	0	LG	ARNK0357R04	
FCU-6.17	3/3 CEILING CASSETTE	CR 69	CU-6	3.0	208	1	0	0	LG	ARNK0357R04	
FCU-6.18	3/3 CEILING CASSETTE	CR 70	CU-6	3.0	208	1	0	0	LG	ARNK0357R04	
FCU-7.1	2/2 CEILING CASSETTE	DEPT HEADS	CU-7	1.5	208	1	0	0	LG	ARNK0357R04	
FCU-7.2	2/2 CEILING CASSETTE	ACAD PROG 167	CU-7	0.5	208	1	0	0	LG	ARNK0357R04	
FCU-7.3	2/2 CEILING CASSETTE	INHOUSE DISSEMINATION 269	CU-7	0.8	208	1	0	0	LG	ARNK0357R04	
FCU-7.4	2/2 CEILING CASSETTE	AP1 169	CU-7	0.5	208	1	0	0	LG	ARNK0357R04	
FCU-7.5	2/2 CEILING CASSETTE	CONF 256	CU-7	0.8	208	1	0	0	LG	ARNK0357R04	
FCU-7.6	2/2 CEILING CASSETTE	CONF 256	CU-7	0.8	208	1	0	0	LG	ARNK0357R04	
FCU-7.7	2/2 CEILING CASSETTE	CONF 256	CU-7	0.8	208	1	0	0	LG	ARNK0357R04	
FCU-7.8	2/2 CEILING CASSETTE	CONF 256	CU-7	0.8	208	1	0	0	LG	ARNK0357R04	
FCU-7.9	2/2 CEILING CASSETTE	CONF 256	CU-7	0.8	208	1	0	0	LG	ARNK0357R04	
FCU-7.10	2/2 CEILING CASSETTE	CONF 256	CU-7	0.8	208	1	0	0	LG	ARNK0357R04	
FCU-7.11	2/2 CEILING CASSETTE	CONF 256	CU-7	0.8	208	1	0	0	LG	ARNK0357R04	
FCU-7.12	2/2 CEILING CASSETTE	CONF 256	CU-7	0.8	208	1	0	0	LG	ARNK0357R04	
FCU-7.13	2/2 CEILING CASSETTE	CONF 256	CU-7	0.8	208	1	0	0	LG	ARNK0357R04	
FCU-7.14	2/2 CEILING CASSETTE	CONF 256	CU-7	0.8	208	1	0	0	LG	ARNK0357R04	
FCU-7.15	2/2 CEILING CASSETTE	CONF 256	CU-7	0.8	208	1	0	0	LG	ARNK0357R04	
FCU-7.16	2/2 CEILING CASSETTE	CONF 256	CU-7	0.8	208	1	0	0	LG	ARNK0357R04	
FCU-7.17	2/2 CEILING CASSETTE	CONF 256	CU-7	0.8	208	1	0	0	LG	ARNK0357R04	
FCU-7.18	2/2 CEILING CASSETTE	CONF 256	CU-7	0.8	208	1	0	0	LG	ARNK0357R04	
FCU-7.19	2/2 CEILING CASSETTE	CONF 256	CU-7	0.8	208	1	0	0	LG	ARNK0357R04	
FCU-7.20	2/2 CEILING CASSETTE	CONF 256	CU-7	0.8	208	1	0	0	LG	ARNK0357R04	
FCU-7.21	2/2 CEILING CASSETTE	CONF 256	CU-7	0.8	208	1	0	0	LG	ARNK0357R04	
FCU-7.22	2/2 CEILING CASSETTE	CONF 256	CU-7	0.8	208	1	0	0	LG	ARNK0357R04	
FCU-7.23	2/2 CEILING CASSETTE	CONF 256	CU-7	0.8							

GRILLES, REGISTERS, AND DIFFUSERS

TAG NO	SERVICE	MOUNTING	MAX NC	CONSTRUCTION MATERIAL	FACE SIZE (IN) OR SLOT WIDTH	ACCESSORIES	MANUFACTURER	MODEL	NOTES
A	SUPPLY	LAY-IN	20	ALUMINUM	24x24	NA	TITUS	TDC	SEE NOTES
A1	SUPPLY	SURFACE	20	ALUMINUM	24x24	NA	TITUS	TDC	SEE NOTES
A3	SUPPLY	SIDEWALL	20	ALUMINUM	DUCT SIZE = 1-5/8"	NA	TITUS	TDC	SEE NOTES
C	EXHAUST/RETURN	LAY-IN	20	ALUMINUM	24x24	NA	TITUS	35FL	SEE NOTES
C1	EXHAUST/RETURN	SURFACE	20	ALUMINUM	12x12	NA	TITUS	35FL	SEE NOTES
C2	EXHAUST/RETURN	SIDEWALL	20	ALUMINUM	DUCT SIZE = 1-5/8"	NA	TITUS	35FL	SEE NOTES
D	SUPPLY	LAY-IN	20	ALUMINUM	(2) 1.5" SLOTS	INSULATED PLENUM	TITUS	FL-15-HT	SEE NOTES
D1	SUPPLY	MID-IN	20	ALUMINUM	(1) 1" SLOT	NA	TITUS	FL-10-HT	SEE NOTES
D2	SUPPLY	MID-IN	20	ALUMINUM	(2) 1" SLOTS	NA	TITUS	FL-10-HT	SEE NOTES
E	SUPPLY	SURFACE	20	ALUMINUM	(4) 1" SLOTS	BLACK INSULATED PLENUM	TITUS	ML-39	SEE NOTES
F	SUPPLY	DUCT MOUNTED	20	ALUMINUM	DUCT SIZE = 1-1/2"	NA	TITUS	S300FL	SEE NOTES
G	EXHAUST/RETURN	DUCT MOUNTED	20	ALUMINUM	DUCT SIZE = 1-1/2"	NA	TITUS	S8F	SEE NOTES
H	EXHAUST/RETURN	SURFACE	20	ALUMINUM	(4) 1" SLOTS	NA	TITUS	MLR-39	SEE NOTES
I	SUPPLY	FLOOR MOUNTED	20	ALUMINUM	1/2" BARS 30 DEG DEFLEC	NA	TITUS	CT-PP-3	SEE NOTES

- NOTES:
- REFER TO SPECIFICATIONS SECTION 23000 FOR ALTERNATE MANUFACTURERS FOR PRODUCTS/SYSTEMS LISTED UNDER THIS SCHEDULE.
 - FINISH SHALL BE SELECTED BY THE ARCHITECT
 - FRAME BORDER SHALL MATCH CEILING TYPE. COORDINATE WITH THE ARCHITECTURAL PLANS.
 - SEE DRAWINGS FOR HOOK SIZE AND AIR BLOW PATTERN. PROVIDE DIRECTIONAL CLIPS. THE CONTRACTOR SHALL INSTALL BLOW CLIPS IN THE FIELD.
 - FLOOR GRILLE SHALL BE PROVIDED AND INSTALLED BY ACCESS FLOOR CONTRACTOR.
 - PROVIDE WITH STAINLESS STEEL FACE AND ALUMINUM BACK PAN.
 - THE LINEAR SLOT DIFFUSERS SHALL BE ADJUSTED FOR TWO WAY PATTERN.

SOUND ATTENUATOR SCHEDULE (SA)

UNIT NO.	LOCATION	AIR FLOW (CFM)	MANUFACTURER	MODEL	REMARKS
SA-0					
SA-0					
SA-A1S1	0				
SA-A3R1	0				
SA-MR1	0				
SA-MR1	0				
SA-MR1	0				
SA-MR1	0				
SA-MR1	10255		VIBRO-ACOUSTICS		
SA-RP1	0				
SA-RS1	0				
SA-RS2	0				

- NOTES:
- REFER TO SPECIFICATIONS SECTION 23000 FOR ALTERNATE MANUFACTURERS FOR PRODUCTS/SYSTEMS LISTED UNDER THIS SCHEDULE.
 - PROVIDE ELBOW SOUND ATTENUATORS CUSTOM DESIGNED TO ATTACH DIRECTLY TO ROOFTOP UNIT DUCT CONNECTION. ROUTE THROUGH ROOF CURB AND PENETRATE ROOF DECK. EXTEND DOWNWARD TO CLEAR STRUCTURE BEFORE TURNING INTO A HORIZONTAL POSITION. SEAL ROOF PENETRATIONS TO SOUND ATTENUATORS.
 - PROVIDE "T" SHAPED DOUBLE ELBOW TYPE SOUND ATTENUATORS CUSTOM DESIGNED TO ATTACH DIRECTLY TO ROOFTOP UNIT DUCT CONNECTION. ROUTE THROUGH ROOF CURB AND PENETRATE ROOF DECK. EXTEND DOWNWARD TO CLEAR STRUCTURE BEFORE TURNING INTO A HORIZONTAL POSITION. SEAL ROOF PENETRATIONS TO SOUND ATTENUATORS.
 - ALL SOUND ATTENUATORS OVERALL WIDTH AND LENGTH SHALL MATCH THE ASSOCIATED AIR HANDLERS DUCT CONNECTION SIZE. CONTRACTOR TO COORDINATE WITH SUBMITTED AIR HANDLER SHOP DRAWING PRIOR TO ORDERING SOUND ATTENUATORS.

DESTRATIFICATION FAN (DF)

UNIT NO	BLADE DIA (FT)	MAXIMUM CFM	ELEC DATA	HP	WATTS	RPM	SERVICE	MANUFACTURER	MODEL	REMARKS
DF-1	18	0	480	3	2.0	86		GYM	BAF	SEE NOTES

- NOTES:
- REFER TO SPECIFICATIONS SECTION 23000 FOR ALTERNATE MANUFACTURERS FOR PRODUCTS/SYSTEMS LISTED UNDER THIS SCHEDULE.
 - PROVIDE WIRE CAGE/GUARD FOR FAN AND DOWN DROPS.

FAN TERMINAL UNIT -ELECTRIC HEATING (FTU)

UNIT NO	SYSTEM	TYPE	PRIMARY AIRFLOW (IN) (N)	MAX. DESIGN AIRFLOW (CFM)	MIN DESIGN AIRFLOW (CFM)	TOTAL PRESSURE DROP (IN.WG)	FAN SIZE	FAN SP (IN.WG)	MOTOR SIZE (HP)	V	PH	DISCH	RAD	EAT DB (F)	LAT DB (F)	KW	V	PH	MCA	MOCP	MANUFACTURER	MODEL	NOTES
FTU-1		SERIES	12"	1025	155	0.00		0.00	1	0	1			65.0	65.0	0.0	0	1	0.0	0			
FTU-2		SERIES	12"	1025	155	0.00		0.00	1	0	1			65.0	65.0	0.0	0	1	0.0	0			
FTU-3		SERIES	12"	1025	155	0.00		0.00	1	0	1			65.0	65.0	0.0	0	1	0.0	0			
FTU-4		SERIES	12"	945	145	0.00		0.00	1	0	1			65.0	65.0	0.0	0	1	0.0	0			
FTU-5	COSMETOLOGY	SERIES	12"	1230	185	1.00	04	0.50	0.5	277	1	35	37	65.0	65.8	12.0	480	3	23.2	25	TITUS	DTQS	SEE NOTES
FTU-6	COSMETOLOGY	SERIES	12"	1230	185	1.00	04	0.50	0.5	277	1	35	37	65.0	65.8	12.0	480	3	23.2	25	TITUS	DTQS	SEE NOTES
FTU-7	CULINARY CR	SERIES	14"	1500	225	1.00	06	0.50	1	277	1	28	35	65.0	66.6	15.0	480	3	31.2	35	TITUS	DTQS	SEE NOTES
FTU-8	CULINARY KITCHEN	SERIES	14"	2250	340	1.00	06	0.00	1	277	1	36	43	65.0	65.9	22.0	480	3	41.7	45	TITUS	DTQS	SEE NOTES
FTU-9	CULINARY KITCHEN	SERIES	14"	2250	340	1.00	06	0.00	1	277	1	36	43	65.0	65.9	22.0	480	3	41.7	45	TITUS	DTQS	SEE NOTES

- NOTES:
- REFER TO SPECIFICATIONS SECTION 23000 FOR ALTERNATE MANUFACTURERS FOR PRODUCTS/SYSTEMS LISTED UNDER THIS SCHEDULE.
 - PROVIDE EG MOTOR.
 - PROVIDE 1" FILTER.
 - PROVIDE 1" FOL FACED LNER.
 - SCHEDULED TOTAL PRESSURE DROP ACROSS PRIMARY AIR VALVE IS APPLICABLE AT MAXIMUM AIRFLOW SETPOINT.
 - PROVIDE WITH FUSED DISCONNECT.
 - SINGLE POINT POWER CONNECTION.
 - PROVIDE SCR CONTROL FOR ELECTRIC HEAT.
 - ATC CONTRACTOR SHALL PROVIDE CONTROL VOLTAGE TRANSFORMERS, CONTROLS AND CONTOLLERS.

AIR COOLED VRF CONDENSING UNIT (VCU)

UNIT NO	SYSTEM	LOCATION	NOMINAL CAPACITY (TONS)	MODULE QUANTITY	MODULE A				MODULE B				MODULE C				TOTAL TONNAGE	SOUND RATING (DB)	MANUFACTURER	MODEL	NOTES
					V	PH	A	MOCP	V	PH	MCA	MOCP	V	PH	MCA	FLA					
VCU-1A	AHU-1	ROOF AREA C	22	2	460	3	16.4	25	460	3	28.5	35				63	LG	ARUM264DTE5			
VCU-1B	AHU-1	ROOF AREA C	22	2	460	3	16.4	25	460	3	28.5	35				63	LG	ARUM264DTE5			
VCU-1C	AHU-1	ROOF AREA C	22	2	460	3	16.4	25	460	3	28.5	35				63	LG	ARUM264DTE5			
VCU-2A	AHU-2	ROOF AREA C	22	2	460	3	16.4	25	460	3	28.5	35				63	LG	ARUM264DTE5			
VCU-2B	AHU-2	ROOF AREA C	22	2	460	3	16.4	25	460	3	28.5	35				63	LG	ARUM264DTE5			
VCU-2C	AHU-2	ROOF AREA C	22	2	460	3	16.4	25	460	3	28.5	35				63	LG	ARUM264DTE5			
VCU-3A	AHU-3	ROOF AREA D	26	2	460	3	16.4	25	460	4	38.3	50				65	LG	ARUM3128TE5			
VCU-3B	AHU-3	ROOF AREA D	26	2	460	3	16.4	25	460	3	38.3	50				65	LG	ARUM3128TE5			
VCU-4A	AHU-4	ROOF AREA B	14	1	460	3	28.5	35								61	LG	ARUM168DTE5			
VCU-4B	AHU-4	ROOF AREA B	14	1	460	3	28.5	35								61	LG	ARUM168DTE5			
VCU-5A	AHU-5	ROOF AREA B	12	1	460	3	26.4	35								60	LG	ARUM144DTE5			
VCU-5B	AHU-5	ROOF AREA B	12	1	460	3	26.4	35								60	LG	ARUM144DTE5			
VCU-6A	AHU-6	ROOF AREA A	12	1	460	3	18.4	25								59	LG	ARUM121DTE5			
VCU-6B	AHU-6	ROOF AREA A	12	1	460	3	18.4	25								59	LG	ARUM121DTE5			
VCU-7A	AHU-7	ROOF AREA A	14	1	460	3	28.5	35								61	LG	ARUM168DTE5			
VCU-7B	AHU-7	ROOF AREA A	14	1	460	3	28.5	35								61	LG	ARUM168DTE5			
VCU-8A	AHU-8	ROOF AREA A	20	1	460	3	37.2	50								65	LG	ARUM241DTE5			
VCU-8B	AHU-8	ROOF AREA A	20	1	460	3	37.2	50								65	LG	ARUM241DTE5			
VCU-9A	AHU-9	ROOF AREA C	14	1	460	3	28.5	35								61	LG	ARUM168DTE5			
VCU-9B	AHU-9	ROOF AREA C	14	1	460	3	28.5	35								61	LG	ARUM168DTE5			
VCU-10A	AHU-10	ROOF AREA D	22	2	460	3	16.4	25	460	3	28.5	35				63	LG	ARUM264DTE5			
VCU-10B	AHU-10	ROOF AREA D	22	2	460	3	16.4	25	460	3	28.5	35				63	LG	ARUM264DTE5			
VCU-11A	HRU-1	ROOF AREA A	24	2	460	3	16.4	25	460	3	35.7	50				63	LG	ARUM288DTE5			
VCU-11B	HRU-1	ROOF AREA A	24	2	460	3	16.4	25	460	3	35.7	50				63	LG	ARUM288DTE5			
VCU-11C	HRU-1	ROOF AREA A	24	2	460	3	16.4	25	460	3	35.7	50				63	LG	ARUM288DTE5			
VCU-12A	HRU-2	ROOF AREA A	24	2	460	3	16.4	25	460	3	35.7	50				63	LG	ARUM288DTE5			
VCU-12B	HRU-2	ROOF AREA A	24	2	460	3	16.4	25	460	3	35.7	50				63	LG	ARUM288DTE5			
VCU-12C	HRU-2	ROOF AREA A	24	2	460	3	16.4	25	460	3	35.7	50				63	LG	ARUM288DTE5			
VCU-13A	HRU-3	ROOF AREA B	24	2	460	3	16.4	25	460	3	35.7	50				63	LG	ARUM288DTE5			
VCU-13B	HRU-3	ROOF AREA B	24	2	460	3	16.4	25	460	3	35.7	50				63	LG	ARUM288DTE5			
VCU-13C	HRU-3	ROOF AREA B	24	2	460	3	16.4	25	460	3	35.7	50				63	LG	ARUM288DTE5			
VCU-14A	HRU-4	ROOF AREA C	18	1	460	3	50.0	38								64	LG	ARUM216DTE5			
VCU-14B	HRU-4	ROOF AREA D	18	1	460	3	50.0	38								64	LG	ARUM216DTE5			
VCU-15A	HRU-5	ROOF AREA B	6	1	460	3	20.0	13								58	LG	ARUM72DTE5			
VCU-15B	HRU-5	ROOF AREA B	6	1	460	3	20.0	13								58	LG	ARUM72DTE5			
VCU-16A	MAU-1	ROOF AREA A	18	1	460	3	50.0	38								64	LG	ARUM216DTE5			
VCU-16B	MAU-1	ROOF AREA A	18	1	460	3	50.0	38								64	LG	ARUM216DTE5			
VCU-16C	MAU-2	ROOF AREA A	30	2	460	3	26.4	35	460	4	38.3	50				66	LG	ARUM360DTE5			
VCU-16D	MAU-2	ROOF AREA A	30	2	460	3	26.4	35	460	4	38.3	50				66	LG	ARUM360DTE5			
VCU-16E	MAU-2	ROOF AREA A	30	2	460	3	26.4	35	460	3	38.3	50				66	LG	ARUM360DTE5			
VCU-17A	RTU-1	ROOF AREA A	6	1	460	3	20.0	13								58	LG	ARUM72DTE5			
VCU-17B	RTU-2	ROOF AREA D	18	1	460	3	50.0	38								62	LG	ARUM160DTE5			
VCU-17C	RTU-2	ROOF AREA D	18	1	460	3	50.0	38								62	LG	ARUM160DTE5			
VCU-17D	RTU-2	ROOF AREA D	18	1	460	3	50.0	38								62	LG	ARUM160DTE5			
VCU-17E	RTU-2	ROOF AREA D	18	1	460	3	50.0	38								62	LG	ARUM160DTE5			
VCU-17F	RTU-2	ROOF AREA D	18	1	460	3	50.0	38								62	LG	ARUM160DTE5			
VCU-17G	RTU-2	ROOF AREA D	18	1	460	3	50.0	38								62	LG	ARUM160DTE5			
VCU-17H	RTU-2	ROOF AREA D	18	1	460	3	50.0	38								62	LG	ARUM160DTE5			
VCU-17I	RTU-2	ROOF AREA D	18	1	460	3	50.0	38								62	LG	ARUM160DTE5			
VCU-17J	RTU-2	ROOF AREA D	18	1	460	3	50.0	38								62	LG	ARUM160DTE5			
VCU-17K	RTU-2	ROOF AREA D	18	1	460	3	50.0	38								62	LG	ARUM160DTE5			
VCU-17L	RTU-2	ROOF AREA D	18	1	460	3	50.0	38								62	LG	ARUM160DTE5			